

FORT FISHER
AQUARIUM
RENOVATION
& EXPANSION:
PHASE 1

SCO #17-18042-02A
CODE: 42014-4G02
ITEM: 41414-4Y4A

900 LOGGERHEAD RD,
KURE BEACH, NC 28449

NORTH CAROLINA DEPT. OF
NATURAL & CULTURAL RESOURCES

SZOSTAK DESIGN, INC.

ARCHITECT
310 1/2 WEST FRANKLIN STREET
CHapel Hill, NC 27514
TEL: 919.929.2444
FAX: 919.962.7967
WWW.SZOSTAKDESIGN.COM
LICENSE # 81019

TJP ENGINEERING, INC.
LIFE SUPPORT SYSTEMS ENGINEER
5680 VENTURE LANE SUITE 205N
Reno, CA 97701
TEL: 916.433.0700
WWW.TJPEENGINEERING.COM
LICENSE # C-3555

ROTO GROUP, LLC.

OWNER DESIGNER
7001 DISCOVERY BOULEVARD
DURHAM, NC 27707
TEL: 919.282.5887
TEL: 919.282.5887
WWW.ROTO.COM
WWW.ROTO.COM

BENNETT & PLESS

STRUCTURAL ENGINEER
5400 WACE PARK BOULEVARD SUITE 400
RALEIGH, NC 27607
TEL: 919.791.4000
WWW.BENNETTANDESIGN.COM
LICENSE # F-1105

CBHF ENGINEERS, PLLC

MFP ENGINEER
2244 YALPON DRIVE
WILMINGTON, NC 28401
TEL: 910.791.4000
FAX: 910.791.4000
WWW.CBHFENGINEERS.COM
LICENSE # F-3132

LIGHTSWITCH

LIGHTING DESIGNER
10506 NICHOLAS COURT
RANCHO CUCUMBERG, CA 91730
TEL: 909.360.7000
WWW.LIGHTSWITCH.NET

TUNSTALL CONSULTING ENGINEERS PLLC

CIVIL ENGINEER
2600 HUNTER GATE DRIVE SUITE 102
WILMINGTON, NC 28412
TEL: 910.791.4000
FAX: 910.791.4000
WWW.TUNSTALLCONSULTING.COM
LICENSE # F-3132

SURFACE 678, PA

LANDSCAPE ARCHITECT
215 MOORE STREET SUITE 150
DURHAM, NC 27701
TEL: 919.419.1199
FAX: 919.419.1199
WWW.SURFACE678.COM
LICENSE # F-208

CHEATHAM & ASSOCIATES, PA

RFI PROTECTION ENGINEER
3412 EMBERSIDE DRIVE
WILMINGTON, NC 28405
TEL: 910.452.8100
WWW.CHEATHAMPAC.COM
LICENSE # C-1073

PALACIO COLLABORATIVE

COST ESTIMATOR
4810 EMBERSIDE BOULEVARD SUITE 400
DURHAM, NC 27707
TEL: 919.452.8100
WWW.PALACIOCOLLABORATIVE.COM

NOTE: IF THIS DRAWING IS NOT 30" X 42", IT IS A
REDUCED PRINT. REFER TO GRAPHIC SCALE.

NOT FOR
CONSTRUCTION

SEAL
20851
ENGINEER
DAVID M. HAN

NOT FOR
CONSTRUCTION

NO. DATE DESCRIPTION
1 9-8-25 BID SET

PLUMBING NOTES,
ABBREVIATIONS,
SCHEDULES

PLUMBING GENERAL NOTES:

- SCOPE OF WORK: THESE DRAWINGS AND ACCOMPANYING SPECIFICATIONS DESCRIBE SCOPE OF WORK REQUIRED FOR PLUMBING SYSTEMS. LABOR AND MATERIAL SHALL BE PROVIDED AS REQUIRED FOR A COMPLETE, WORKMANLIKE INSTALLATION OF ALL SYSTEMS SHOWN ON DIAGRAMMATIC DRAWINGS AND/OR AS SPECIFIED HEREIN.
- CONTRACTOR: THE WORD "CONTRACTOR", "PLUMBING CONTRACTOR", AND "P.C." AS USED HEREIN SHALL MEAN THE PLUMBING INSTALLER UNLESS OTHERWISE QUALIFIED.
- DRAWINGS: DRAWINGS ARE DIAGRAMMATIC AND MAY NOT COMPLETELY DESCRIBE EVERY DETAIL OF THE INSTALLATION. HOWEVER, CONTRACTOR IS RESPONSIBLE FOR FURNISHING COMPLETE SYSTEMS INCLUDING ALL REQUIRED EQUIPMENT AND ACCESSORIES TO OBTAIN FULLY FUNCTIONING PLUMBING SYSTEMS.
- CODE COMPLIANCE: COMPLY WITH THE LATEST EDITIONS OF THE FOLLOWING STANDARDS AND CODES, INsofar AS THEY APPLY:

NORTH CAROLINA STATE BUILDING CODE (CODE), LATEST EDITION AND REVISIONS.

LOCAL JURISDICTION REQUIREMENTS.
- PERMITS AND INSPECTIONS: OBTAIN ALL PERMITS, LICENSES, INSPECTIONS, ETC., REQUIRED FOR THE WORK AND PAY FOR SAME. FURNISH A FINAL CERTIFICATE OF INSPECTION AND APPROVAL FROM THE AUTHORITY HAVING JURISDICTION PRIOR TO ACCEPTANCE OF THE WORK.
- SUPERVISION: PROVIDE SKILLED SUPERINTENDENTS TO SUPERVISE THE WORK FROM THE BEGINNING TO COMPLETION AND FINAL INSPECTION.
- PROGRESS OF WORK: PERFORM WORK IN ACCORDANCE WITH SCHEDULE AND REQUIREMENTS OF THE GENERAL CONTRACTOR. UNDER NO CIRCUMSTANCES SHALL THIS CONTRACTOR DELAY THE OVERALL PROJECT SCHEDULE.
- COORDINATION: COORDINATE PLUMBING WORK WITH THE WORK OF OTHER TRADES. LOCATIONS SHOWN ON THE DRAWINGS ARE APPROXIMATE UNLESS SPECIFICALLY DIMENSIONED. ARRANGE PLUMBING SO AS NOT TO INTERFERE WITH THE WORK OF OTHER TRADES. VERIFY ACTUAL BUILDING STRUCTURE PRIOR TO DUCT FABRICATION AND ADJUST LAYOUT AS REQUIRED. INCLUDE ALL OFFSETS IN DUCTS, FITTINGS, PIPING, ETC. AS REQUIRED TO PROPERLY INSTALL EQUIPMENT.
- EQUIPMENT LOCATIONS: DETERMINE EXACT EQUIPMENT AND MATERIALS LOCATIONS TO PROVIDE BEST ARRANGEMENT AND TO FACILITATE PROPER MAINTENANCE AND SERVICING OF EQUIPMENT.
- LISTING AND LABELING: ALL EQUIPMENT SHALL BE LABELED OR LISTED BY UL OR OTHER APPROVED TESTING AGENCY WHERE REQUIRED.
- STORAGE SPACE: CONSULT WITH THE GENERAL CONTRACTOR REGARDING JOB SITE STORAGE FOR PLUMBING MATERIALS TO BE INSTALLED UNDER THIS PROJECT. STORAGE SPACE MUST BE SECURED AND CONTRACTOR'S REPRESENTATIVE MUST BE ON JOB BEFORE ANY MATERIAL MAY BE RECEIVED.
- CLEANUP: REMOVE ALL DEBRIS GENERATED IN THE ACCOMPLISHMENT OF WORK UNDER THIS PROJECT. CLEAN, REPLACE OR REPAIR ALL SURFACES SOILED OR DAMAGED DURING THE COURSE OF THE WORK. REMOVE DEBRIS DAILY SO TO MAINTAIN SAFE WORKING CONDITIONS.
- RECORD DRAWINGS: MAINTAIN ONE SET OF "RED-LINED" RECORD DRAWINGS ON SITE AT ALL TIMES AND PROVIDE DRAWINGS TO ARCHITECT/ENGINEER PRIOR TO FINAL INSPECTION.
- EXISTING BUILDINGS AND CONSTRUCTION:
 - WORK UNDER THIS CONTRACT IS TO BE PERFORMED IN AN EXISTING BUILDING. BUILDING LAYOUT INDICATED IS DEVELOPED FROM EXISTING RECORD DOCUMENTS AND LIMITED FIELD VERIFICATION FOR THE PURPOSES OF DESCRIBING THE WORK. VERIFY ALL EXISTING CONDITIONS AND ADJUST WORK AS REQUIRED TO SUIT ACTUAL FIELD CONDITIONS.
 - PERFORM ALL WORK IN ACCORDANCE WITH SAFETY REGULATIONS.
 - DO NOT CUT ANY STRUCTURAL MEMBERS WITHOUT EXPRESS WRITTEN INSTRUCTIONS FROM ARCHITECT/ENGINEER. PROVIDE CUTTING AND PATCHING FOR EXISTING FINISHES AS REQUIRED.
 - COORDINATE INSTALLATION OF NEW PLUMBING SYSTEMS WITH EXISTING BUILDING SYSTEMS. ADJUST ARRANGEMENTS AS REQUIRED TO ACCOMMODATE INTERFERENCES.

PLUMBING DEMOLITION NOTES:

- THE PLUMBING CONTRACTOR SHALL REVIEW THE DRAWINGS AND SPECIFICATIONS FOR DEMOLITION REQUIREMENTS AND LAYOUT HIS WORK IN A COMPATIBLE AND COMPLEMENTARY MANNER. REMOVE ALL FIXTURES, EQUIPMENT, PIPING, SUPPORTS, ACCESSORIES, ETC. MADE OBSOLETE BY THESE ALTERATIONS AS SHOWN IN THE PLUMBING DRAWINGS. ALL ITEMS TO BE REMOVED OR MODIFIED MAY NOT BE SHOWN, HOWEVER, THIS CONTRACTOR SHALL REMOVE ANY PLUMBING WORK AS REQUIRED BY THE CONSTRUCTION OR AS DIRECTED BY THE OWNER OR THE ENGINEER. SURVEY THE AFFECTED AREAS BEFORE SUBMITTING A BID.
- ALL EXISTING PLUMBING FIXTURES, EQUIPMENT AND PIPING SHALL REMAIN UNLESS SPECIFICALLY NOTED TO BE REMOVED.
- THESE DRAWINGS ARE COMPLIED BY THE ARCHITECT/ENGINEER FROM THE OWNERS AS-BUILT RECORD DRAWINGS AND LIMITED FIELD VERIFICATION OF EXISTING CONDITIONS FOR THE PURPOSE OF INDICATING THE WORK REQUIRED AND ARE BELIEVED TO BE CORRECT. NOTWITHSTANDING, THE PLUMBING CONTRACTOR SHALL VERIFY ALL PIPING, FIXTURE LOCATIONS, DIMENSIONS, MATERIALS AND ALL FIELD CONDITIONS AFFECTING HIS WORK.
- WHERE PLUMBING SYSTEMS PASS THROUGH THE DEMOLITION AREAS TO SERVE OTHER PORTIONS OF THE PREMISES, THEY SHALL REMAIN OR BE SUITABLY RELOCATED AND THE SYSTEM RESTORED TO NORMAL OPERATION. ADVISE THE ARCHITECT/ENGINEER IMMEDIATELY IF SUCH CONDITIONS ARE UNCOVERED BEFORE PROCEEDING WITH ADDITIONAL WORK.
- PROTECT ALL EXISTING LIFE SAFETY SYSTEMS, FIRE ALARM AND PUBLIC ADDRESS SYSTEMS AND MAINTAIN THEM IN OPERATION THROUGHOUT THE PROGRESS OF THE WORK. NOTIFY THE OWNER AND ARCHITECT/ENGINEER IN WRITING WHEN SHUTDOWNS ARE REQUIRED PRIOR TO ANY OUTAGE OF SERVICE. WHERE THE DURATION OF A PROPOSED OUTAGE CANNOT BE TOLERATED BY THE OWNER, PROVIDE TEMPORARY CONNECTIONS AS REQUIRED TO MAINTAIN SERVICE.
- SURVEY THE EFFECTED AREAS BEFORE SUBMITTING A BID AS ALL EXISTING CONDITIONS CANNOT BE COMPLETELY DEPICTED ON THE DRAWINGS AND SOME UNUSUAL CONDITIONS MAY EXIST.

PLUMBING FIXTURE SCHEDULE

DRAWING FIXTURE CODE		DESCRIPTION	MANUFACTURER	MODEL	ALTERNATE APPROVED MANUFACTURERS	NOTES	PIPE SIZE DCW	DHW	WASTE	VENT	
WC1	FLUSH VALVE WATER CLOSET, WALL HUNG, 1.28GPF, ADA	BOWL	ELONGATED, SIPHON JET, V.C., 2-1/8" TRAPWAY, TOP SPUD, WALL, MOUNT 17-19"A.F.F.	K-84325-L	ZURN, AMERICAN STANDARD						
		FLUSH VALVE	BATTERY POWERED SENSOR, 1.28 GPF, POLISHED CHROME, DIAPHRAM, TOP SPUD, LESS HANDLE, COURTESY FLUSH OVERRIDE BUTTON	G2 8111-1.28	KOHLER, ZURN		6,7	1"	-	4"	2"
		SEAT	OFLC w/ SELF-SUSTAINING S.S. CHECK HINGE; HEIGHT 17-19" AFF	295SCT	BEMIS, OLSONITE						
		CARRIER	VERTICAL FLOOR MOUNT	JR SMITH	ZURN, JOSAM						
WC2	FLUSH VALVE WATER CLOSET, WALL HUNG, 1.28GPF	CARRIER	HORIZONTAL FLOOR MOUNT	0240-MS8-M54	ZURN, JOSAM						
		BOWL	ELONGATED, SIPHON JET, V.C., 2-1/8" TRAPWAY, TOP SPUD, WALL, MOUNT 17-19"A.F.F.	0210Y-M54	ZURN, AMERICAN STANDARD		7	1"	-	4"	2"
		FLUSH VALVE	BATTERY POWERED SENSOR, 1.28 GPF, POLISHED CHROME, DIAPHRAM, TOP SPUD, LESS HANDLE, COURTESY FLUSH OVERRIDE BUTTON	K-84325-L	KOHLER, ZURN						
		SEAT	OFLC w/ SELF-SUSTAINING S.S. CHECK HINGE	G2 8111-1.28	KOHLER, ZURN						
WC3	FLUSH VALVE WATER CLOSET, WALL HUNG, 1.28GPF, ADA (AMBULATORY)	CARRIER	VERTICAL FLOOR MOUNT	295SCT	BEMIS, OLSONITE		6,7	1"	-	4"	2"
		CARRIER	HORIZONTAL FLOOR MOUNT	0240-MS8-M54	ZURN, JOSAM						
		BOWL	ELONGATED, SIPHON JET, V.C., 2-1/8" TRAPWAY, TOP SPUD, WALL, MOUNT 17-19"A.F.F.	0210Y-M54	ZURN, AMERICAN STANDARD						
		FLUSH VALVE	BATTERY POWERED SENSOR, 1.28 GPF, POLISHED CHROME, DIAPHRAM, TOP SPUD, LESS HANDLE, COURTESY FLUSH OVERRIDE BUTTON	K-84325-L	KOHLER, ZURN						
WC4	FLUSH VALVE WATER CLOSET, FLOOR MOUNT, 1.6GPF, ADA	CARRIER	HORIZONTAL FLOOR MOUNT	G2 8111-1.28	KOHLER, ZURN		6	1"	-	4"	2"
		CARRIER	BATTERY POWERED SENSOR, 1.28 GPF, POLISHED CHROME, DIAPHRAM, TOP SPUD, LESS HANDLE, COURTESY FLUSH OVERRIDE BUTTON	295SCT	BEMIS, OLSONITE						
		BOWL	ELONGATED, SIPHON JET, V.C., 2-1/8" TRAPWAY, TOP SPUD, WALL, MOUNT 17-19" AFF	K-4991-ETSS-0	ZURN, AMERICAN STANDARD						
		FLUSH VALVE	1.025 GPF, POLISHED CHROME, TOP SPUD, SINGLE FLUSH, LITHIUM BATTERIES INCLUDED, COURTESY FLUSH OVERRIDE BUTTON	R186-0.125	KOHLER, ZURN		1	3/4"	-	2"	2"
UR1	HANDS FREE URINAL, WALL HUNG, 0.125GPF, ADA	BOWL	HIGH EFFICIENCY, WASHOUT, TOP SPUD, ANTIMICROBIAL	K-4991-ETSS-0	ZURN, AMERICAN STANDARD		1	3/4"	-	2"	2"
		FLUSH VALVE	0.125 GPF, POLISHED CHROME, TOP SPUD, SINGLE FLUSH, LITHIUM BATTERIES INCLUDED, COURTESY FLUSH OVERRIDE BUTTON	R186-0.125	KOHLER, ZURN						
		CARRIER	VERTICAL FLOOR MOUNT	K-20000	AMERICAN STANDARD						
		FAUCET	20x16 VITREOUS CHINA, RIM 3/4" AFF MAX.	8559	ZURN, DELTA		1,2,3,9	1/2"	1/2"	2"	2"
LAV1	UNDERMOUNT LAVATORY, 0.5GPM, ADA	CARRIER	CAST BRASS, CHROME PLATED, OPEN GRID STRAINER P.O. PLUG WITH BRASS TAILPIECE	1554	DEARBORN, DELTA						
		MIXING VALVE	LEAD FREE THERMOSTATIC MIXING VALVE - SETPOINT = 105%KDF INSTALL ON HOT WATER SUPPLY, ASSE 1070	HG-135	CASH A/CME						
		BOWL	20x16 VITREOUS CHINA, RIM 3/4" AFF MAX.	K-4991-ETSS-0	ZURN, AMERICAN STANDARD		1,2,3,9	1/2"	1/2"	2"	2"
		FAUCET	4" CENTERSET, SINGLE LEVER HANDLE, SOLID BRASS CONSTRUCTION, CERAMIC CARTRIDGE, HIGH TEMP LIMIT STOP	8413F05	ZURN, DELTA						
LAV2	UNDERMOUNT LAVATORY, 0.5GPM, ADA STAFF	CARRIER	CAST BRASS, CHROME PLATED, OPEN GRID STRAINER P.O. PLUG WITH BRASS TAILPIECE	1554	DEARBORN, DELTA						
		MIXING VALVE	LEAD FREE THERMOSTATIC MIXING VALVE - SETPOINT = 105%KDF INSTALL ON HOT WATER SUPPLY, ASSE 1070	HG-135	CASH A/CME						
		BOWL	4" CENTERSET, SINGLE LEVER HANDLE, SOLID BRASS CONSTRUCTION, CERAMIC CARTRIDGE, HIGH TEMP LIMIT STOP	K-4991-ETSS-0	ZURN, AMERICAN STANDARD		1,2,3,9	1/2"	1/2"	2"	2"
		FAUCET	16"x20", 12" DEEP, 8" HIGH SPLASH, STAINLESS OPEN FRAME BASE, SIDE CROSSRAILS, 18 GAUGE, TYPE 304 STAINLESS	8413F05	ZURN, DELTA						
SK1	ONE COMPARTMENT STAINLESS SINK	CARRIER	6" SWIVEL GOOSENECK, BRASS CHROME PLATED BODY, SPLASH MOUNT, WRISTBLADE HANDLES	8559	DEARBORN, DELTA		1,2,3,9	1/2"	1/2"	2"	2"
		MIXING VALVE	LEAD FREE THERMOSTATIC MIXING VALVE - SETPOINT = 105%KDF INSTALL ON HOT WATER SUPPLY, ASSE 1070	HG-135	CASH A/CME						
		BOWL	16"x20", 12" DEEP, 8" HIGH SPLASH, STAINLESS OPEN FRAME BASE, SIDE CROSSRAILS, 18 GAUGE, TYPE 304 STAINLESS	8413F05	ZURN, DELTA						
		FAUCET	6" SWIVEL GOOSENECK, BRASS CHROME PLATED BODY, SPLASH MOUNT, WRISTBLADE HANDLES	K-6	DEARBORN, DELTA		1,2,3,9	1/2"	1/2"	2"	2"
SK2	ONE COMPARTMENT STAINLESS SINK	CARRIER	CAST BRASS, CHROME PLATED BASKET STRAINER WITH BRASS TAILPIECE	8559	DEARBORN, DELTA		1,2,3,9	1/2"	1/2"	2"	2"
		MIXING VALVE	LEAD FREE THERMOSTATIC MIXING VALVE - SETPOINT = 105%KDF INSTALL ON HOT WATER SUPPLY, ASSE 1070	HG-135	CASH A/CME						
		BOWL	16"x20", 12" DEEP, 8" HIGH SPLASH, STAINLESS OPEN FRAME BASE, SIDE CROSSRAILS, 18 GAUGE, TYPE 304 STAINLESS	8413F05	ZURN, DELTA						
		FAUCET	6" SWIVEL GOOSENECK, BRASS CHROME PLATED BODY, SPLASH MOUNT, WRISTBLADE HANDLES	K-6	DEARBORN, DELTA		1,2,3,9	1/2"	1/2"	2"	2"
SK3	TWO COMPARTMENT STAINLESS SINK	CARRIER	CAST BRASS, CHROME PLATED BASKET STRAINER WITH BRASS TAILPIECE	8559	DEARBORN, DELTA		1,2,3,9	1/2"	1/2"	2"	2"
		MIXING VALVE	LEAD FREE THERMOSTATIC MIXING VALVE - SETPOINT = 105%KDF INSTALL ON HOT WATER SUPPLY, ASSE 1070	HG-135	CASH A/CME						
		BOWL	16"x20", 12" DEEP, 8" HIGH SPLASH, STAINLESS OPEN FRAME BASE, SIDE CROSSRAILS, 18 GAUGE, TYPE 304 STAINLESS	8413F05	ZURN, DELTA						
		FAUCET	6" SWIVEL GOOSENECK, BRASS CHROME PLATED BODY, SPLASH MOUNT, WRISTBLADE HANDLES	K-6	DEARBORN, DELTA		1,2,3,9	1/2"	1/2"	2"	2"
SK4	UNDERMOUNT SINK, 1.0GPM, ADA STAFF	CARRIER	CAST BRASS, CHROME PLATED, OPEN GRID STRAINER P.O. PLUG WITH BRASS TAILPIECE	1554	DEARBORN, DELTA						
		MIXING VALVE	LEAD FREE THERMOSTATIC MIXING VALVE - SETPOINT = 105%KDF INSTALL ON HOT WATER SUPPLY, ASSE 1070	HG-135	CASH A/CME						
		BOWL	20x16 VITREOUS CHINA, RIM 3/4" AFF MAX.	K-4991-ETSS-0	ZURN, AMERICAN STANDARD		1,2,3,9	1/2"	1/2"	2"	2"
		FAUCET	4" CENTERSET, SINGLE LEVER HANDLE, SOLID BRASS CONSTRUCTION, CERAMIC CARTRIDGE, HIGH TEMP LIMIT STOP	8413F05	ZURN, DELTA						
SK5	UNDERMOUNT SINK, 1.0GPM, ADA STAFF	CARRIER	CAST BRASS, CHROME PLATED, OPEN GRID STRAINER P.O. PLUG WITH BRASS TAILPIECE	1554	DEARBORN, DELTA						
		MIXING VALVE	LEAD FREE THERMOSTATIC MIXING VALVE - SETPOINT = 105%KDF INSTALL ON HOT WATER SUPPLY, ASSE 1070	HG-135	CASH A/CME						
		BOWL	20x16 VITREOUS CHINA, RIM 3/4" AFF MAX.	K-4991-ETSS-0	ZURN, AMERICAN STANDARD		1,2,3,9	1/2"	1/2"	2"	2"
		FAUCET	4" CENTERSET, SINGLE LEVER HANDLE, SOLID BRASS CONSTRUCTION, CERAMIC CARTRIDGE, HIGH TEMP LIMIT STOP	8413F05	ZURN, DELTA						
SK6	3-COMPARTMENT CORNER STAINLESS STEEL SINK	CARRIER	CAST BRASS, CHROME PLATED, OPEN GRID STRAINER P.O. PLUG WITH BRASS TAILPIECE	1554	DEARBORN, DELTA						
		MIXING VALVE	LEAD FREE THERMOSTATIC MIXING VALVE - SETPOINT = 105%KDF INSTALL ON HOT WATER SUPPLY, ASSE 1070	HG-135	CASH A/CME						
		BOWL	16GA, TYPE 304, 2 DRAINBOARDS	K-4991-ETSS-0	ZURN, AMERICAN STANDARD		1,2,3,9	1/2"	1/2"	2"	2"
		FAUCET	6" SWIVEL GOOSENECK, BRASS CHROME PLATED BODY, SPLASH MOUNT, WRISTBLADE HANDLES	K-6	DEARBORN, DELTA		1,2,3,9	1/2"	1/2"	2"	2"
SH1	JOB-BUILT ROLL IN SHOWER, ADA	CARRIER	SPLASH MOUNT PRERINSE FAUCET, P.O.C., 1/4" TURN HANDLES, SPRAY HEAD WITH CONTINUOUS WATER FLOW RING, HEAVY DUTY SPRING, WALL MOUNT	DTA-53	ZURN, DELTA		1,2,3,9	1/2"	1/2"	2"	2"
		ENCLOSURE	60"x36" JOB-BUILT BY G.C. W/ GRAB BARS per ADA	K-6	DEARBORN, DELTA						
		VALVE	PRESS. BALANCED MIXING VALVE, LEVER HANDLE, DIVERTER, HEAD W/ ARM, FLANGE, WALL/HAND SHOWER, FLEXIBLE METAL HOSE, IN-LINE VAC. BREAKER, 30'SLIDE BAR, 1.5GPM	8342EP15	DELTA, SYMMONS		1/2"	1/2"	2"	2"	2"
		BASE	60"x34 ROLL IN, ACRYLIC, CENTER DRAIN	F603ADPAN							
SH2	JOB-BUILT TRANSFER SHOWER, ADA	ENCLOSURE	36"x36" TRANSFER SHOWER, JOB-BUILT BY G.C.	AQUATIC							
		VALVE	PRESS. BALANCED MIXING VALVE, LEVER HANDLE, HEAD W/ ARM, FLANGE, 1.5GPM	8375EP15	DELTA, SYMMONS		1/2"	1/2"	2"	2"	2"
		BASE	36"x36" ACRYLIC, CENTER DRAIN	S83636	SMITH, ZURN						
		ENCLOSURE	JOB-BUILT BY G.C.								
SH3	JOB-BUILT SHOWER	VALVE	PRESS. BALANCED MIXING VALVE, LEVER HANDLE, HEAD W/ ARM, FLANGE, 1.5GPM	8375EP15	DELTA, SYMMONS		1/2"	1/2"	2"	2"	2"
		BASE	48"x48" ACRYLIC, CENTER DRAIN, ACRYLIC, 48" ALUMINUM	K-8332-SH	KOHLER, ZURN		1/2"	1/2"	2"	2"	2"
		DRAIN COVER	ROUND SHOWER DRAIN, POLISHED CHROME FINISH	K-8332-CP	KOHLER, ZURN						
		DRAIN	ADA COMPLIANT, 2" DRAIN HOSE, 2 FOOT FLEX STATIONS, COLOR SELECTION BY ARCHITECT	K-8332-CP	KOHLER, ZURN						
SH4	FLOOR MOUNT SERVICE SINK	CARRIER	23"x22"x12" MOLDED STONE w/ GRID DRAIN	FIAT	SWANSTONE, MUSTEE		1/2"	1/2"	-	-	-
		FAUCET	CHROME PLATED BRASS, 4" WRIST BLADE HANDLES, VANDAL RESISTANT, CERAMIC CARTRIDGE	74998	DELTA, ZURN						
		ENCLOSURE	24"x24"x10" MOLDED STONE w/ STAINLESS STEEL DRAIN	MSB-2424	FLORESTONE, ZURN						
		BASE	BRASS CONSTRUCTION, ROUGH CHROME FINISH, INTEGRAL VACUUM BREAKER, INTEGRAL CHECK STOPS, 3/4"THREADED SPOUT, SERVICE STOPS, WALL MOUNT, VANDAL RESISTANT, LEVER HANDLES	8124	DELTA, ZURN		1/2"	1/2"	3"	2"	2"
MS1	MOP SINK	CARRIER	STAINLESS STEEL, THREE STATION MOPBROOM HOLDER	8198	DELTA, ZURN						
		ENCLOSURE	STAINLESS STEEL, HOSE BRACKET WITH 30" HEAVY DUTY RUBBER HOSE, GHT THREADED CONNECTION	8198	DELTA, ZURN						
		FAUCET	PEDESTAL, MOUNTED, STAINLESS BOWL, STAY-OPEN BALL VALVE, THERMOSTATIC MIXING VALVE	L7160	BAYLEIGH, HAWS		1/2"	1/2"	2"	-	-
		ENCLOSURE	SPLIT LEVEL, S.S. TOP, LIGHT GREY BODY, BOTTLE FILLING STATION, 8 GPH @ 90/90/90, 120V/1PH WITH FILTER	G2128LWSLK	KURDAY		1,11	1/2"	1/2"	-	-
EW1	EYEFACE WASH STATION WALL HUNG WATER COOLER, ADA	CARRIER	ADJUSTABLE ABOVE GRATE FLASHING DRAIN, NICKEL BRONZE STRAINER, 5-1/2" ROUND STRAINER	833	ZURN, SMITH		10	-	-	-	-
		ENCLOSURE	PVC BODY, 14"x14" PLASTIC TOP w/ 1/2" GRATE, BEEHIVE STRAINER	861	ZURN, SMITH						
		FAUCET	80"x64" HOPE FRAME WITH HEEL PROOF POLYETHYLENE GRATE - CLASS A	2064HP	ZURN, SMITH						
		ENCLOSURE	15" DIAMETER ROOF DRAIN, ENAMEL COATED CAST IRON BODY, GRAVEL GUARD AND DOME STRAINER, DECK CLAMP	868-1504	ZURN, SMITH						
RD1	OVERFLOW ROOF DRAIN	CARRIER	15" DIAMETER ROOF DRAIN, ENAMEL COATED CAST IRON BODY, GRAVEL GUARD AND DOME STRAINER, DECK CLAMP, INTERNAL WATER DAM	868-1504P	ZURN, SMITH						
		ENCLOSURE	POLISHED CHROME, VACUUM BREAKER, WHEEL HANDLE, 3/4" HOSE THREAD	24	ZURN, PRIER		1/2"	-	-	-	-
		FAUCET	CHROME PLATED BRASS, ANTI-SIPHON, VACUUM BREAKER, REMOVABLE TEE HANDLE, 3/4" HOSE THREAD	65	ZURN, PRIER		3/4"	-	-	-	-
		ENCLOSURE	CHROME PLATED BRASS, ANTI-SIPHON, VACUUM BREAKER, HOT AND COLD, WHEEL HANDLE, 3/4" HOSE THREAD	SRH	ZURN, PRIER		3/4"	-	-	-	-
RH1	ROOF HYDRANT	CARRIER	FREEZELESS, ANTI-SIPHON, VACUUM BREAKER, 3/4" HOSE THREAD	SRH	ZURN, PRIER		8	1"	-	1/8"	-
		ENCLOSURE									
		FAUCET									
		ENCLOSURE									
NOTES	1. PROVIDE MATCHING CAST IRON AND STEEL FLOOR SUPPORT CARRIER WITH BEARING PLATE AND WALL HANGER.										
	2. PROVIDE BRASS 1/2" TAILPIECE, CAST BRASS SLOP JOINT, TRAP WITH CLEANOUT, PROVIDE ADA OFFSET ARRANGEMENT WHERE REQUIRED.										
	3. PROVIDE ADA INSULATION KIT										
	4. COORDINATE ADA MILWOK ENCLOSURE FOR WATER AND DRAIN PIPING UNDER SINK.										
	6. TRIP LEVER OR FLUSH HANDLE TO BE LOCATED ON WIDE SIDE OF STALL OR TOILET ROOM.										
	7. REFER TO PLANS TO DETERMINE WHETHER HORIZONTAL OR VERTICAL CARRIER IS REQUIRED.										
	8. FIELD ROUTE 1" DRAIN TO CLOSEST INDIRECT DRAIN OR SPLIT TO GRADE.										
	9. PROVIDE 1/2" IPS x 3/8" OD ANGLE BRASS STOPS w/ RIGID COPPER RISERS. ALL EXPOSED PIPING SHALL BE CHROME PLATED.										
	10. PROVIDE TRAP PRIMER										
	11. PROVIDE 1/2" IPS x 3/8" O.D. BRASS STOP CONCEALED BEHIND CABINET.										

FORT FISHER
AQUARIUM
RENOVATION
& EXPANSION:
PHASE 1

0 LOGGERHEAD RD,
RE BEACH, NC 28449

NORTH CAROLINA DEPT. OF
NATURAL & CULTURAL RESOURCES

OTO GROUP, LLC.
HIBIT DESIGNER
11 DISCOVERY BOULEVARD
BUN, OHIO 43017
E: 617.760.8690
WWW.OTO.COM

BHF ENGINEERS, PLLC
P. ENGINEER
16 YAUPON DRIVE
WINSTON, NC 28401
E: 910.791.4000
F: 910.791.5266
WWW.BHFENGINEERS.COM
ENSE # P-0506

LIGHTSWITCH
LIGHTING DESIGNER
1665 INDIANA COURT
SAN JOSE CUCAMONGA, CA 91730
P: 909.360.2900
WWW.LIGHTSWITCH.NET

INSTALL CONSULTING ENGINEERS PLLC
 CIVIL ENGINEER
 102 IRON GATE DRIVE SUITE 102
 WASHINGTON, NC 28412
 E: 910.343.9653
 F: 910.343.9604
 WWW.WNTENGINEERS.COM
 LICENSE # P-3152

SURFACE 678, PA
LANDSCAPE ARCHITECT
101 MORRIS STREET SUITE 150
RHAM, NC 27701
E: 919.419.1199
C: 919.419.1669
WWW.SURFACE678.COM
ENR 10/20/13

HEATHAM & ASSOCIATES, PA
E PROTECTION ENGINEER
2 ENTERPRISE DRIVE
WINSTON, NC 28405
E: 910.452.4210
WWW.CHEATHAMPA.COM
ENSE # C-1073

PALACIO COLLABORATIVE
 COST ESTIMATOR
 9 EMPEROR BOULEVARD SUITE 400
 RHAM, NC 27703
 E: 919.605.8952
 WWW.PALACIOCOLLABORATIVE.COM

NOTE: IF THIS DRAWING IS NOT 30" X 42", IT IS A
REDUCED PRINT. REFER TO GRAPHIC SCALE.

NOT FOR
CONSTRUCTION




**NOT FOR
CONSTRUCTION**

NO.	DATE	DESCRIPTION
1	9-8-25	BID SET

FIRST FLOOR DEMO PLAN

PD1.11


1. SEE ENLARGED PLANS FOR DEMOLITION DETAILS.

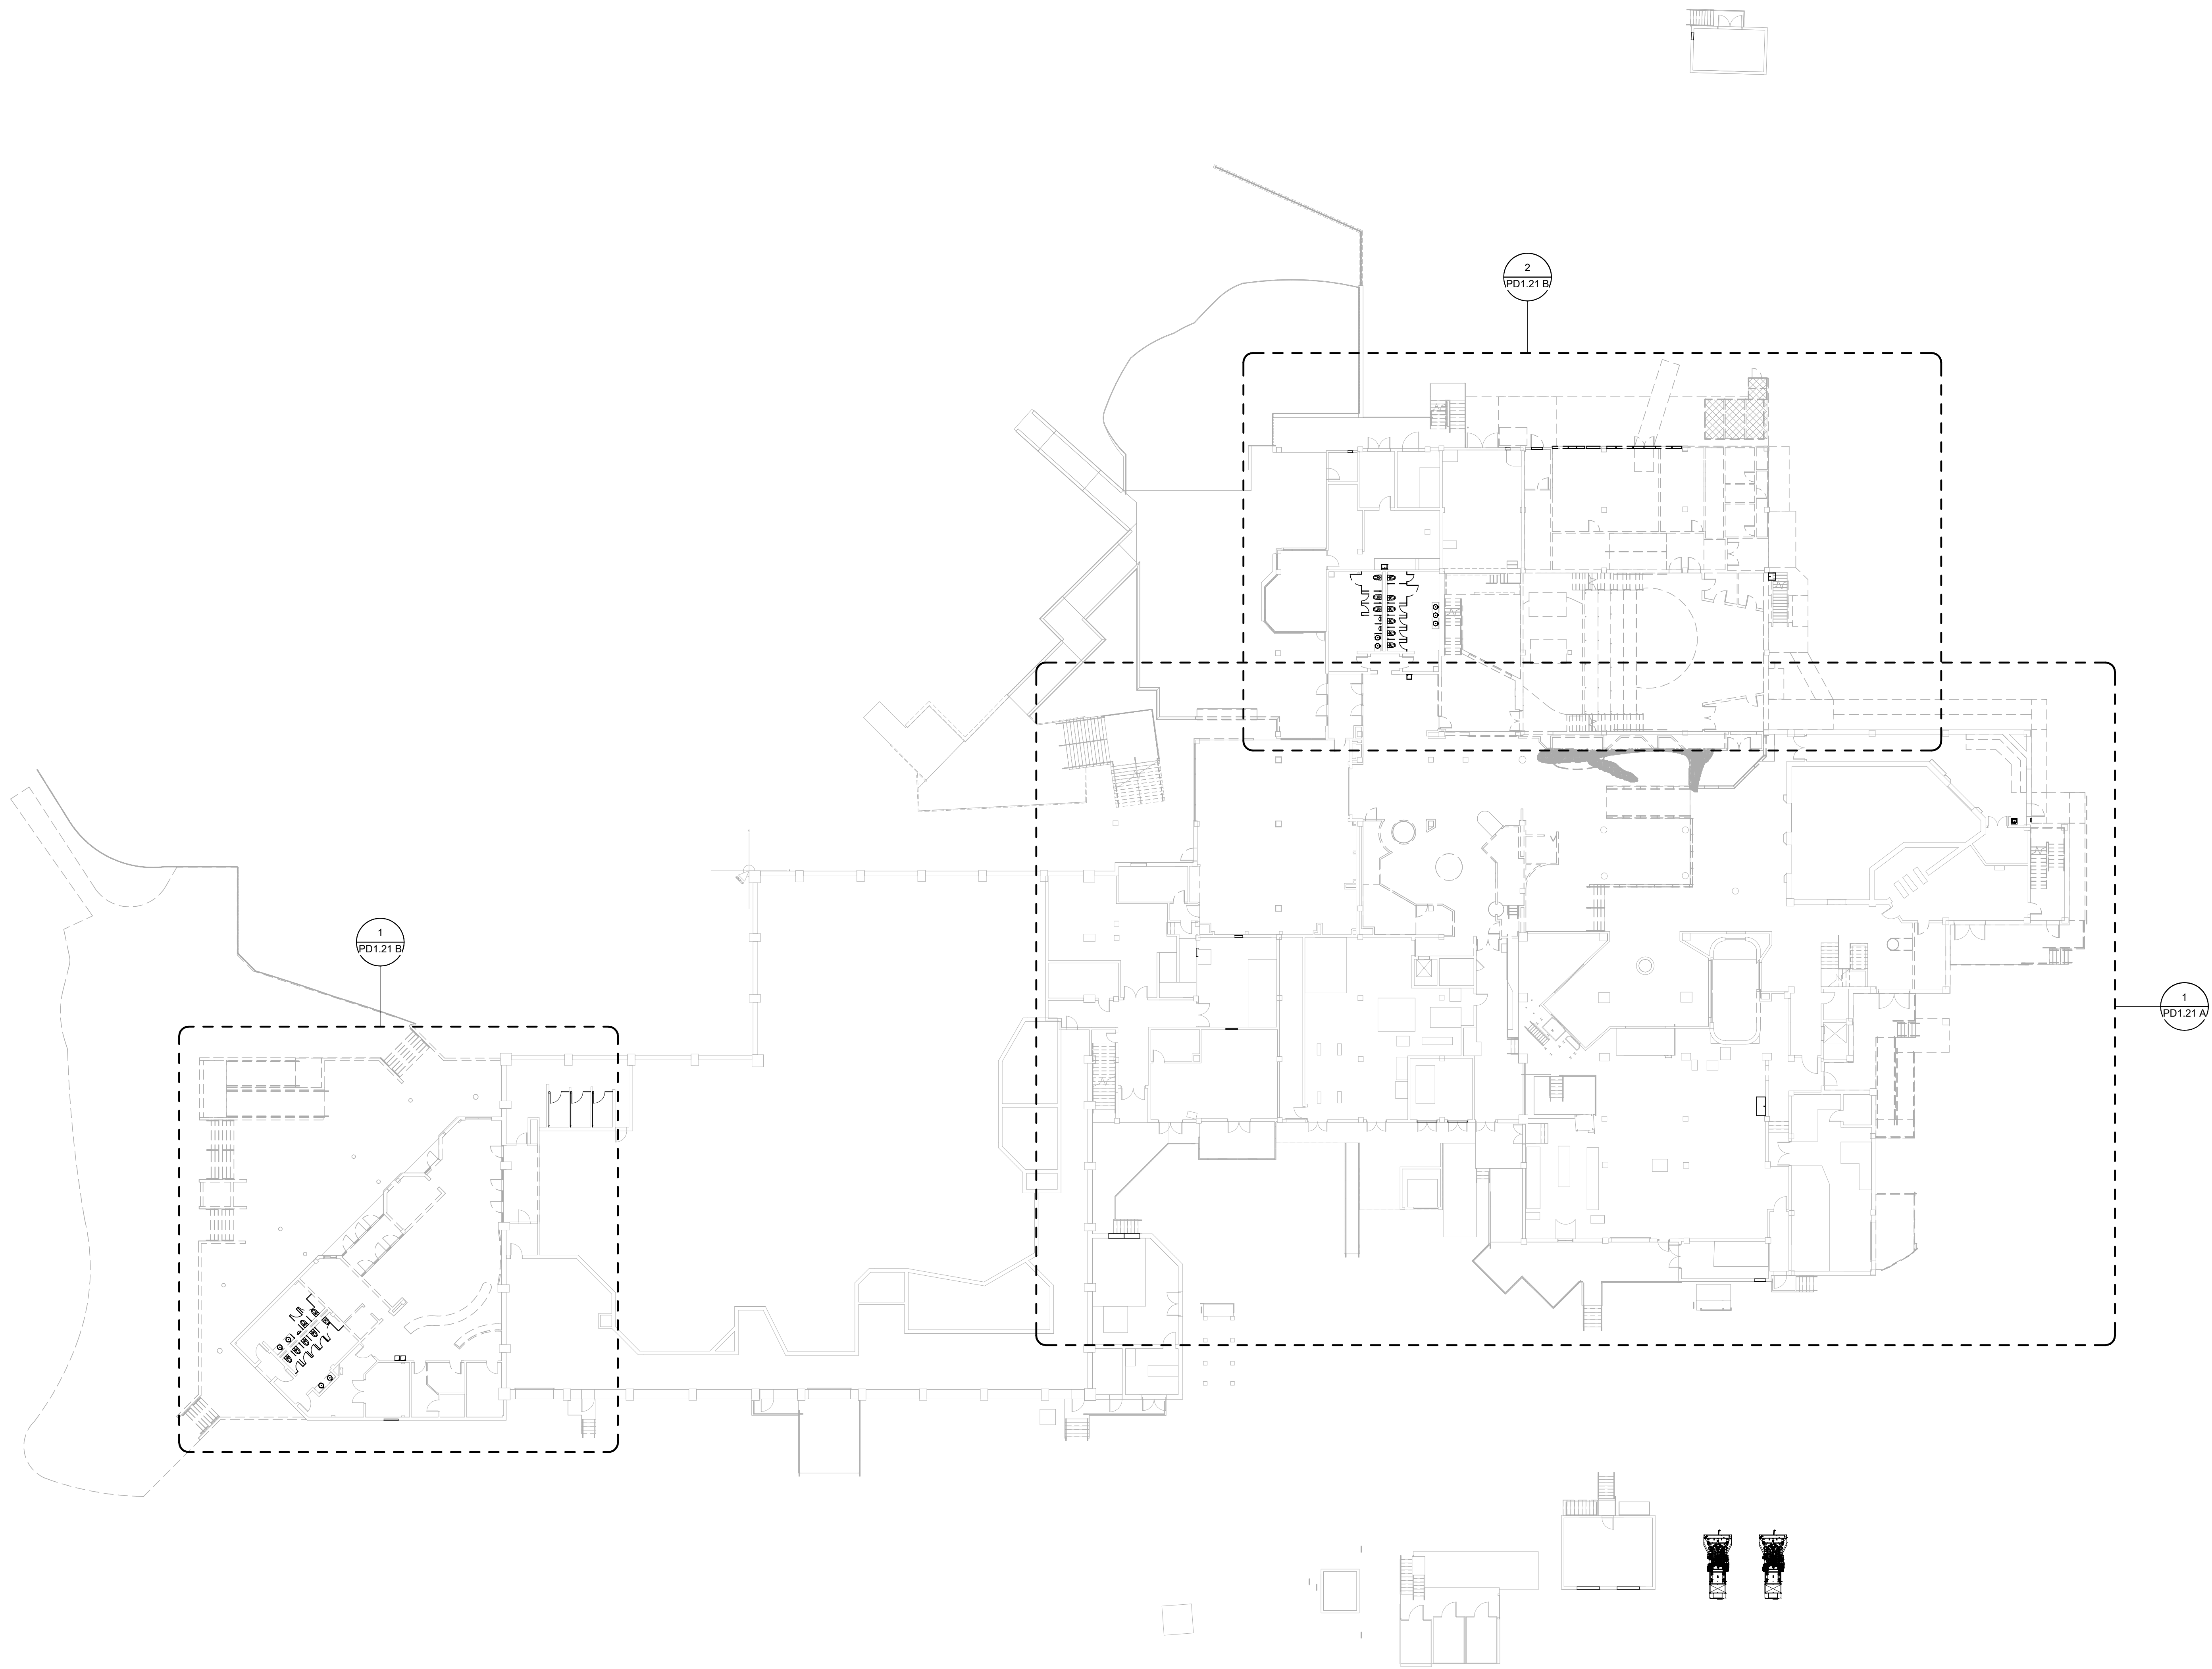

CBHF
Engineers, PLLC

2246 Yaupon Drive
Wilmington, NC 28401
Phone: 910.791.4000
Fax: 910.791.5266
www.cbhfengineers.com
Copyright 2025 CBHF Engineers, PLLC NC# P-050

© Copyright 2025 CBHF Engineers, PLLC NC# P-0506

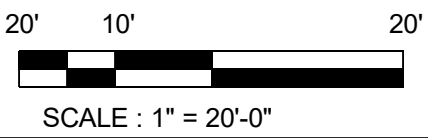

OVERALL 1ST FLOOR - DEMO - WASTE VENT PLAN

SCALE : 1" = 20'-0"

1

SZOSTAK DESIGN

FORT FISHER
AQUARIUM
RENOVATION
& EXPANSION:
PHASE 1

SCO #17-18042-02A
CODE: 42014-4G02
ITEM: 41414-4Y4A

900 LOGGERHEAD RD,
KURE BEACH, NC 28449

NORTH CAROLINA DEPT. OF
NATURAL & CULTURAL RESOURCES

SZOSTAK DESIGN, INC.

ARCHITECT
310 1/2 WEST FRANKLIN STREET
CHAPEL HILL, NORTH CAROLINA 27514
TEL: 919.929.5244
FAX: 919.960.7967
WWW.SZOSTAKDESIGN.COM
LICENSE # 31679

TJP ENGINEERING, INC.

LIFE SUPPORT SYSTEMS ENGINEER
56885 VENTURE LANE SUITE 205H
BEND, OR 97007
TEL: 503.432.0300
WWW.TJPEENGINEERING.COM
LICENSE # C-3505

ROTO GROUP, LLC.

EXHIBIT DESIGNER
7001 DISCOVERY BOULEVARD
DUBLIN, OHIO 43017
TEL: 617.760.6895
WWW.ROTO.COM

BENNETT & PLESS

STRUCTURAL ENGINEER
5430 WADE PARK BOULEVARD SUITE 400
RALEIGH, NC 27607
TEL: 919.832.5587
WWW.BENNETT-PLESS.COM
LICENSE # F-1105

CBHF ENGINEERS, PLLC

MFP ENGINEER
2246 YAUPOIN DRIVE
WILMINGTON, NC 28401
TEL: 910.791.4000
FAX: 910.791.2566
WWW.CBHFENGINEERS.COM
LICENSE # P-6564

LIGHTSWITCH

LIGHTING DESIGNER
10365 INDIANA COURT
RANCHO CUCAMONGA, CA 91730
TEL: 909.360.0000
WWW.LIGHTSWITCH.NET

TUNSTALL CONSULTING ENGINEERS PLLC

CIVIL ENGINEER
2402 BROWN GATE DRIVE SUITE 102
WILMINGTON, NC 28412
TEL: 910.343.9433
FAX: 910.343.9404
WWW.TUNSTALLENGINEERS.COM
LICENSE # F-3132

SURFACE 678, PA

LANDSCAPE ARCHITECT
215 AGRERS STREET SUITE 150
DURHAM, NC 27703
TEL: 919.419.1199
FAX: 919.419.1688
WWW.SURFACE678.COM
LICENSE # C-096

CHEATHAM & ASSOCIATES, PA

FIRE PROTECTION ENGINEER
3413 ENTERPRISE DRIVE
WILMINGTON, NC 28405
TEL: 910.452.4510
WWW.CHEATHAMP.A.COM
LICENSE # C-1073

PALACIO COLLABORATIVE

COST ESTIMATOR
4817 ENTERPRISE BOULEVARD SUITE 400
DURHAM, NC 27703
TEL: 919.403.8910
WWW.PALACIOCOLLABORATIVE.COM

NOTE: IF THIS DRAWING IS NOT 30" X 42", IT IS A
REDUCED PRINT. REFER TO GRAPHIC SCALE.

NOT FOR
CONSTRUCTION

SEAL
23551
ENGINEER
DAVID M. HARR

NOT FOR
CONSTRUCTION


NO.	DATE	DESCRIPTION
1	9-8-25	BID SET

SECOND AND THIRD
FLOOR DEMO PLANS


PD1.12

NOTES THIS SHEET

1. SEE ENLARGED PLANS FOR DEMOLITION DETAILS.

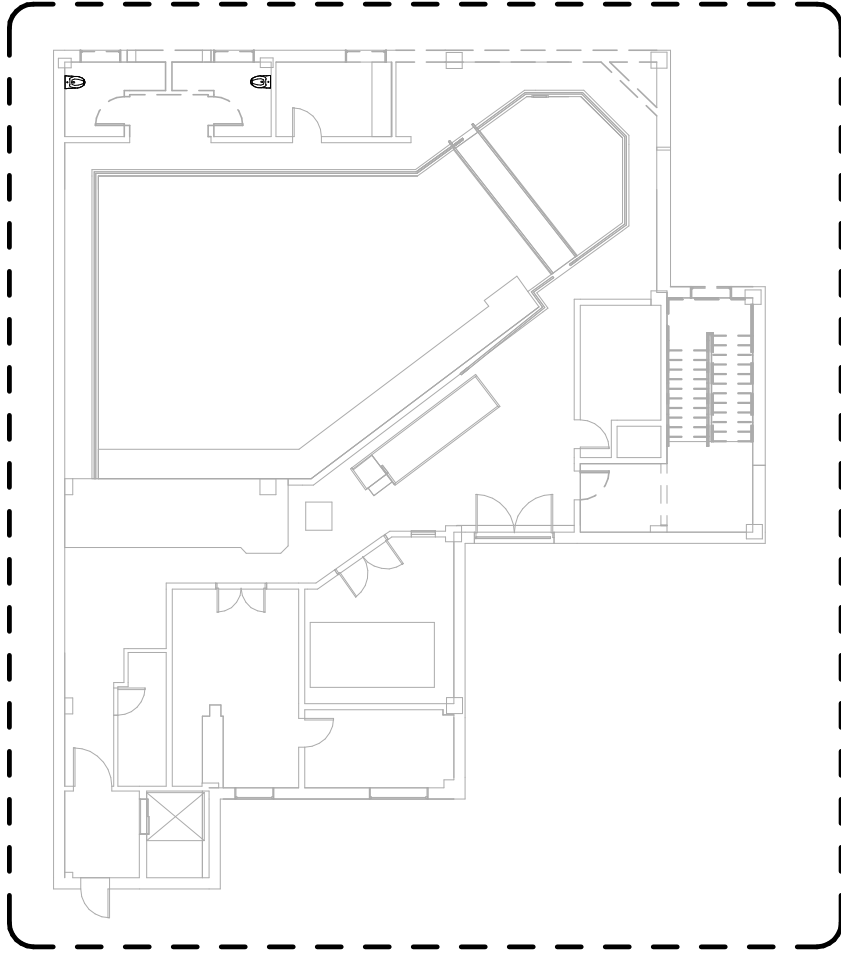


20' 10' 20'
SCALE : 1" = 20'-0"

 


OVERALL 3RD FLOOR - DEMO - WASTE-VENT PLAN
SCALE : 1" = 20'-0"

2

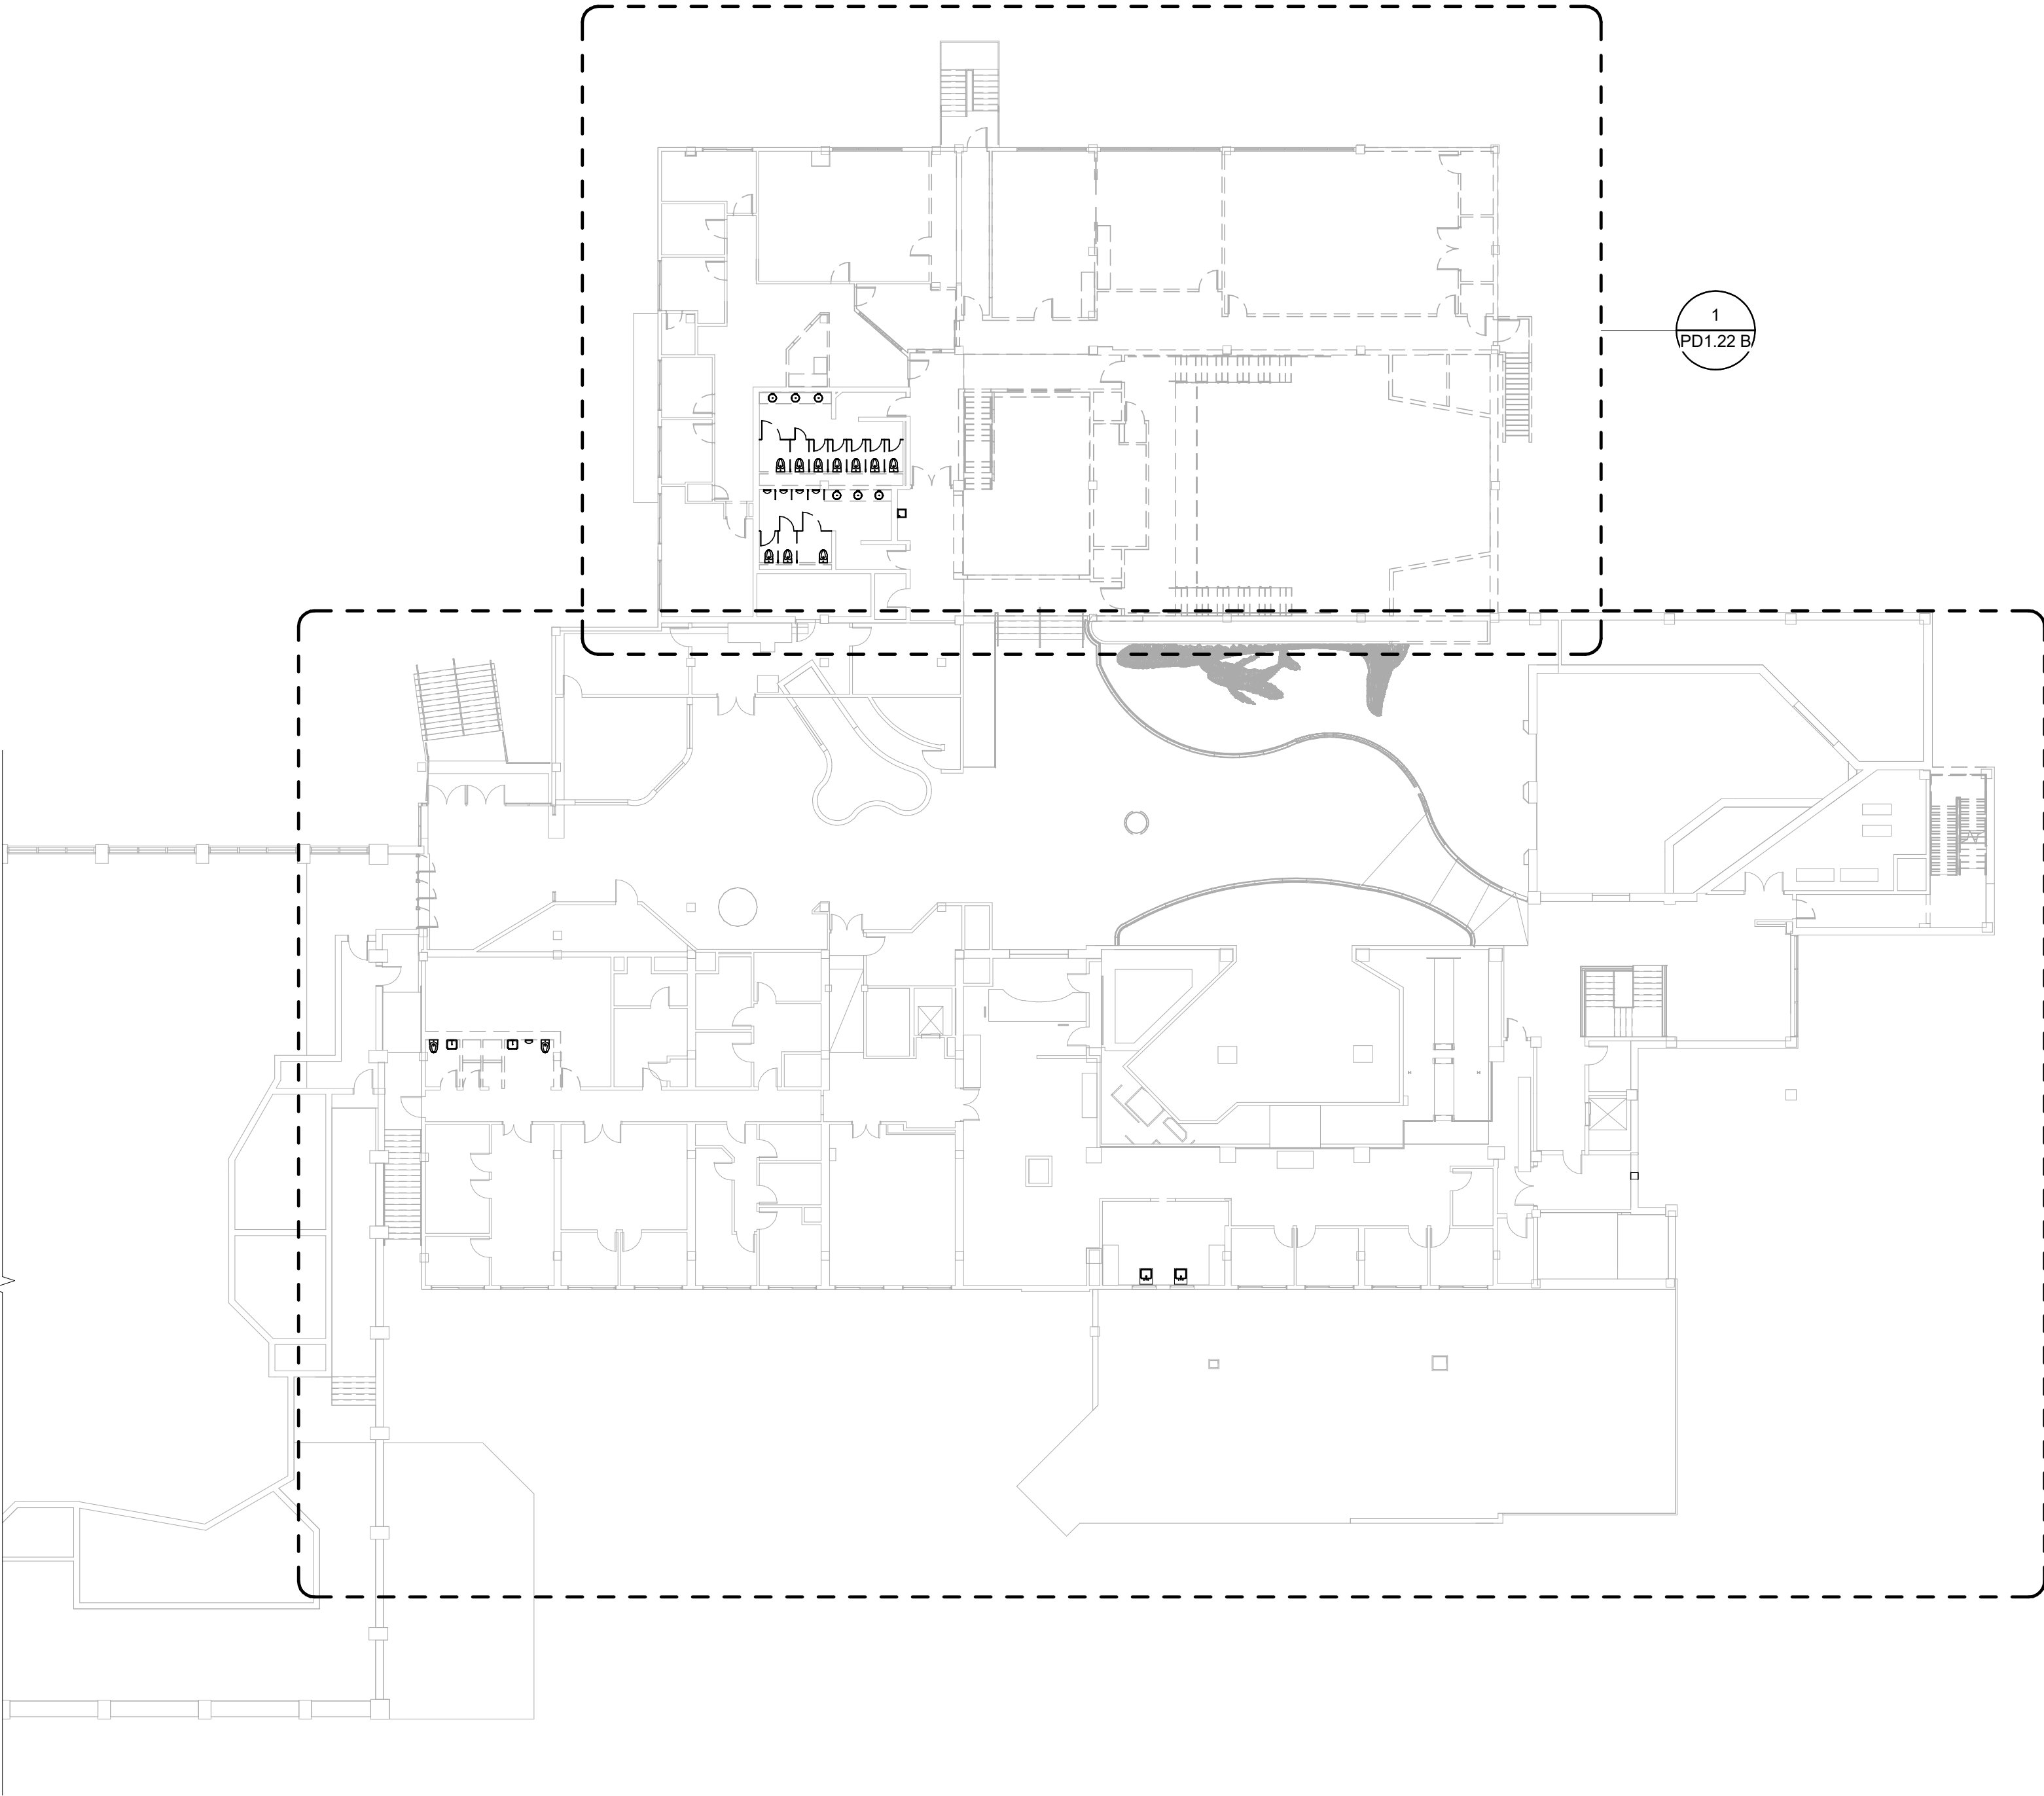

20' 10' 20'
SCALE : 1" = 20'-0"

 



OVERALL 2ND FLOOR - DEMO - WASTE-VENT PLAN
SCALE : 1" = 20'-0"

1

CBHF
Engineers, PLLC

2246 Yaupon Drive
Wilmington, NC 28401
Phone: 910.791.4000
Fax: 910.791.5566
www.cbhfindesign.com
© Copyright 2025 CBHF Engineers, PLLC. NCCE # 0306

KEYNOTES	
1	ALL EXISTING PLUMBING FIXTURES, PIPING, FITTINGS, ETC WITHIN THIS AREA TO BE REMOVED AND PROPERLY DISPOSED OF.
2	EXISTING WASTE PIPING TO BE DEMOLISHED TO END POINT OF DEMOLITION AS INDICATED ON PLAN.
3	EXISTING WATER SERVICE TO BE DEMOLISHED. GC TO COORDINATE KEEPING SERVICE ACTIVE UNTIL NEW WATER SERVICE COMES ONLINE
4	ALL PLUMBING IN MECHANICAL SPACE BELOW AUDITORIUM TO BE DEMOLISHED. EXISTING BOOSTER PUMP TO BE TEMPORARILY RELOCATED AS REQUIRED TO MAINTAIN ADEQUATE PRESSURE UNTIL NEW SERVICE AND BOOSTER PUMP ARE ON LINE
5	EXISTING SERVICE SINK AND ALL ASSOCIATED WASTE, VENT AND WATER PIPING TO BE DEMOLISHED.
6	ALL EXISTING PLUMBING FIXTURES WITHIN THIS SPACE TO BE REMOVED AND PROPERLY DISPOSED OF AS PART OF ALTERNATE #5A.
7	EXISTING DCW PIPING TO BE DEMOLISHED AS PART OF PHASE ONE BASE BID.
8	EXISTING WATER HEATER, DCW AND DHW PIPING TO BE DEMOLISHED AS PART OF PHASE ONE BASE BID.
9	ALL EXISTING PLUMBING FIXTURES, PIPING, FITTINGS, ETC WITHIN THIS AREA TO BE REMOVED AND PROPERLY DISPOSED OF AS PART OF ALTERNATE #2.

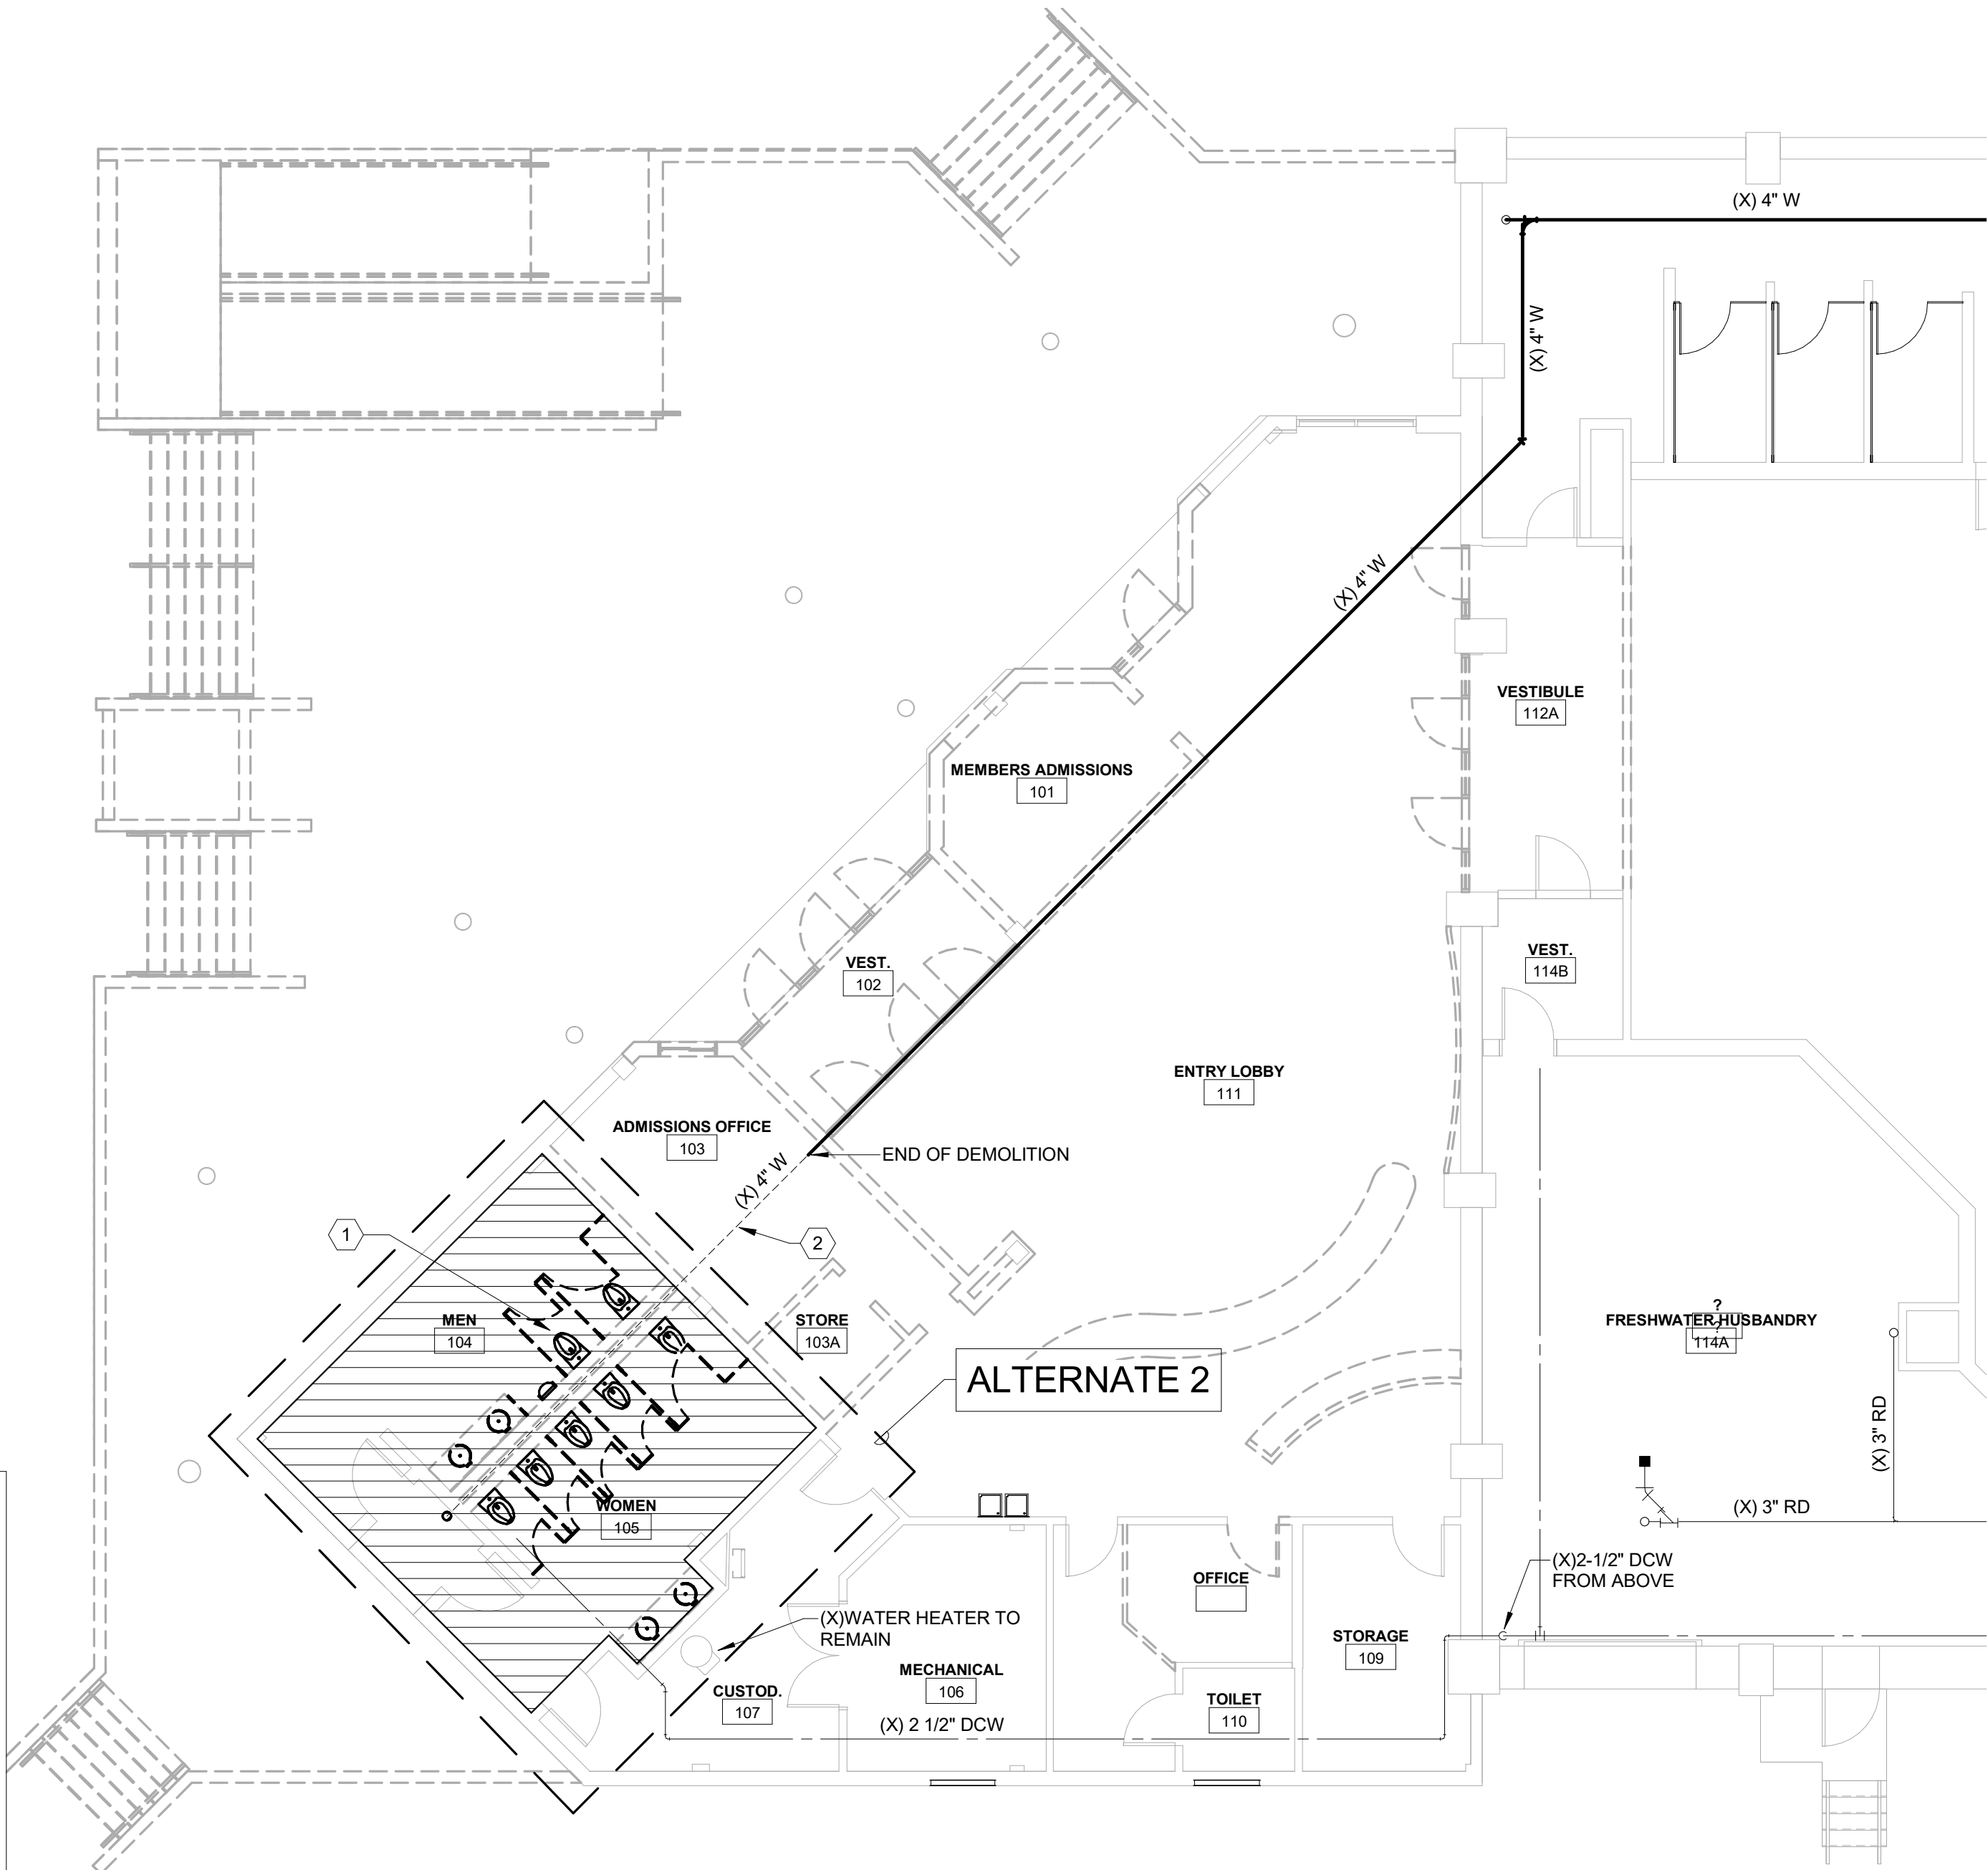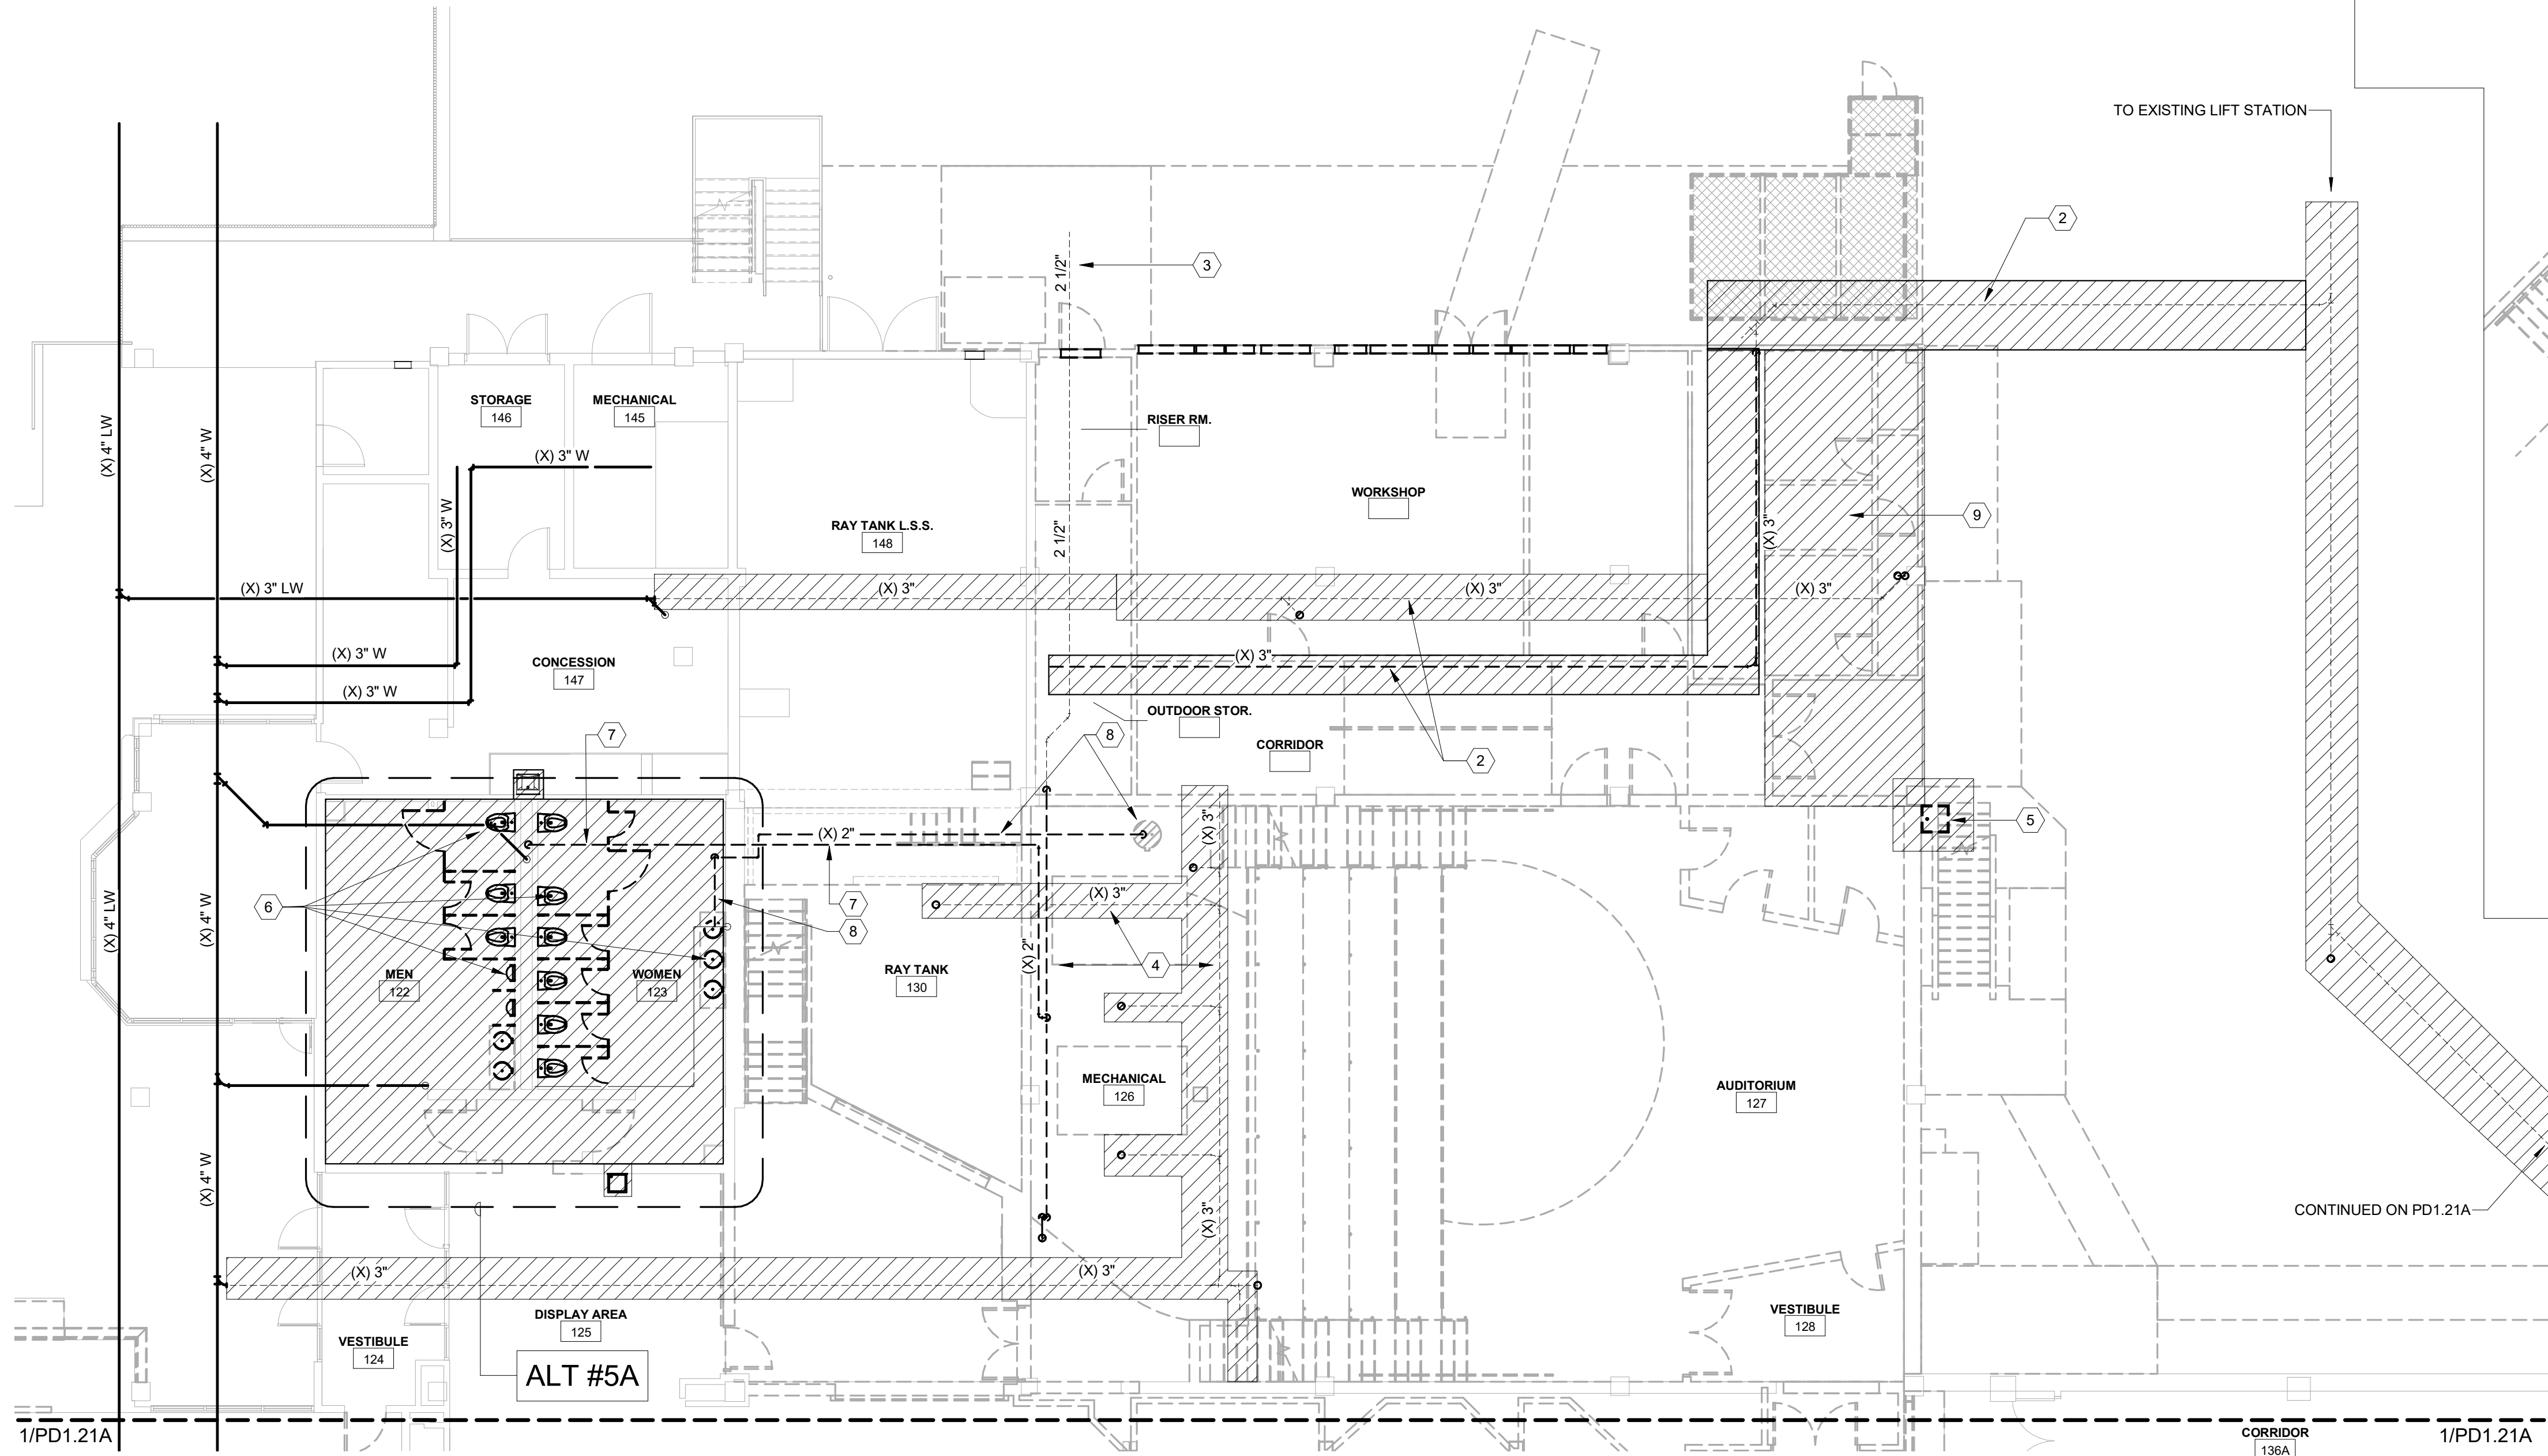

CBHF
Engineers, PLLC
2246 Yaupon Drive
Wilmington, NC 28401
Phone: 910.791.4000
Fax: 910.791.5266
www.cbhfindesign.com
© Copyright 2025 CBHF Engineers, PLLC. NCIA # 0356

DEMOLITION LEGEND
INDICATES AREA OF DEMOLITION

SZOSTAK DESIGN

FORT FISHER
AQUARIUM
RENOVATION
& EXPANSION:
PHASE 1

SCO #17-18042-02A
CODE: 42014-4G02
ITEM: 41414-4Y4A

900 LOGGERHEAD RD,
KURE BEACH, NC 28449

NORTH CAROLINA DEPT. OF
NATURAL & CULTURAL RESOURCES

SZOSTAK DESIGN, INC.

ARCHITECT
310 1/2 WEST FRANKLIN STREET
CHAPEL HILL, NORTH CAROLINA 27514
TEL: 919.929.5244
FAX: 919.960.7967
WWW.SZOSTAKDESIGN.COM
LICENSE # 31079

TJP ENGINEERING, INC.

LIFE SUPPORT SYSTEMS ENGINEER
5680 VENTURE LANE SUITE 205H
BEND, OR 97707
TEL: 419.423.0300
WWW.TJPEENGINEERING.COM
LICENSE # C-3505

ROTO GROUP, LLC.

EXHIBIT DESIGNER
7001 DISCOVERY BOULEVARD
DUBLIN, OHIO 43017
TEL: 617.760.6895
WWW.ROTO.COM

BENNETT & PLESS

STRUCTURAL ENGINEER
5430 WADE PARK BOULEVARD SUITE 400
RALEIGH, NC 27607
TEL: 919.832.5587
WWW.BENNETT-PLESS.COM
LICENSE # F-1105

CBHF ENGINEERS, PLLC

MFP ENGINEER
2246 YAUPOIN DRIVE
WILMINGTON, NC 28401
TEL: 910.791.4000
FAX: 910.791.5266
WWW.CBHFENGINEERS.COM
LICENSE # F-0554

LIGHTSWITCH

LIGHTING DESIGNER
10065 INDIANA COURT
RAICHKO CUCAMONGA, CA 91730
TEL: 909.360.7000
WWW.LIGHTSWITCH.NET

TUNSTALL CONSULTING ENGINEERS PLLC

CIVIL ENGINEER
2402 BROWN GATE DRIVE SUITE 102
WILMINGTON, NC 28412
TEL: 910.343.9433
FAX: 910.343.9404
WWW.TUNSTALLENGINEERS.COM
LICENSE # F-3132

SURFACE 678, PA

LANDSCAPE ARCHITECT

215 AGGERS STREET SUITE 150
DURHAM, NC 27703
TEL: 919.419.1199
FAX: 919.419.1688
WWW.SURFACE678.COM
LICENSE # C-1073

CHEATHAM & ASSOCIATES, PA

RRE PROTECTION ENGINEER
3413 ENTERPRISE DRIVE
WILMINGTON, NC 28405
TEL: 910.452.6110
WWW.CHEATHAMPA.COM
LICENSE # C-1073

PALACIO COLLABORATIVE

COST ESTIMATOR
4815 ENTERPRISE BOULEVARD SUITE 400
DURHAM, NC 27703
TEL: 919.453.9100
WWW.PALACIOCOLLABORATIVE.COM

NOTE: IF THIS DRAWING IS NOT 36" X 42", IT IS A
REDUCED PRINT. REFER TO GRAPHIC SCALE.

NOT FOR
CONSTRUCTION


SEAL
23551
ENGINEER
DAVID M. HAIN

NOT FOR
CONSTRUCTION

NO.	DATE	DESCRIPTION
1	9-8-25	BID SET

FIRST FLOOR DEMO PLAN -
MAIN ENTRY & TOUCH
TANK

PD1.21 B

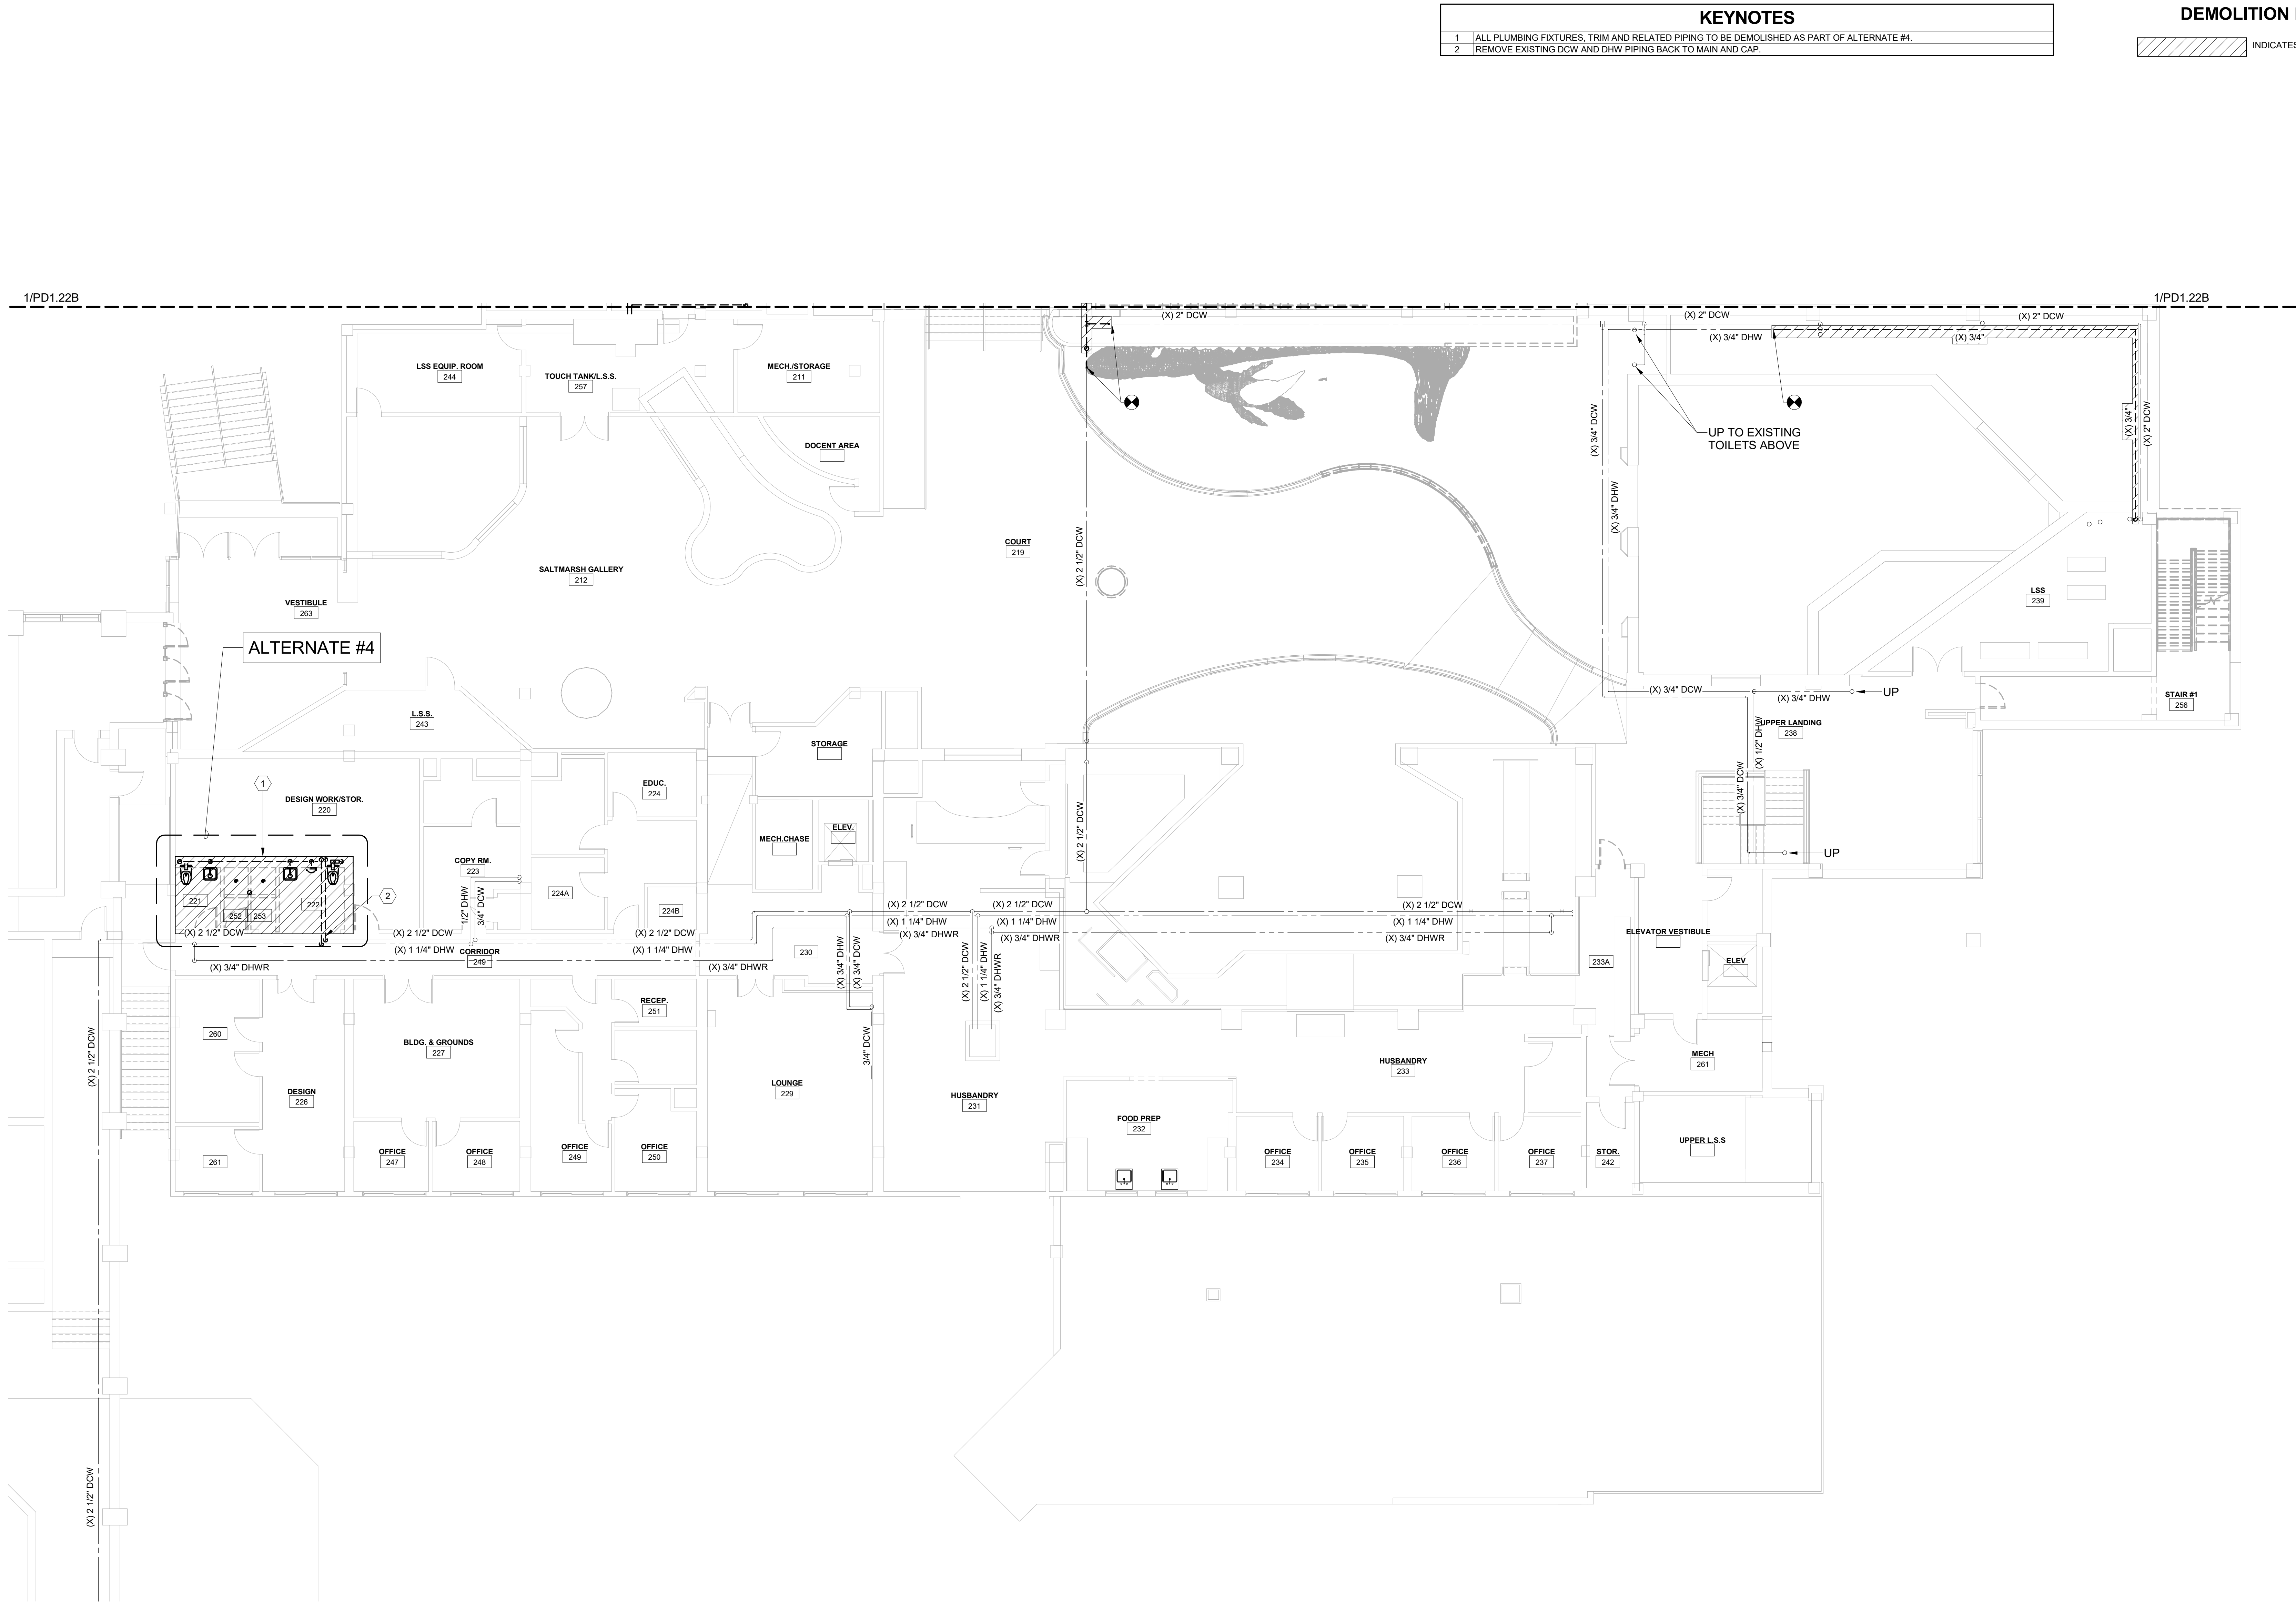

KEYNOTES	
1	ALL PLUMBING FIXTURES, TRIM AND RELATED PIPING TO BE DEMOLISHED AS PART OF ALTERNATE #4.
2	REMOVE EXISTING DCW AND DHW PIPING BACK TO MAIN AND CAP.

DEMOLITION LEGEND	
	INDICATES AREA OF DEMOLITION

SZOSTAK DESIGN

FORT FISHER
AQUARIUM
RENOVATION
& EXPANSION:
PHASE 1

SCO #17-18042-02A
CODE: 42014-4G02
ITEM: 41414-4Y4A

900 LOGGERHEAD RD,
KURE BEACH, NC 28449

NORTH CAROLINA DEPT. OF
NATURAL & CULTURAL RESOURCES

SZOSTAK DESIGN, INC.

ARCHITECT
310 1/2 WEST FRANKLIN STREET
CHAPEL HILL, NORTH CAROLINA 27514
TEL: 919.929.5244
FAX: 919.960.7967
WWW.SZOSTAKDESIGN.COM
LICENSE # 31679

TJP ENGINEERING, INC.

LIFE SUPPORT SYSTEMS ENGINEER
5680 VENTURE LAKE SUITE 205N
BEND, OR 97707
TEL: 414.433.0300
WWW.TJPEENGINEERING.COM
LICENSE # C-3505

ROTO GROUP, LLC.

EXHIBIT DESIGNER
7001 DISCOVERY BOULEVARD
DURHAM, NC 27707
TEL: 817.760.6895
WWW.ROTO.COM

BENNETT & PLESS

STRUCTURAL ENGINEER
5430 WADE PARK BOULEVARD SUITE 400
RALEIGH, NC 27607
TEL: 919.832.5587
WWW.BENNETT-PLESS.COM
LICENSE # F-1105

CBHF ENGINEERS, PLLC

MEP ENGINEER
2246 YAUPOIN DRIVE
WILMINGTON, NC 28401
TEL: 910.791.4000
FAX: 910.791.2556
WWW.CBHFENGINEERS.COM
LICENSE # P-6564

LIGHTSWITCH

LIGHTING DESIGNER
10365 INDIANA COURT
RANCHO CUCAMONGA, CA 91730
TEL: 909.360.7000
WWW.LIGHTSWITCH.NET

TUNSTALL CONSULTING ENGINEERS PLLC

CIVIL ENGINEER
2402 BROWN GATE DRIVE SUITE 102
WILMINGTON, NC 28412
TEL: 910.343.9423
FAX: 910.343.9404
WWW.ANENGINEERS.COM
LICENSE # P-3132

SURFACE 678, PA

LANDSCAPE ARCHITECT
215 MORRIS STREET SUITE 150
DURHAM, NC 27703
TEL: 919.419.1199
FAX: 919.419.1689
WWW.SURFACE678.COM
LICENSE # C-098

CHEATHAM & ASSOCIATES, PA

FIRE PROTECTION ENGINEER
3412 ENTERPRISE DRIVE
WILMINGTON, NC 28405
TEL: 910.452.6110
WWW.CHEATHAMP.A.COM
LICENSE # C-1073

PALACIO COLLABORATIVE

COST ESTIMATOR
4817 ENTERPRISE BOULEVARD SUITE 400
DURHAM, NC 27703
TEL: 919.453.9100
WWW.PALACIOCOLLABORATIVE.COM

NOTE: IF THIS DRAWING IS NOT 30" X 42", IT IS A
REDUCED PRINT. REFER TO GRAPHIC SCALE.

NOT FOR
CONSTRUCTION



NOT FOR
CONSTRUCTION

NO.	DATE	DESCRIPTION
-----	------	-------------



1	9-8-25	BID SET

SECOND FLOOR DEMO
PLAN - CAPE FEAR

PD1.22 A

CBHF
Engineers, PLLC

 2246 Yaupon Drive
Wilmington, NC 28401
Phone: 910.791.4000
Fax: 910.791.5566
www.cbhfengineers.com
© Copyright 2025 CBHF Engineers, PLLC. NCIA P-0356

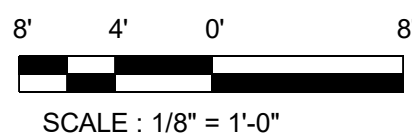

2ND FLOOR - DEMO - CAPE FEAR

SCALE: 1/8" = 1'-0"

KEYNOTES	
1	EXISTING DOMESTIC WATER PIPING TO BE DEMOLISHED.
2	ALL EXISTING PLUMBING FIXTURES, PIPING, FITTINGS, ETC WITHIN THIS AREA TO BE REMOVED AND PROPERLY DISPOSED OF AS PART OF ALTERNATE #5B.

 INDICATES AREA OF DEMOLITION

FORT FISHER
AQUARIUM
RENOVATION
& EXPANSION:
PHASE 1

SCO #17-18042-02A
CODE: 42014-4G02
ITEM: 41414-4Y4A

900 LOGGERHEAD RD,
KURE BEACH, NC 28449

NORTH CAROLINA DEPT. OF
NATURAL & CULTURAL RESOURCES

SZOSTAK DESIGN, INC.

ARCHITECT
310 1/2 WEST FRANKLIN STREET
CHAPEL HILL, NORTH CAROLINA 27516
TELE: 919.929.5244
FAX: 919.960.7967
WWW.S2OSTAKDESIGN.COM
LICENSE # 51679

TJP ENGINEERING, INC.

LIFE SUPPORT SYSTEMS ENGINEER
56880 VENTURE LANE SUITE 205N
BEND, OR 97707
TELE: 619.423.8700
WWW.TJPEENGINEERING.COM
LICENSE # C-3505

ROTO GROUP, LLC.

EXHIBIT DESIGNER
7001 DISCOVERY BOULEVARD
DUBLIN, OHIO 43017
TELE: 617.760.8690
WWW.ROTO.COM

BENNETT & PLESS

STRUCTURAL ENGINEER
5430 WADE PARK BOULEVARD SUITE 400
RALEIGH, NC 27607
TELE: 919.832.5587
WWW.BENNETT-PLESS.COM
LICENSE # F-1105

CBHF ENGINEERS, PLLC

MEP ENGINEER
2246 YALPON DRIVE
WILMINGTON, NC 28401
TEL: 910.791.4000
FAX: 910.791.5266
WWW.CNHEENGINEERS.COM
LARRY H. HENDERSON, P.E.

LIGHTSWITCH

LIGHTING DESIGNER
10265 INDIANA COURT
RANCHO CUCAMONGA, CA 91730
TELE: 909.360.2900
WWW.LIGHTSWITCH.NET

TUNSTALL CONSULTING ENGINEERS PLLC

CIVIL ENGINEER
2602 IRON GATE DRIVE SUITE 102
WILMINGTON, NC 28412
TELE: 910.343.9653
FAX: 910.343.9604
WWW.ENTENGINEERS.COM
LICENSE # P-3152

SURFACE 678, PA

LANDSCAPE ARCHITECT
215 MORRIS STREET SUITE 150
DURHAM, NC 27701
TEL: 919.419.1199
FAX: 919.419.1669
WWW.SURFACE678.COM
LICENSE # C-098

CHEATHAM & ASSOCIATES, PA

FIRE PROTECTION ENGINEER
3412 ENTERPRISE DRIVE
WILMINGTON, NC 28405
TEL: 910.452.4210
WWW.CHEATHAMPA.COM
LICENSE # C-1073

PALACIO COLLABORATIVE

COST ESTIMATOR
4819 EMPEROR BOULEVARD SUITE 400
DURHAM, NC 27703
TELE: 919.605.8952
WWW.PALACIOCOLLABORATIVE.COM

NOTE: IF THIS DRAWING IS NOT 30" X 42", IT IS A
REDUCED PRINT. REFER TO GRAPHIC SCALE.


NOT FOR
CONSTRUCTION

**NOT FOR
CONSTRUCTION**

NO.	DATE	DESCRIPTION
1	9-8-25	BID SET

SECOND FLOOR DEMO
PLAN - TOUCH TANK

PD1.22 B

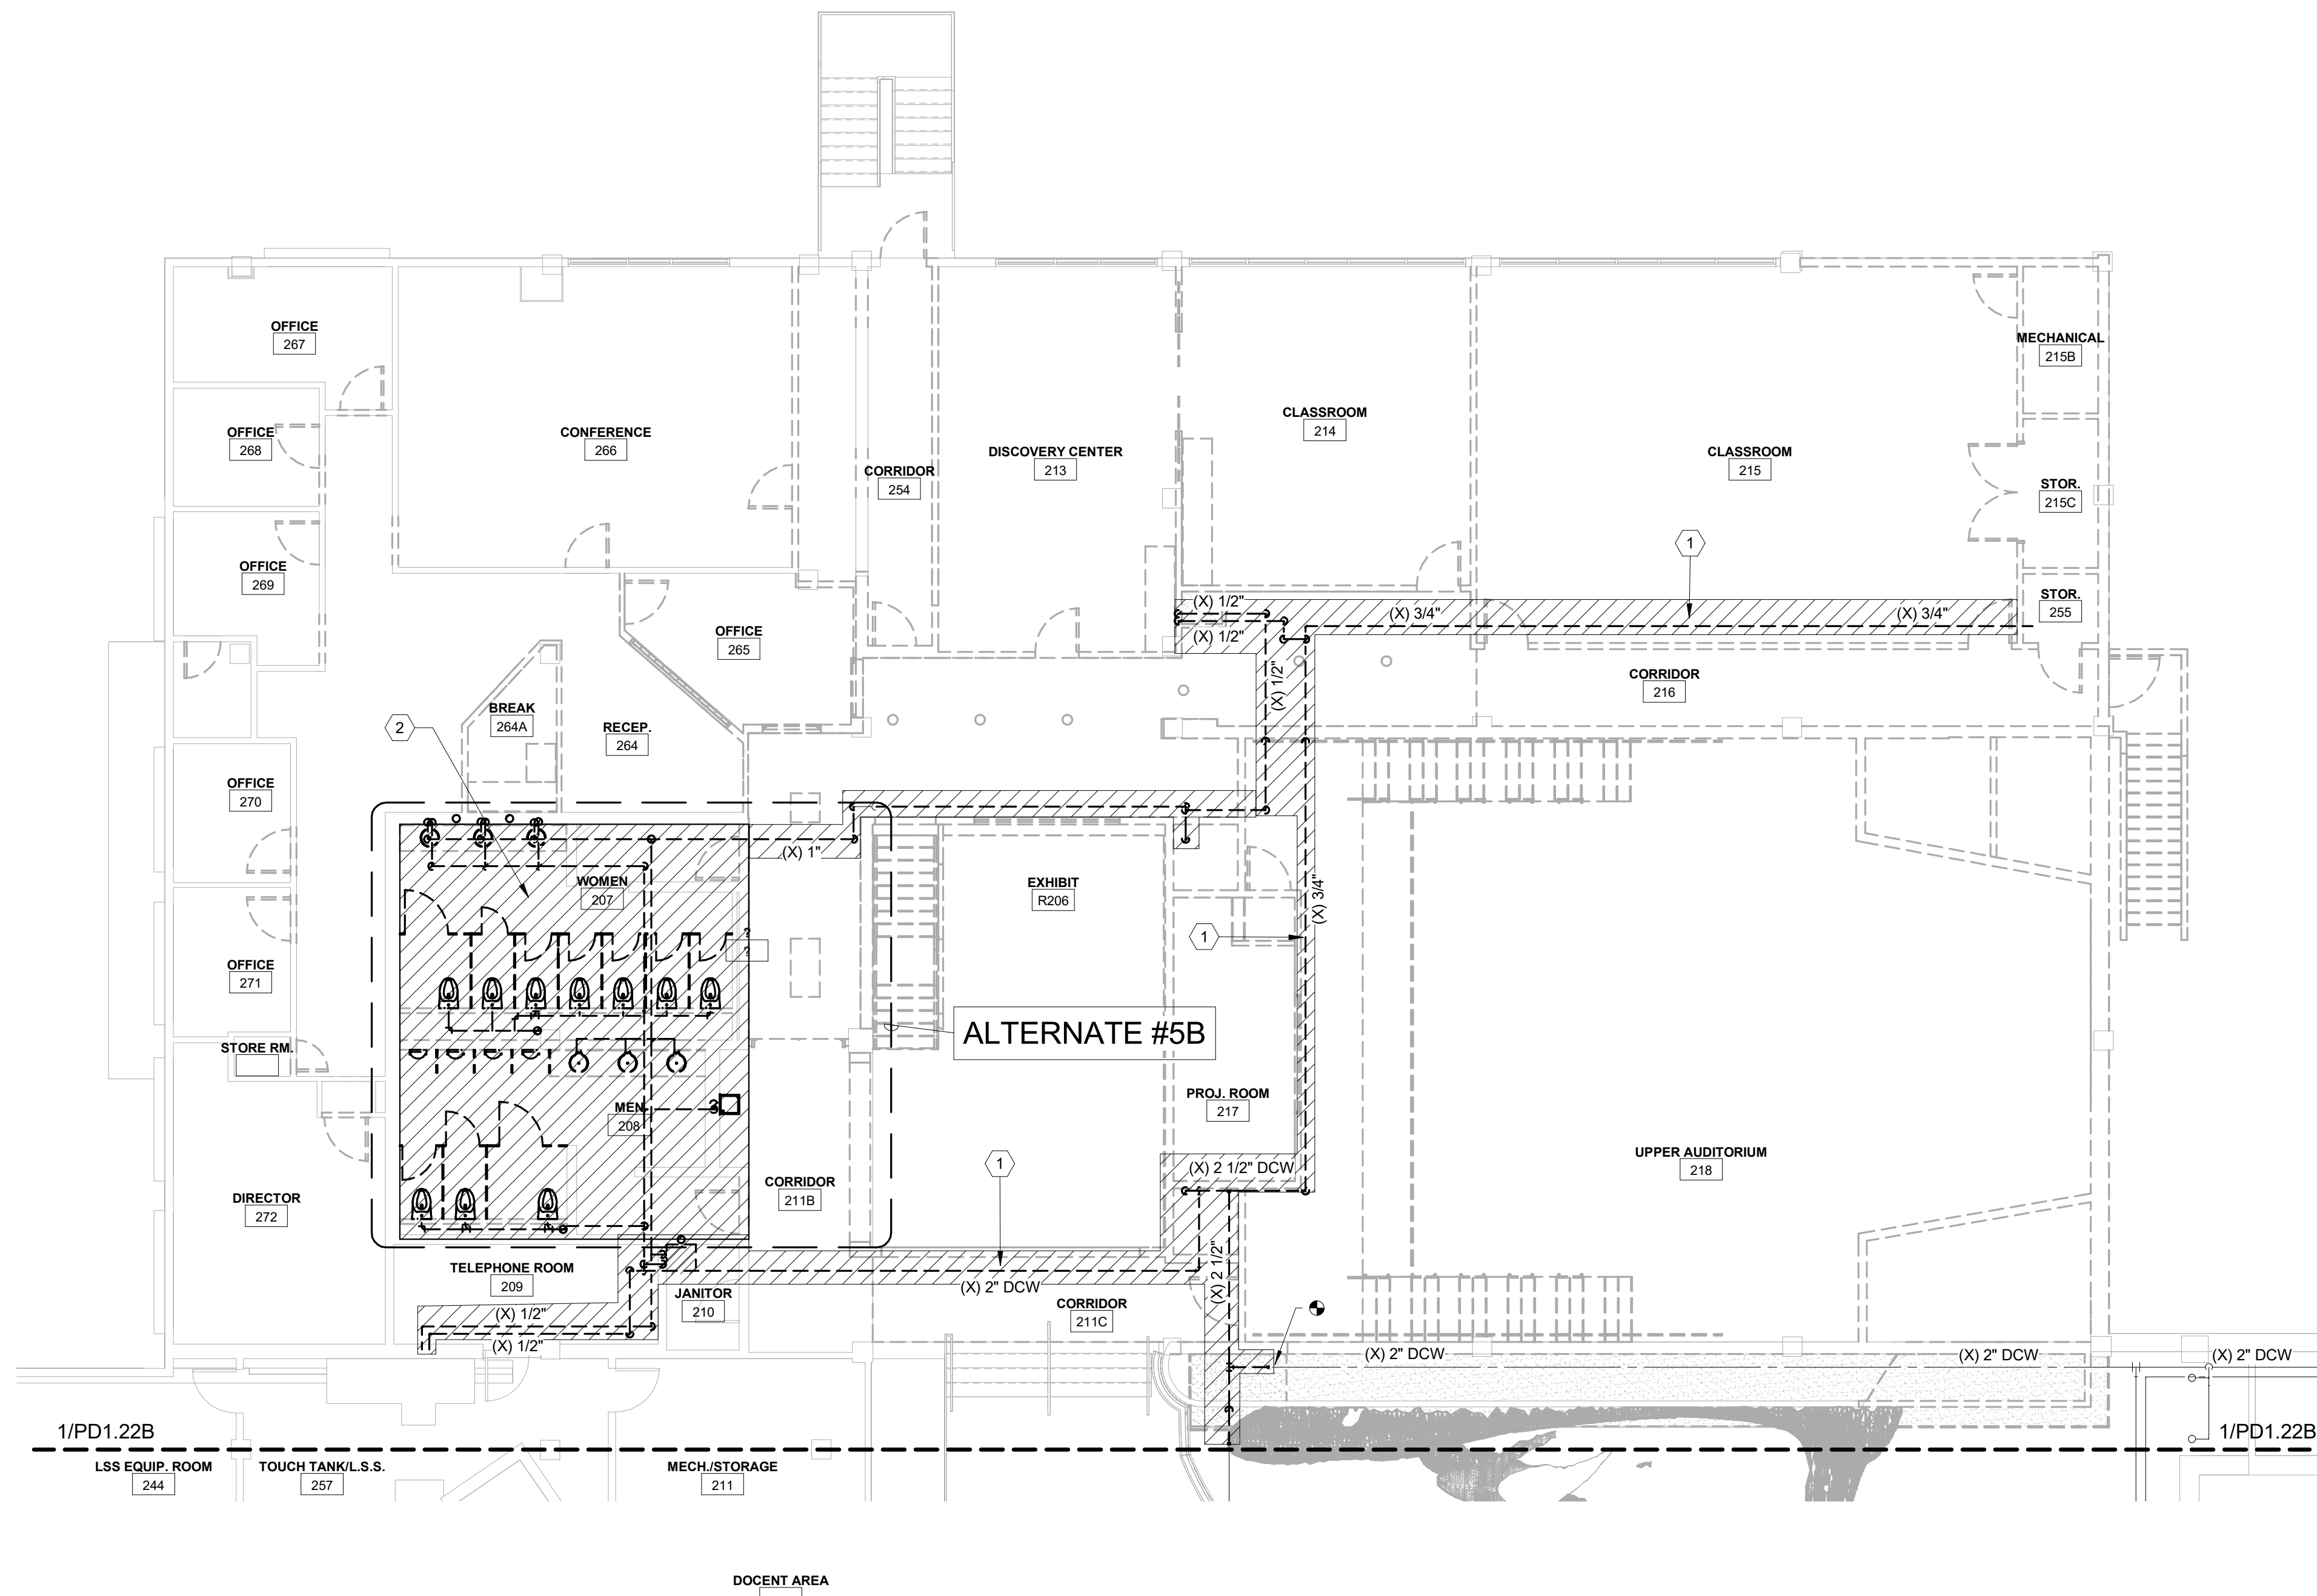

CBHF
Engineers, PLLC

2246 Yaupon Drive
Wilmington, NC 28401
Phone: 910.791.4000
Fax: 910.791.5266
www.cbhfengineers.com
Copyright 2025 CBHF Engineers, PLLC NC# P-0506

© Copyright 2025 CBHF Engineers, PLLC NC# P-0506

8' 4' 0' 8'



SCALE : 1/8" = 1'-0"

2ND FLOOR - DEMO - TOUCH AND SHARK TANK

SCALE : 1/8" = 1'-0"

1

KEYNOTES	
1	ALL EXISTING PLUMBING FIXTURES , TRIM, ETC. WITHIN THIS AREA TO BE DEMOLISHED. EXISTING PIPING TO REMAIN AND BE RE-USED.

1	ALL EXISTING PLUMBING FIXTURES , TRIM, ETC. WITHIN THIS AREA TO BE DEMOLISHED. EXISTING PIPING TO REMAIN AND BE RE-USED.
---	--

 INDICATES AREA OF DEMOLITION

FORT FISHER
AQUARIUM
RENOVATION
& EXPANSION:
PHASE 1

SCO #17-18042-02A
CODE: 42014-4G02
ITEM: 41414-4Y4A

900 LOGGERHEAD RD,
KURE BEACH, NC 28449

NORTH CAROLINA DEPT. OF
NATURAL & CULTURAL RESOURCES

SZOSTAK DESIGN, INC.

ARCHITECT
310 1/2 WEST FRANKLIN STREET
CHAPEL HILL, NORTH CAROLINA 27516
TELE: 919.929.5244
FAX: 919.960.7967
WWW.SZOSTAKDESIGN.COM
LICENSE # 51679

TJP ENGINEERING, INC.

LIFE SUPPORT SYSTEMS ENGINEER
54880 VENTURE LANE SUITE 205N
BEND, OR 97707
TELE: 619.423.8700
WWW.TJENGINEERING.COM
LICENSE # C-3505

ROTO GROUP, LLC

EXHIBIT DESIGNER
7001 DISCOVERY BOULEVARD
DUBLIN, OHIO 43017
TELE: 617.760.8690
WWW.ROFO.COM

BENNETT & PLESS

STRUCTURAL ENGINEER
5430 WADE PARK BOULEVARD SUITE 40
RALEIGH, NC 27607
TELE: 919.832.5587
WWW.BENNETT-PLESS.COM
LICENSE # F-1105

CBHF ENGINEERS, PLLC

MEP ENGINEER
2246 YALPON DRIVE
WILMINGTON, NC 28401
TELE: 910.791.4000
FAX: 910.791.5266
WWW.CBIFENGINEERS.COM

LIGHTSWITCH

LIGHTING DESIGNER
10265 INDIANA COURT
RANCHO CUCAMONGA, CA 91730
TELE: 909.360.2900
WWW.LIGHTSWITCH.NET

TUNSTALL CONSULTING ENGINEERS PLLC

CIVIL ENGINEER
2602 IRON GATE DRIVE SUITE 10
WILMINGTON, NC 28412
TELE: 910.343.9653
FAX: 910.343.9604
WWW.ITEENGINEERS.COM
LICENSE # P-3152

SURFACE 678, PA

LANDSCAPE ARCHITECT
215 MORRIS STREET SUITE 150
DURHAM, NC 27701
TELE: 919.419.1199
FAX: 919.419.1669
WWW.SURFACE678.COM
LIFE: J. C. 000

CHEATHAM & ASSOCIATES, PA

FIRE PROTECTION ENGINEER
3412 ENTERPRISE DRIVE
WILMINGTON, NC 28405
TELE: 910.452.4210
WWW.CHEATHAMPA.COM
LICENSE # C-1073

PALACIO COLLABORATIVE

COST ESTIMATOR
4819 EMPEROR BOULEVARD SUITE 400
DURHAM, NC 27703
TELE: 919.605.8952
WWW.PALACIOCOLLABORATIVE.COM

NOTE: IF THIS DRAWING IS NOT 30" X 42", IT IS A REDUCED PRINT. REFER TO GRAPHIC SCALE.


NOT FOR
CONSTRUCTION

**NOT FOR
CONSTRUCTION**

NO.	DATE	DESCRIPTION
1	9-8-25	BID SET

THIRD FLOOR DEMO PLAN
- CAPE FEAR

PD1.23 A

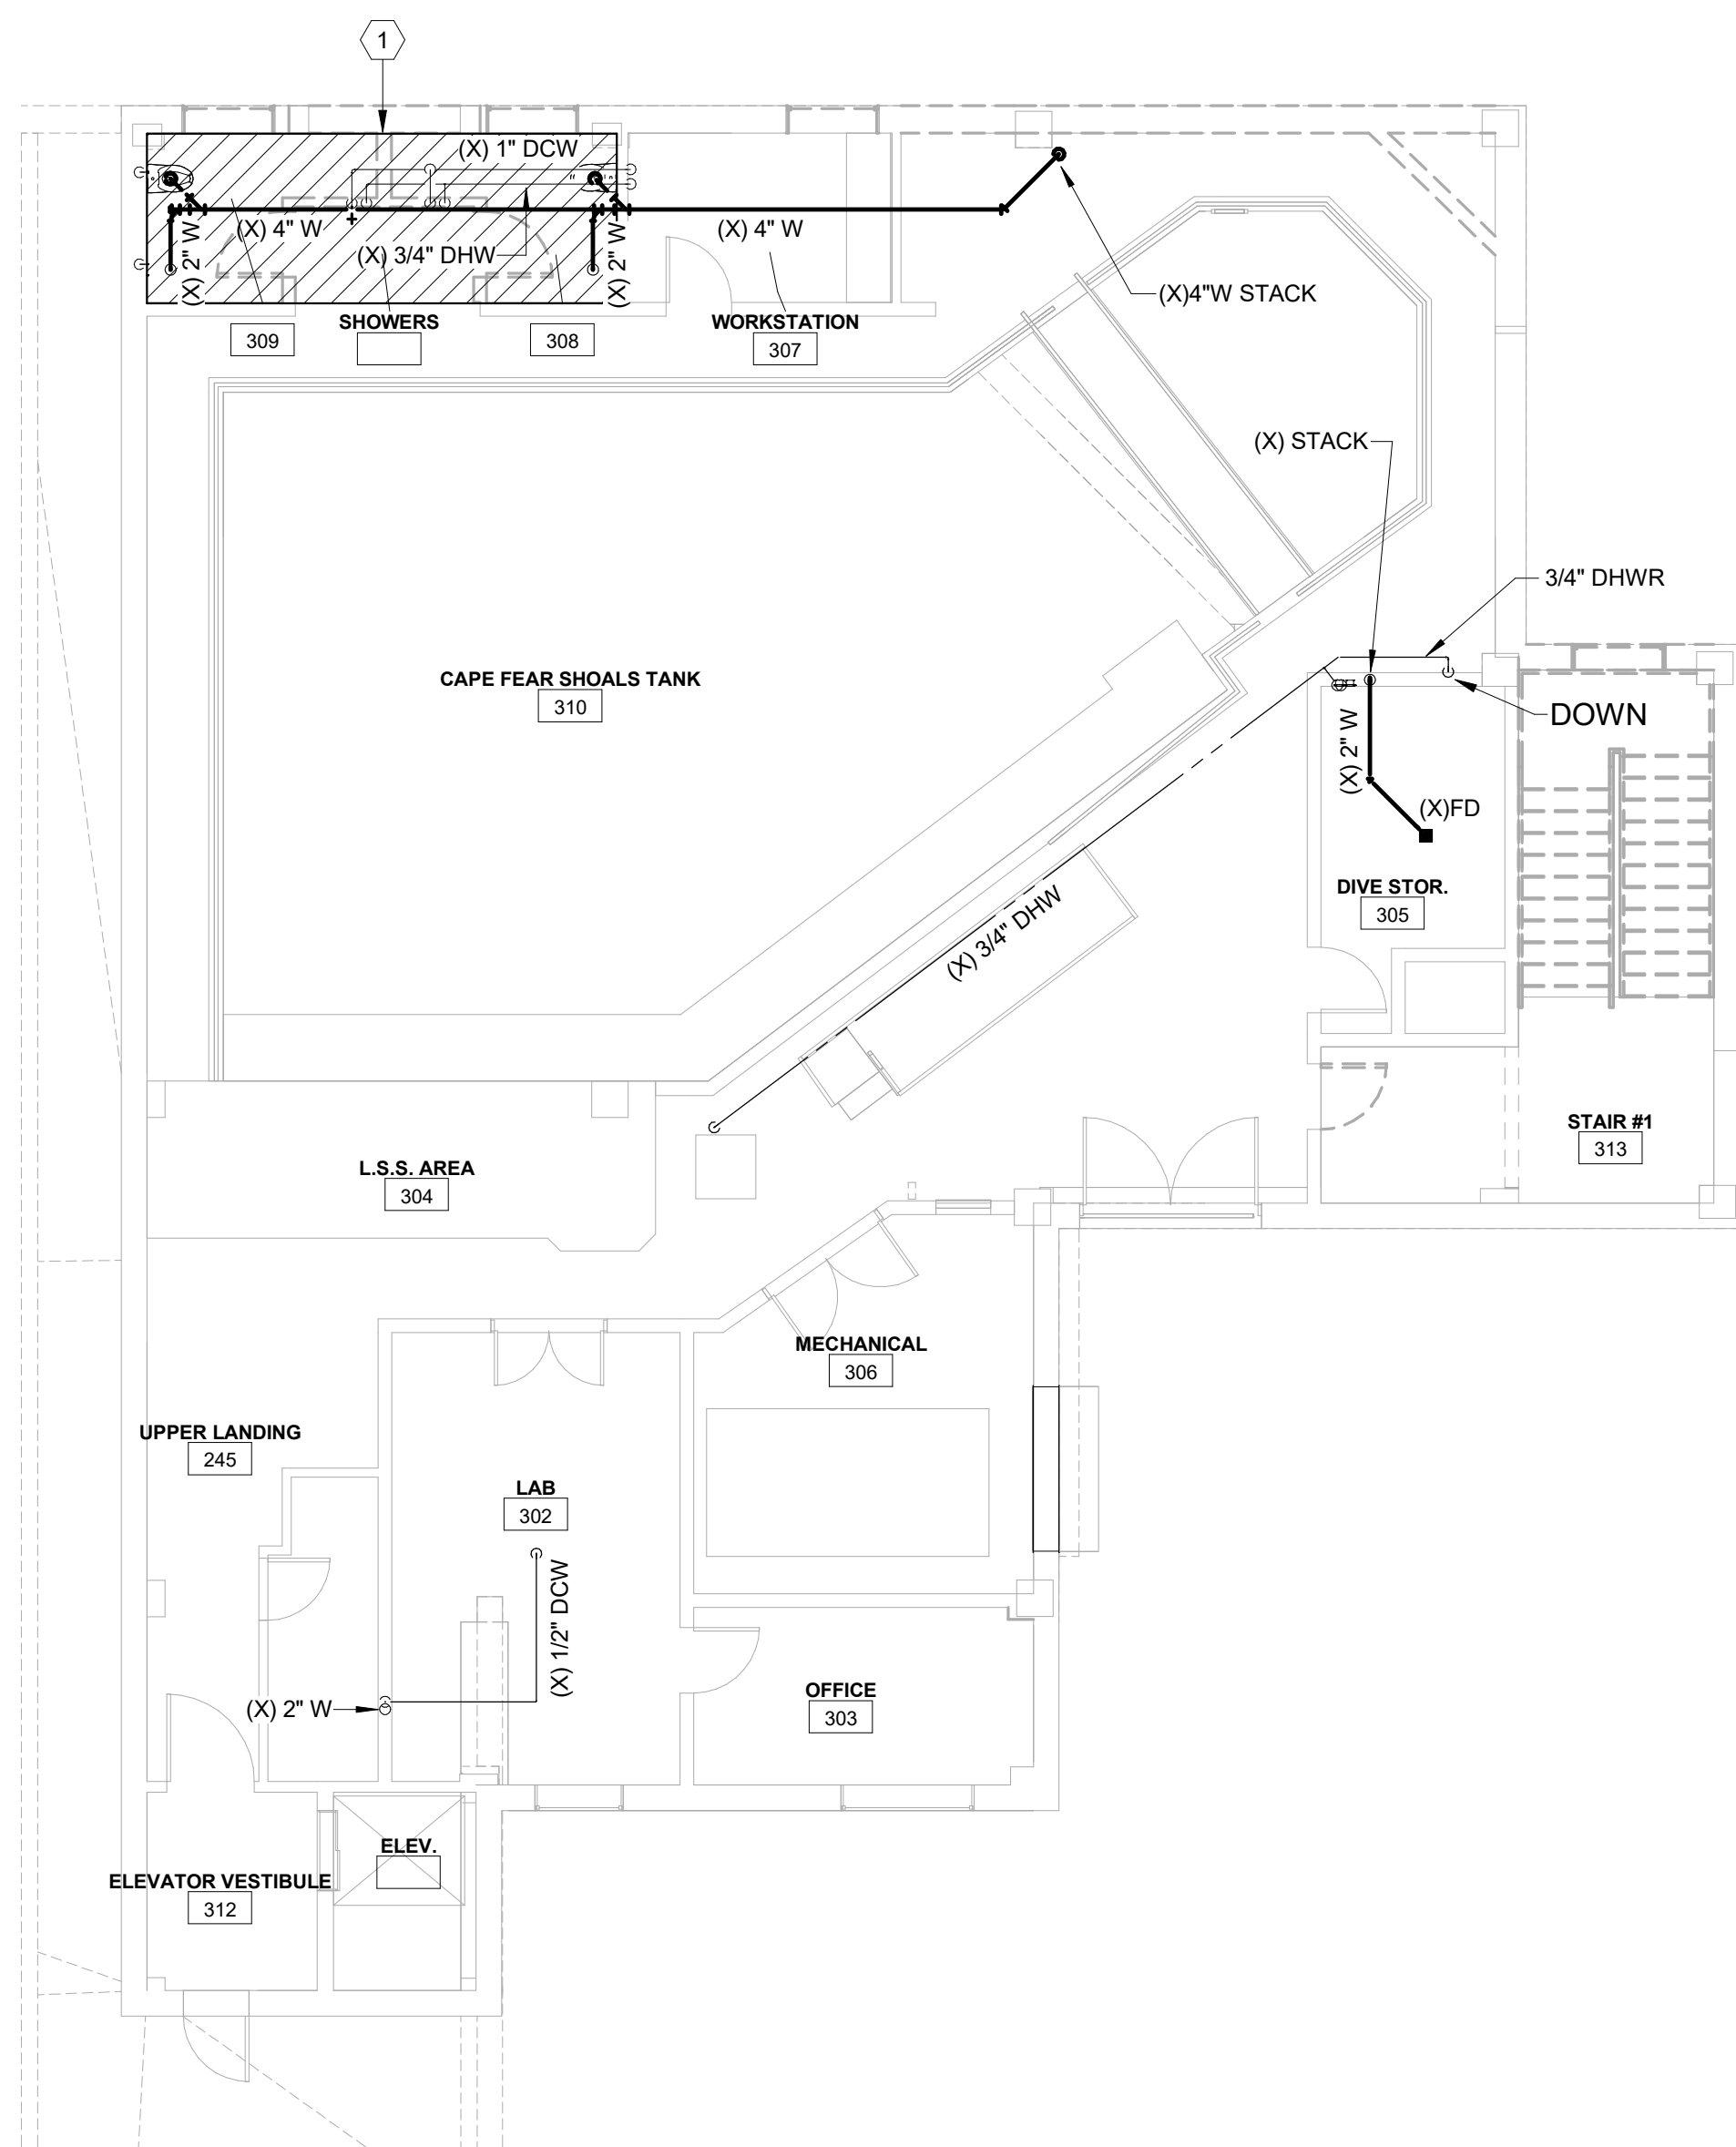

CBHF
Engineers, PLLC

2246 Yaupon Drive
Wilmington, NC 28401
Phone: 910.791.4000
Fax: 910.791.5266
www.cbhfengineers.com
Copyright 2025 CBHF Engineers, PLLC NC# P-05

© Copyright 2025 CBHF Engineers, PLLC NC# P-050

8' 4' 0' 8'

SCALE : 1/8" = 1'-0"



3RD FLOOR - DEMO - CAPE FEAR

SCALE: 1/8" = 1'-0"

SCO #17-18042-02A
CODE: 42014-4G02
ITEM: 41414-4Y4A

900 LOGGERHEAD RD,
KURE BEACH, NC 28449

NORTH CAROLINA DEPT. OF
NATURAL & CULTURAL RESOURCES

SZOSTAK DESIGN, INC.
ARCHITECT

ARCHITECT
310 1/2 WEST FRANKLIN STREET
CHAPEL HILL, NORTH CAROLINA 27516
TELE: 919.929.5244
FAX: 919.960.7967
WWW.S2CSTAKDESIGN.COM
LICENSE # 51679

TJP ENGINEERING, INC.
LIFE SUPPORT SYSTEMS ENGINEER

LIFE SUPPORT SYSTEMS ENGINEER
56880 VENTURE LANE SUITE 205N
BEND, OR 97707
TELE: 619.423.8700
WWW.TJENGINEERING.COM
LICENSE # C-3505

ROTO GROUP, LLC.

EXHIBIT DESIGNER
7001 DISCOVERY BOULEVARD
DUBLIN, OHIO 43017
TELE: 617.760.8690
WWW.ROFO.COM

BENNETT & PLESS

STRUCTURAL ENGINEER
5430 WADE PARK BOULEVARD SUITE 400
RALEIGH, NC 27607
TELE: 919.832.5587
WWW.BENNETT-PLESS.COM
LICENSE # F-1105

CBHF ENGINEERS, PLLC

MEP ENGINEER
2246 YAUFON DRIVE
WILMINGTON, NC 28401
TELE: 910.791.4000
FAX: 910.791.5266
WWW.CBHEENGINEERS.COM
LICENSE # P-0506

LIGHTSWITCH

LIGHTING DESIGNER
10265 INDIANA COURT
RANCHO CUCAMONGA, CA 91730
TELE: 909.360.2900
WWW.LIGHTSWITCH.NET

TUNSTALL CONSULTING ENGINEERS PLLC

CIVIL ENGINEER
2602 IRON GATE DRIVE SUITE 102
WILMINGTON, NC 28412
TEL: 910.343.9653
FAX: 910.343.9604
WWW.1NTEENGINEERS.COM
LICENSE # P-3152

SURFACE 678, PA

LANDSCAPE ARCHITECT
215 MORRIS STREET SUITE 150
DURHAM, NC 27701
TEL: 919.419.1199
FAX: 919.419.1669
WWW.SURFACE678.COM
LICENSE # C-098

CHEATHAM & ASSOCIATES, PA

FIRE PROTECTION ENGINEER
3412 ENTERPRISE DRIVE
WILMINGTON, NC 28405
TELE: 910.452.4210
WWW.CHEATHAMPA.COM
LICENSE # C-1073

PALACIO COLLABORATIVE

COST ESTIMATOR
4819 EMPEROR BOULEVARD SUITE 400
DURHAM, NC 27703
TELE: 919.605.8952
WWW.PALACIOCOLLABORATIVE.COM

NOTE: IF THIS DRAWING IS NOT 30" X 42", IT IS A REDUCED PRINT. REFER TO GRAPHIC SCALE.

NOT FOR
CONSTRUCTION

SEAL
23551
ENGINEER
DAVID M. HAHN

**NOT FOR
CONSTRUCTION**

NO.	DATE	DESCRIPTION
1	9-8-25	BID SET

FIRST FLOOR PLAN -
WASTE-VENT

PS2.11

REFER TO ARCHITECTURAL DRAWING SET FOR CONSTRUCTION PHASING REQUIREMENTS. COORDINATE WORK CLOSELY WITH GENERAL CONTRACTOR AND ALL OTHER TRADES.

 EXISTING BUILDING
 RENOVATED AREA
 UPFIT BY OTHERS

----- 1-HR RATED WALL
----- 2-HR RATED WALL
----- 3-HR RATED WALL

1. PLUMBING CONTRACTOR TO COORDINATE WITH OTHER TRADES PRIOR TO BEGINNING WORK.
2. REFER TO ARCHITECTURAL DRAWINGS FOR RATED ASSEMBLY U/L NUMBERS (WALLS, FLOOR / CEILING, ETC.)
3. DRAWINGS: DRAWINGS ARE DIAGRAMMATIC AND MAY NOT COMPLETELY DESCRIBE EVERY DETAIL OF THE INSTALLATION. HOWEVER, CONTRACTOR IS RESPONSIBLE FOR PROVIDING ALL THE PLUMBING SYSTEMS INCLUDING ALL REQUIRED EQUIPMENT AND ACCESSORIES TO OBTAIN FULLY FUNCTIONING PLUMBING SYSTEMS.
4. EQUIPMENT LOCATIONS: DETERMINE EXACT EQUIPMENT AND MATERIALS LOCATIONS TO PROVIDE BEST ARRANGEMENT AND TO FACILITATE PROPER MAINTENANCE AND SERVICING OF EQUIPMENT.
5. LISTING AND LABELING: ALL EQUIPMENT SHALL BE LABELED OR LISTED BY UL OR OTHER APPROVED TESTING AGENCY WHERE REQUIRED.

20' 10' 20'

SCALE : 1" = 20'-0"

CBHF
Engineers, PLLC

2246 Yaupon Drive
Wilmington, NC 28401
Phone: 910.791.4000
Fax: 910.791.5266
www.cbhfengineers.com
Copyright 2025 CBHF Engineers, PLLC NC# P-0506

© Copyright 2025 CBHF Engineers, PLLC NC# P-0506

OVERALL 1ST FLOOR - WASTE VENT PLAN

SCALE : 1" = 20'-0"

1

FORT FISHER
AQUARIUM
RENOVATION
& EXPANSION:
PHASE 1

9000 LOGGERSHEAD RD,
LAUREL BEACH, NC 28449

NORTH CAROLINA DEPT. OF
NATURAL & CULTURAL RESOURCE

CHTECT
1/2 WEST FRANKLIN STREET
CAPEL HILL, NORTH CAROLINA 27516
E: 919.929.5244
X: 919.960.7967
WWW.S2OSTAKDESIGN.COM
ENSE # 51679

180 VENTURE LANE SUITE 205N
 SEASIDE, OR 97707
 TEL: 619.423.8700
 WWW.TJENGINEERING.COM
 ENSE # C-3505

81 DISCOVERY BOULEVARD
BUN, OHIO 43017
E: 617.760.8690
WWW.ROFO.COM

STRUCTURAL ENGINEER
10 WADE PARK BOULEVARD SUITE 400
LEIGH, NC 27607
E: 919.832.5587
WWW.BENNETT-PLESS.COM
FAX: 919.832.5587
F: 919.832.5587

P ENGINEER
16 YALPON DRIVE
WINSTON, NC 28401
E: 910.791.4000
F: 910.791.5266
WWW.CBHFENGINEERS.COM
ENSE # P-0506

165 INDIANA COURT
NCHO CUCAMONGA, CA 91730
E: 909.360.2900
WWW.LIGHTSWITCH.NET

12 IRON GATE DRIVE SUITE 102
WINSTON, NC 28412
E: 910.343.9653
F: 910.343.9604
WWW.ENTENGINEERS.COM
ENSE # P-3152


LANDSCAPE ARCHITECT
6 MORRIS STREET SUITE 150
RHAM, NC 27701
E: 919.419.1159
X: 919.419.1669
WWW.SURFACE678.COM
ENSE # C-098

2 ENTERPRISE DRIVE
WINGTON, NC 28405
E: 910.452.4210
WWW.CHEATHAMPA.COM
FAX: 910.452.1073

9 EMPEROR BOULEVARD SUITE 400
RHAM, NC 27703
E: 919.605.8952
WWW.PALACIOCOLLABORATIVE.COM

NOTE: IF THIS DRAWING IS NOT 30" X 42", IT IS A REDUCED PRINT. REFER TO GRAPHIC SCALE.

NOT FOR
CONSTRUCTION

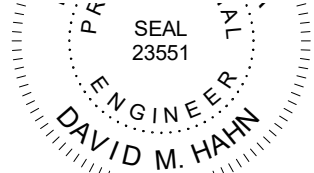

**NOT FOR
CONSTRUCTION**

NO.	DATE	DESCRIPTION
1	9-8-25	BID SET


SECOND FLOOR PLAN WASTE-VENT

PS2.12

REFER TO ARCHITECTURAL DRAWING SET FOR CONSTRUCTION PHASING REQUIREMENTS. COORDINATE WORK CLOSELY WITH GENERAL CONTRACTOR AND ALL OTHER TRADES.

- 3-HR RATED WALL


1. PLUMBING CONTRACTOR TO COORDINATE WITH OTHER TRADES PRIOR TO BEGINNING WORK.
2. REFER TO ARCHITECTURAL DRAWINGS FOR RATED ASSEMBLY UL NUMBERS (WALLS, FLOOR / CEILING ETC.)
3. DRAWINGS: DRAWINGS ARE DIAGRAMMATIC AND MAY NOT COMPLETELY DESCRIBE EVERY DETAIL OF THE SYSTEMATION. HOWEVER, CONTRACTOR IS RESPONSIBLE FOR PROVIDING ALL COMPONENTS INCLUDING ALL REQUIRED EQUIPMENT AND ACCESSORIES TO OBTAIN FULLY FUNCTIONING PLUMBING SYSTEMS.
4. EQUIPMENT LOCATIONS: DETERMINE EXACT EQUIPMENT AND MATERIALS LOCATIONS TO PROVIDE BEST ARRANGEMENT AND TO FACILITATE PROPER MAINTENANCE AND SERVING OF EQUIPMENT.
5. LISTING AND LABELING: ALL EQUIPMENT SHALL BE LABELED OR LISTED BY UL OR OTHER APPROVED TESTING AGENCY WHERE REQUIRED.

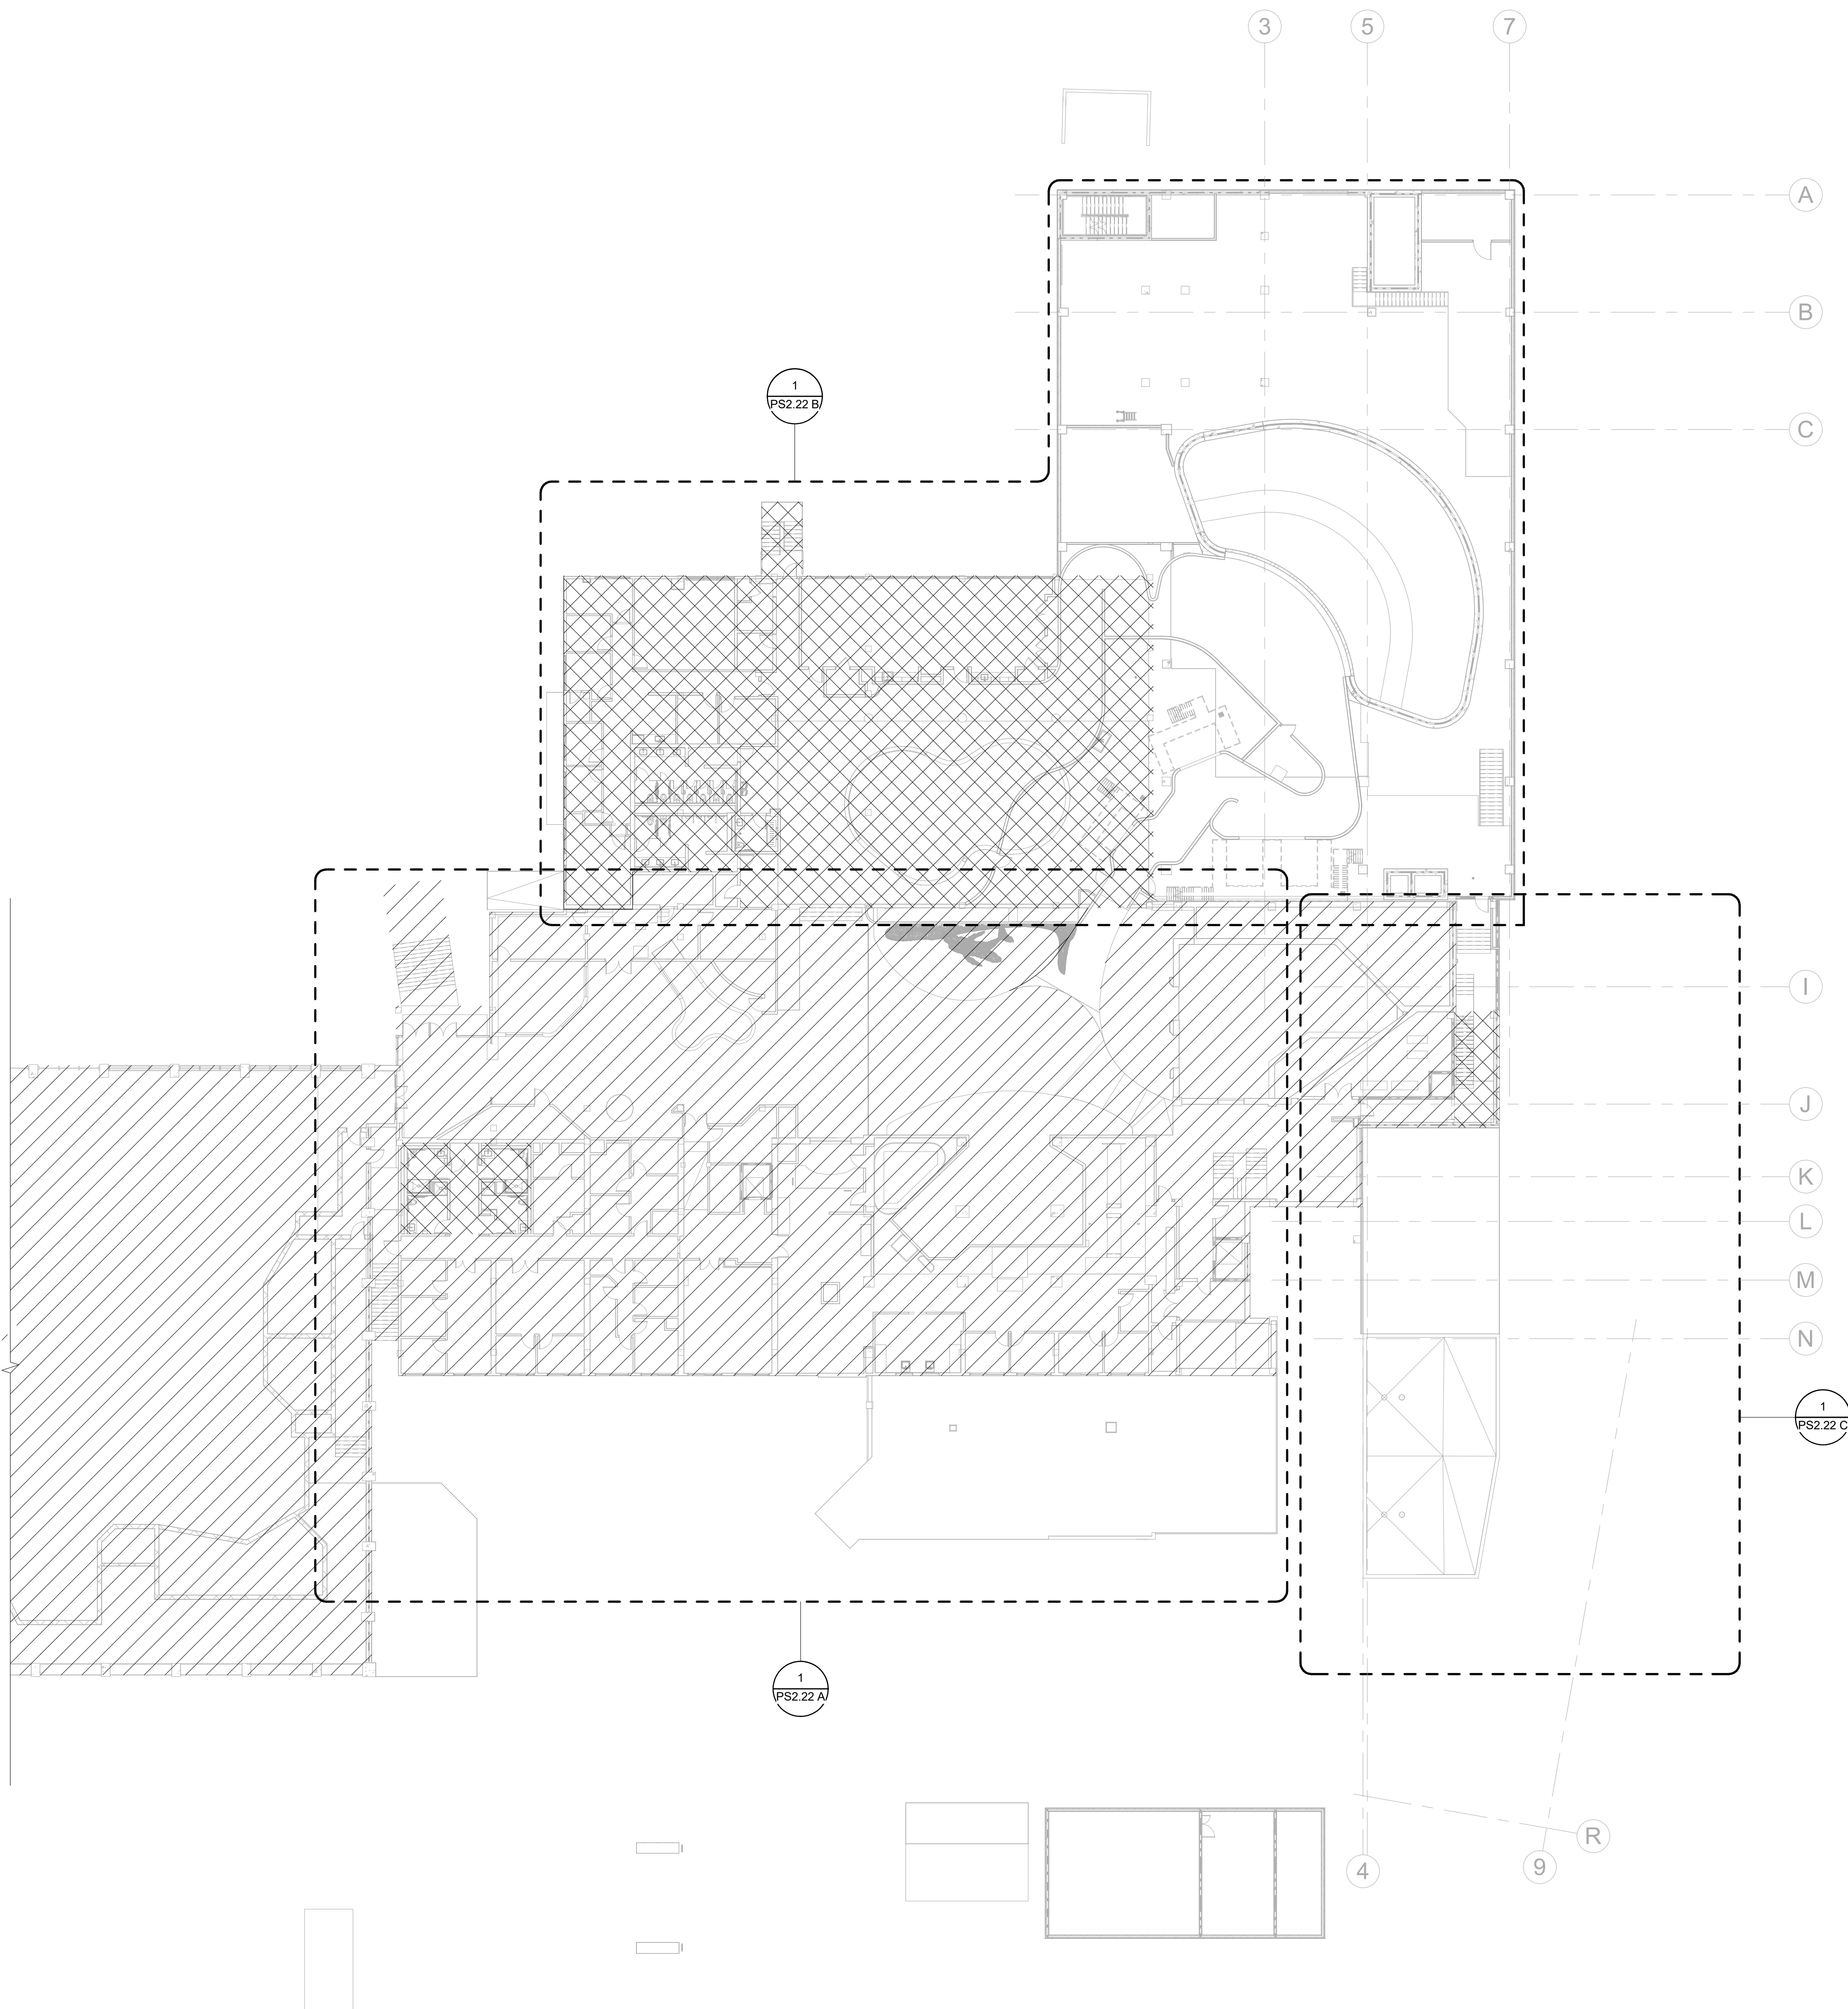

CBHF
Engineers, PLLC

2246 Yaupon Drive
Wilmington, NC 28401
Phone: 910.791.4000
Fax: 910.791.5266
www.cbhfengineers.com
Copyright 2025 CBHF Engineers, PLLC NC# P-05

© Copyright 2025 CBHF Engineers, PLLC NC# P-050

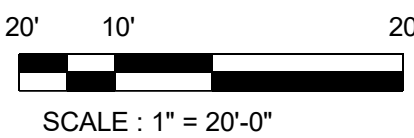

OVERALL 2ND FLOOR - WASTE-VENT PLAN
SCALE : 1" = 20'-0"

SZOSTAK DESIGN

FORT FISHER
AQUARIUM
RENOVATION
& EXPANSION:
PHASE 1

SCO #17-18042-02A
CODE: 42014-4G02
ITEM: 41414-4Y4A

900 LOGGERHEAD RD,
KURE BEACH, NC 28449

NORTH CAROLINA DEPT. OF
NATURAL & CULTURAL RESOURCES

SZOSTAK DESIGN, INC.

ARCHITECT
310 1/2 WEST FRANKLIN STREET
CHAPEL HILL, NORTH CAROLINA 27514
TEL: 919.929.5244
FAX: 919.960.7967
WWW.SZOSTAKDESIGN.COM
LICENSE # 31679

TJP ENGINEERING, INC.

LIFE SUPPORT SYSTEMS ENGINEER
5680 VENTURE LANE SUITE 205N
BEND, OR 97707
TEL: 419.433.0000
WWW.TJPENGINEERING.COM
LICENSE # C-3505

ROTO GROUP, LLC.

EXHIBIT DESIGNER
7001 DISCOVERY BOULEVARD
DURHAM, NC 27707
TEL: 817.760.6690
WWW.ROTO.COM

BENNETT & PLESS

STRUCTURAL ENGINEER
5430 WADE PARK BOULEVARD SUITE 400
RALEIGH, NC 27607
TEL: 919.832.5587
WWW.BENNETT-PLESS.COM
LICENSE # F-1105

CBHF ENGINEERS, PLLC

MFP ENGINEER
2246 YAUPOH DRIVE
WILMINGTON, NC 28401
TEL: 910.791.4000
FAX: 910.791.2546
WWW.CBHFENGINEERS.COM
LICENSE # P-6554

LIGHTSWITCH

LIGHTING DESIGNER
10565 INDIANA COURT
RANCHO CUCAMONGA, CA 91730
TEL: 909.360.0900
WWW.LIGHTSWITCH.NET

TUNSTALL CONSULTING ENGINEERS PLLC

CIVIL ENGINEER
2405 IRON GATE DRIVE SUITE 102
WILMINGTON, NC 28412
TEL: 910.343.9433
FAX: 910.343.9404
WWW.TUNSTALLENGINEERS.COM
LICENSE # F-3132

SURFACE 678, PA

LANDSCAPE ARCHITECT
215 AGRERS STREET SUITE 150
DURHAM, NC 27701
TEL: 919.419.1199
FAX: 919.419.1689
WWW.SURFACE678.COM
LICENSE # C-096

CHEATHAM & ASSOCIATES, PA

FIRE PROTECTION ENGINEER
3412 ENTERPRISE DRIVE
WILMINGTON, NC 28405
TEL: 910.452.4510
WWW.CHEATHAMPA.COM
LICENSE # C-1073

PALACIO COLLABORATIVE

COST ESTIMATOR
4817 ENTERPRISE BOULEVARD SUITE 400
DURHAM, NC 27709
TEL: 919.403.9100
WWW.PALACIOCOLLABORATIVE.COM

NOTE: IF THIS DRAWING IS NOT 30" X 42", IT IS A
REDUCED PRINT. REFER TO GRAPHIC SCALE.

NOT FOR
CONSTRUCTION

SEAL
23551
ENGINEER
DAVID M. HARR

NOT FOR
CONSTRUCTION

NO.	DATE	DESCRIPTION
1	9-8-25	BID SET

THIRD FLOOR PLAN -
WASTE-VENT

PS2.13

PHASING REQUIREMENTS


REFER TO ARCHITECTURAL DRAWING SET FOR CONSTRUCTION PHASING
REQUIREMENTS. COORDINATE WORK CLOSELY WITH GENERAL CONTRACTOR
AND ALL OTHER TRADES.

FLOOR PLAN LEGEND

- EXISTING BUILDING
- RENOVATED AREA
- UPFIT BY OTHERS
- 1-HR RATED WALL
- 2-HR RATED WALL
- 3-HR RATED WALL

FLOOR PLAN SHEET NOTES

- PLUMBING CONTRACTOR TO COORDINATE WITH OTHER TRADES PRIOR TO BEGINNING WORK.
- REFER TO ARCHITECTURAL DRAWINGS FOR RATED ASSEMBLY UL NUMBERS (WALLS, FLOOR / CEILING, ETC.)
- DRAWINGS: DRAWINGS ARE DIAGRAMMATIC AND MAY NOT COMPLETELY DESCRIBE EVERY DETAIL OF THE INSTALLATION. HOWEVER, CONTRACTOR IS RESPONSIBLE FOR FURNISHING COMPLETE SYSTEMS INCLUDING ALL REQUIRED EQUIPMENT AND ACCESSORIES TO OBTAIN FULLY FUNCTIONING PLUMBING SYSTEMS.
- EQUIPMENT LOCATIONS: DETERMINE EXACT EQUIPMENT AND MATERIALS LOCATIONS TO PROVIDE BEST ARRANGEMENT AND TO FACILITATE PROPER MAINTENANCE AND SERVICING OF EQUIPMENT.
- LISTING AND LABELING: ALL EQUIPMENT SHALL BE LABELED OR LISTED BY UL OR OTHER APPROVED TESTING AGENCY WHERE REQUIRED.

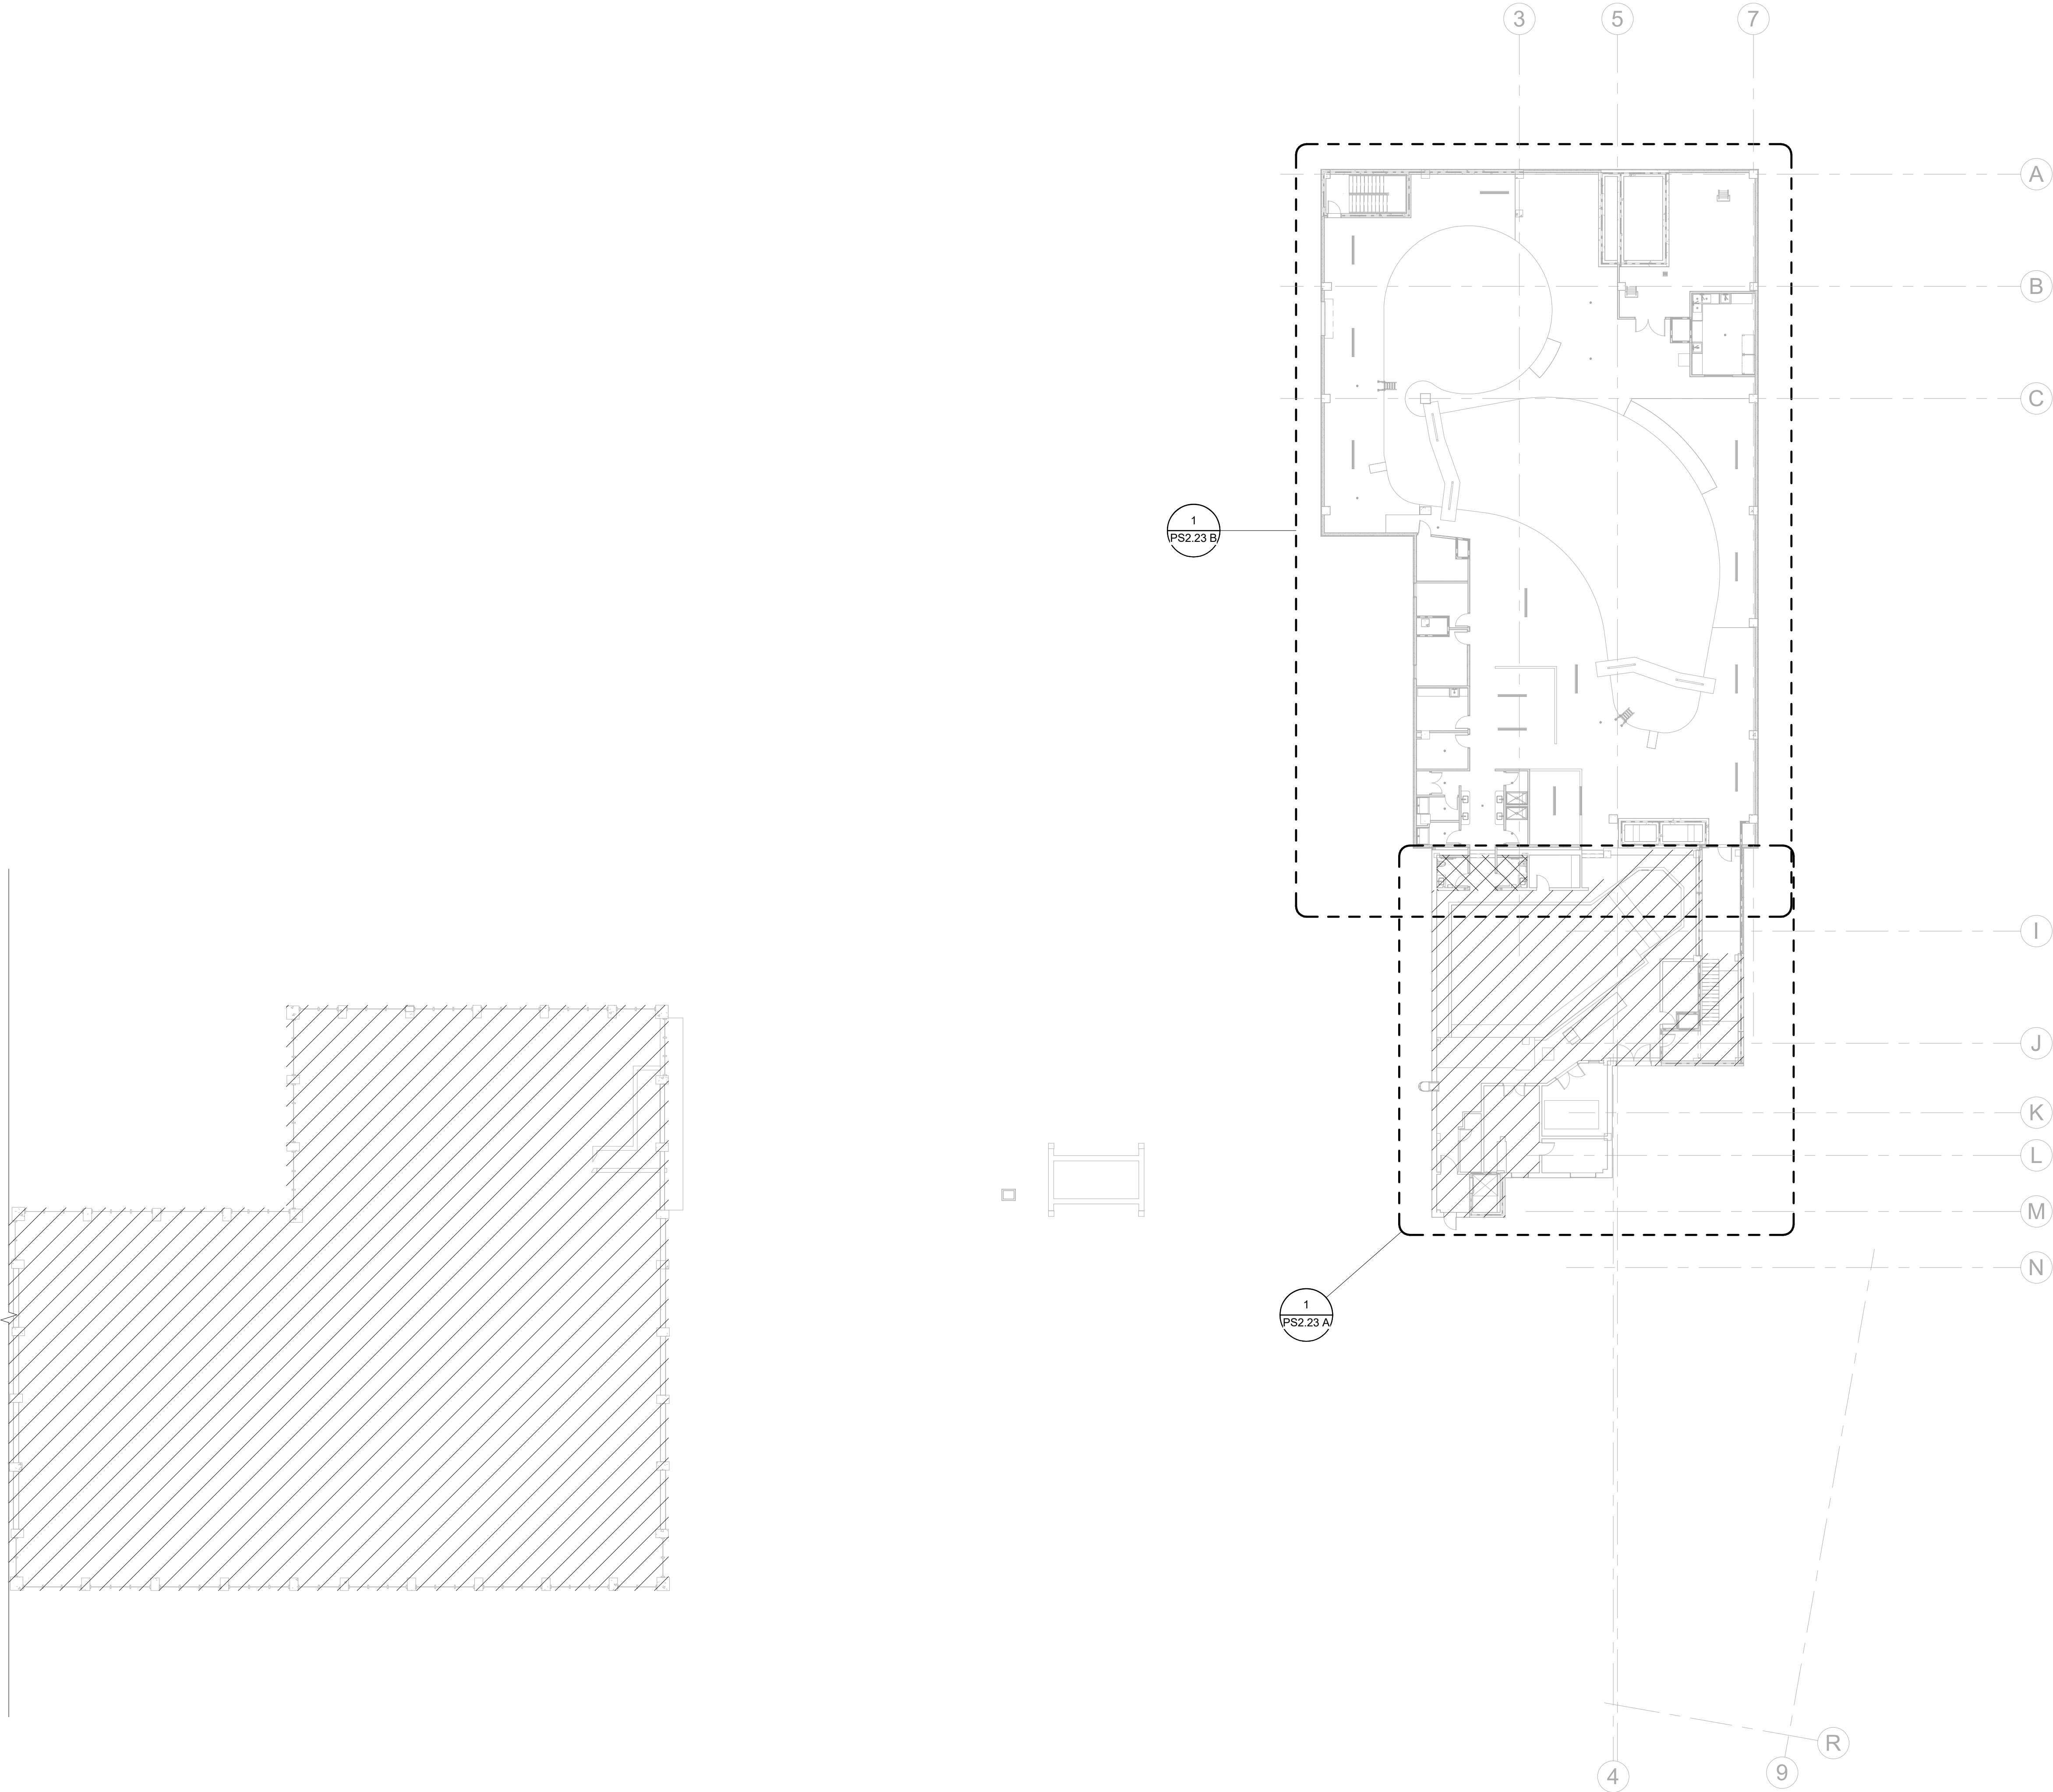

20' 10' 20'
SCALE : 1" = 20'-0"

OVERALL 3RD FLOOR - WASTE-VENT PLAN
SCALE : 1" = 20'-0"

CBHF
Engineers, PLLC

2246 Yaupon Drive
Wilmington, NC 28401
Phone: 910.791.4000
Fax: 910.791.5266
www.cbhfenr.com

© Copyright 2025 CBHF Engineers, PLLC. NCIP # 0356

SZOSTAK DESIGN

FORT FISHER
AQUARIUM
RENOVATION
& EXPANSION:
PHASE 1

SCO #17-18042-02A
CODE: 42014-4G02
ITEM: 41414-4Y4A

900 LOGGERHEAD RD,
KURE BEACH, NC 28449

NORTH CAROLINA DEPT. OF
NATURAL & CULTURAL RESOURCES

SZOSTAK DESIGN, INC.

ARCHITECT
310 1/2 WEST FRANKLIN STREET
CHAPEL HILL, NORTH CAROLINA 27514
TEL: 919.929.5244
FAX: 919.960.7987
WWW.SZOSTAKDESIGN.COM
LICENSE # 31679

TJP ENGINEERING, INC.

LIFE SUPPORT SYSTEMS ENGINEER
5680 VENTURE LANE SUITE 205N
BEND, OR 97007
TEL: 503.433.0300
WWW.TJPENGINEERING.COM
LICENSE # C-3555

ROTO GROUP, LLC.

EXHIBIT DESIGNER
7001 DISCOVERY BOULEVARD
DUBLIN, OHIO 43017
TEL: 617.760.6695
WWW.ROTO.COM

BENNETT & PLESS

STRUCTURAL ENGINEER
5430 WADE PARK BOULEVARD SUITE 400
RALEIGH, NC 27607
TEL: 919.832.5587
WWW.BENNETT-PLESS.COM
LICENSE # F-1105

CBHF ENGINEERS, PLLC

MFP ENGINEER
2246 YAUPON DRIVE
WILMINGTON, NC 28401
TEL: 910.791.4000
FAX: 910.791.5566
WWW.CBHFENGINEERS.COM
LICENSE # P-0554

LIGHTSWITCH

LIGHTING DESIGNER
10565 INDIANA COURT
RAJCHIO CUCAMONGA, CA 91730
TEL: 909.360.0900
WWW.LIGHTSWITCH.NET

TUNSTALL CONSULTING ENGINEERS PLLC

CIVIL ENGINEER
2405 BROWN GATE DRIVE SUITE 102
WILMINGTON, NC 28412
TEL: 910.343.9433
FAX: 910.343.9404
WWW.TUNSTALLENGINEERS.COM
LICENSE # F-3132

SURFACE 678, PA

LANDSCAPE ARCHITECT
215 AGRIS STREET SUITE 150
DURHAM, NC 27701
TEL: 919.419.1199
FAX: 919.419.1688
WWW.SURFACE678.COM
LICENSE # C-098

CHEATHAM & ASSOCIATES, PA

FIRE PROTECTION ENGINEER
3412 ENTERPRISE DRIVE
WILMINGTON, NC 28405
TEL: 910.452.4510
WWW.CHEATHAMPA.COM
LICENSE # C-1073

PALACIO COLLABORATIVE

COST ESTIMATOR
4817 ENTERPRISE BOULEVARD SUITE 400
DURHAM, NC 27703
TEL: 919.403.9100
WWW.PALACIOCOLLABORATIVE.COM

NOTE: IF THIS DRAWING IS NOT 30" X 42", IT IS A
REDUCED PRINT. REFER TO GRAPHIC SCALE.

NOT FOR
CONSTRUCTION

SEAL
23551
ENGINEER
DAVID M. HARR

NOT FOR
CONSTRUCTION

NO. DATE DESCRIPTION

1 9-8-25 BID SET

ROOF PLAN

PS2.14

PHASING REQUIREMENTS



REFER TO ARCHITECTURAL DRAWING SET FOR CONSTRUCTION PHASING
REQUIREMENTS. COORDINATE WORK CLOSELY WITH GENERAL CONTRACTOR
AND ALL OTHER TRADES.

FLOOR PLAN LEGEND

- EXISTING BUILDING
- RENOVATED AREA
- UPFIT BY OTHERS
- 1-HR RATED WALL
- 2-HR RATED WALL
- 3-HR RATED WALL

FLOOR PLAN SHEET NOTES

1. PLUMBING CONTRACTOR TO COORDINATE WITH OTHER TRADES PRIOR TO BEGINNING WORK.
2. REFER TO ARCHITECTURAL DRAWINGS FOR RATED ASSEMBLY UL NUMBERS (WALLS, FLOOR / CEILING, ETC.)
3. DRAWINGS: DRAWINGS ARE DIAGRAMMATIC AND MAY NOT COMPLETELY DESCRIBE EVERY DETAIL OF THE INSTALLATION. HOWEVER, CONTRACTOR IS RESPONSIBLE FOR FURNISHING COMPLETE SYSTEMS INCLUDING ALL REQUIRED EQUIPMENT AND ACCESSORIES TO OBTAIN FULLY FUNCTIONING PLUMBING SYSTEMS.
4. EQUIPMENT LOCATIONS: DETERMINE EXACT EQUIPMENT AND MATERIALS LOCATIONS TO PROVIDE BEST ARRANGEMENT AND TO FACILITATE PROPER MAINTENANCE AND SERVICING OF EQUIPMENT.
5. LISTING AND LABELING: ALL EQUIPMENT SHALL BE LABELED OR LISTED BY UL OR OTHER APPROVED TESTING AGENCY WHERE REQUIRED.

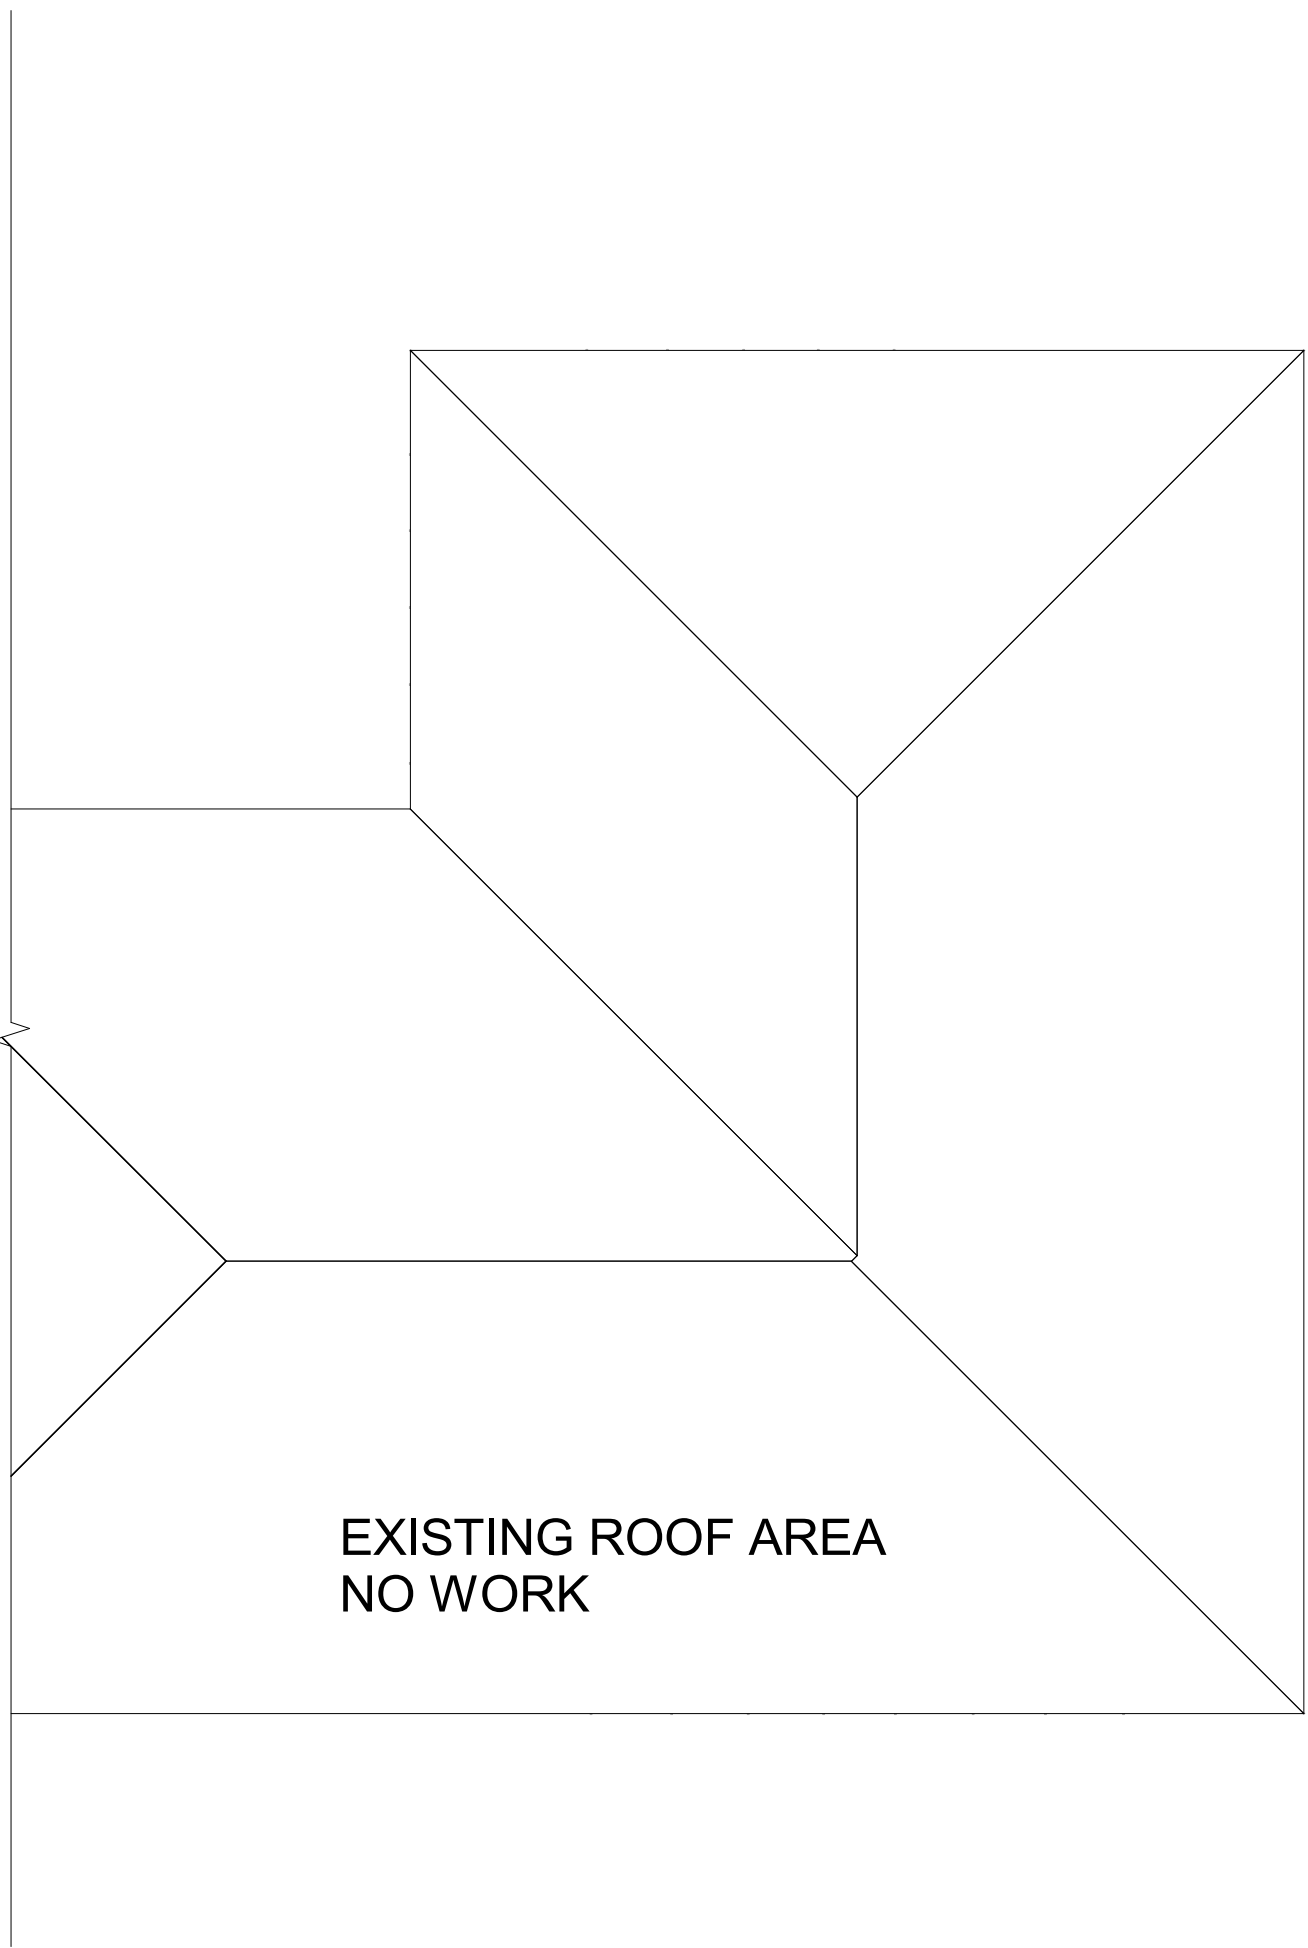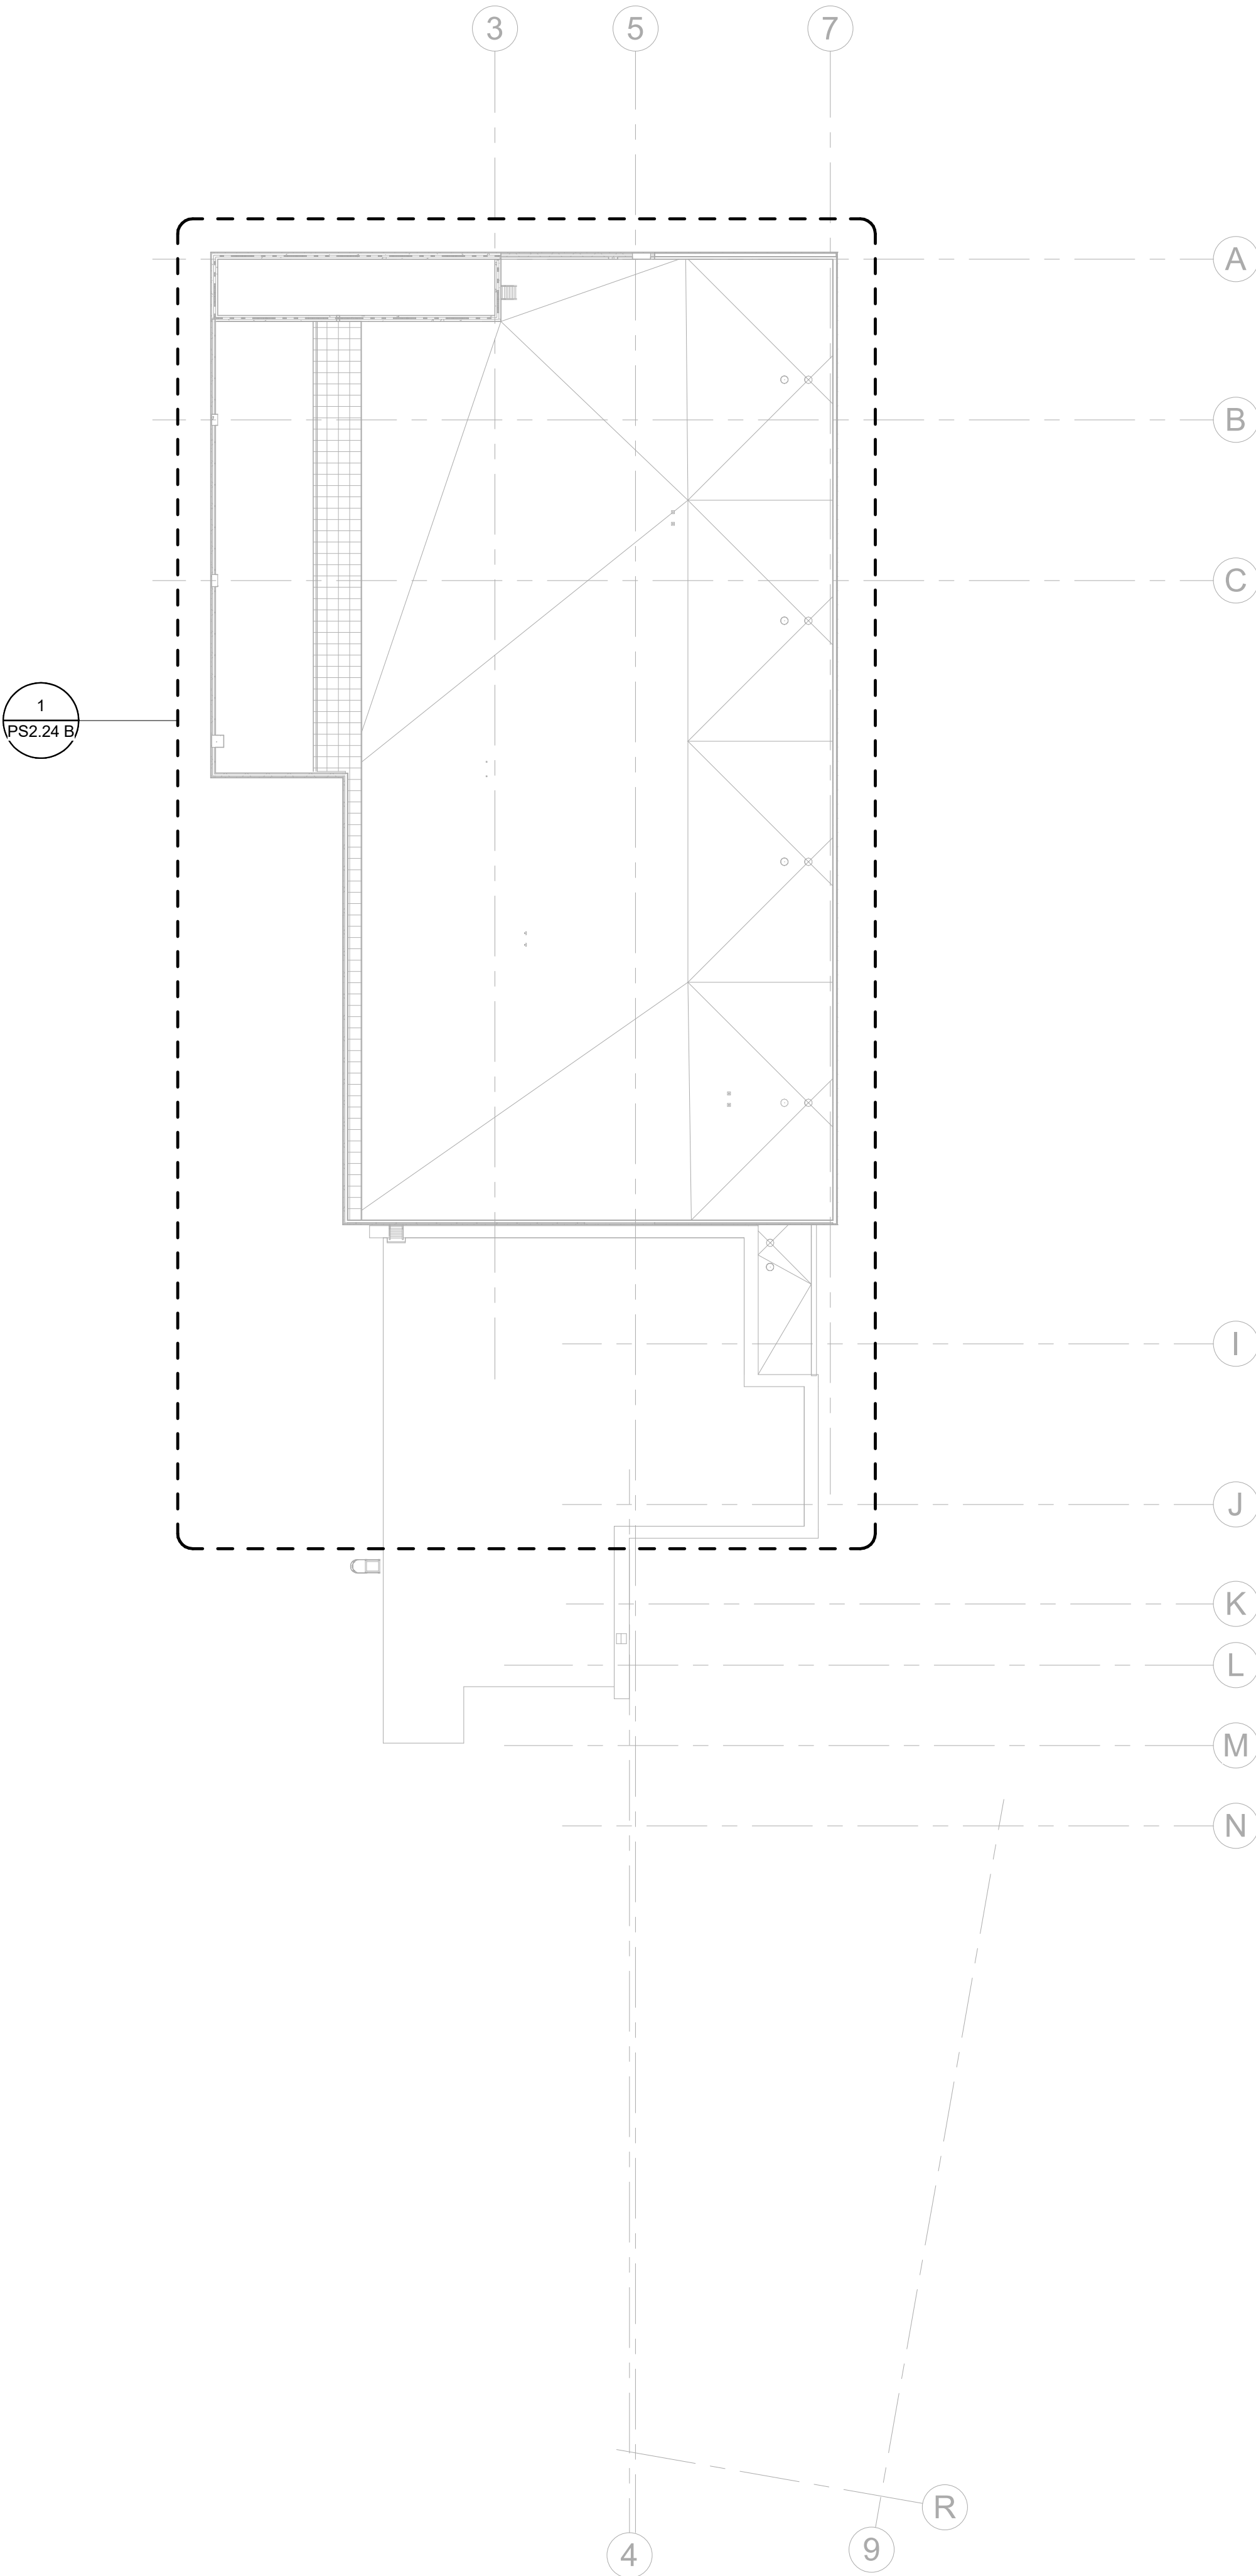

20' 10' 20'
SCALE : 1" = 20'-0"

ROOF PLAN
SCALE : 1" = 20'-0"

CBHF
Engineers, PLLC

2246 Yaupon Drive
Wilmington, NC 28401
Phone: 910.791.4000
Fax: 910.791.5566
www.cbhfenr.com
© Copyright 2025 CBHF Engineers, PLLC. NCIP # 0556

SCO #17-18042-02A
CODE: 42014-4G02
ITEM: 41414-4Y4A

900 LOGGERHEAD RD,
KURE BEACH, NC 28449

NORTH CAROLINA DEPT. OF
NATURAL & CULTURAL RESOURCES

SZOSTAK DESIGN, INC.

ARCHITECT
310 1/2 WEST FRANKLIN STREET
CHAPEL HILL, NORTH CAROLINA 27516
TEL: 919.929.5244
FAX: 919.960.7967
WWW.S2OSTAKDESIGN.COM
LICENSE # 51679

TJP ENGINEERING, INC

LIFE SUPPORT SYSTEMS ENGINEER
56880 VENTURE LANE SUITE 205N
BEND, OR 97707
TELE: 619.423.8700
WWW.TJENGINEERING.COM
LICENSE # C-3505

ROTO GROUP, LLC.

EXHIBIT DESIGNER
7001 DISCOVERY BOULEVARD
DUBLIN, OHIO 43017
TELE: 617.760.8690
WWW.ROTO.COM

BENNETT & PLESS

STRUCTURAL ENGINEER
5430 WADE PARK BOULEVARD SUITE 400
RALEIGH, NC 27607
TELE: 919.832.5587
WWW.BENNETT-PLESS.COM
LICENSE # F-1105

CBHF ENGINEERS, PLLC

MEP ENGINEER
2246 YALPON DRIVE
WILMINGTON, NC 28401
TEL: 910.791.4000
FAX: 910.791.5266
WWW.CBHENGINEERS.COM

LIGHTSWITCH

LIGHTING DESIGNER
10265 INDIANA COURT
RANCHO CUCAMONGA, CA 91730
TELE: 909.360.2900
WWW.LIGHTSWITCH.NET

TUNSTALL CONSULTING ENGINEERS PLLC

CIVIL ENGINEER
2602 IRON GATE DRIVE SUITE 102
WILMINGTON, NC 28412
TELE: 910.343.9653
FAX: 910.343.9604
WWW.NTENGINEERS.COM
LICENSE # P-3152

SURFACE 678, PA

LANDSCAPE ARCHITECT
215 MORRIS STREET SUITE 150
DURHAM, NC 27701
TEL: 919.419.1199
FAX: 919.419.1669
WWW.SURFACE678.COM
LWENKE & CO.

CHEATHAM & ASSOCIATES, PA

FIRE PROTECTION ENGINEER
3412 ENTERPRISE DRIVE
WILMINGTON, NC 28405
TELE: 910.452.4210
WWW.CHEATHAMPA.COM
LICENSE # C-1073

PALACIO COLLABORA

COST ESTIMATOR
4819 EMPEROR BOULEVARD SUITE 400
DURHAM, NC 27703
TELE: 919.605.8952
WWW.PALACIOCOLLABORATIVE.COM

NOTE: IF THIS DRAWING IS NOT 30" X 42", IT IS
REDUCED PRINT. REFER TO GRAPHIC SCALE

NOT FOR
CONSTRUCTION



**NOT FOR
CONSTRUCTION**


NO.	DATE	DESCRIPTION
1	9-8-25	BID SET

FIRST FLOOR PLAN - CAPE
FEAR SHOALS -
WASTE-VENT


PS2.21 A

FLOOR PLAN SHEET NOTES

1. PLUMBING CONTRACTOR TO COORDINATE WITH OTHER TRADES PRIOR TO BEGINNING WORK.
2. REFER TO ARCHITECTURAL DRAWINGS FOR RATED ASSEMBLY UL NUMBERS (WALLS, FLOOR / CEILING, ETC).
3. DRAWINGS: DRAWINGS ARE DIAGRAMMATIC AND MAY NOT COMPLETELY DESCRIBE EVERY DETAIL OF THE INSTALLATION. HOWEVER, CONTRACTOR IS RESPONSIBLE FOR PROVIDING ALL OTHER SYSTEMS INCLUDING ALL REQUIRED EQUIPMENT AND ACCESSORIES TO OBTAIN FULLY FUNCTIONING PLUMBING SYSTEMS.
4. EQUIPMENT LOCATIONS: DETERMINE EXACT EQUIPMENT AND MATERIALS LOCATIONS TO PROVIDE BEST ARRANGEMENT AND TO FACILITATE PROPER MAINTENANCE AND SERVING OF EQUIPMENT.
5. LISTING AND LABELING: ALL EQUIPMENT SHALL BE LABELED OR LISTED BY UL OR OTHER APPROVED TESTING AGENCY WHERE REQUIRED.

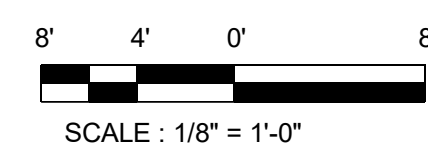

KEY PLAN

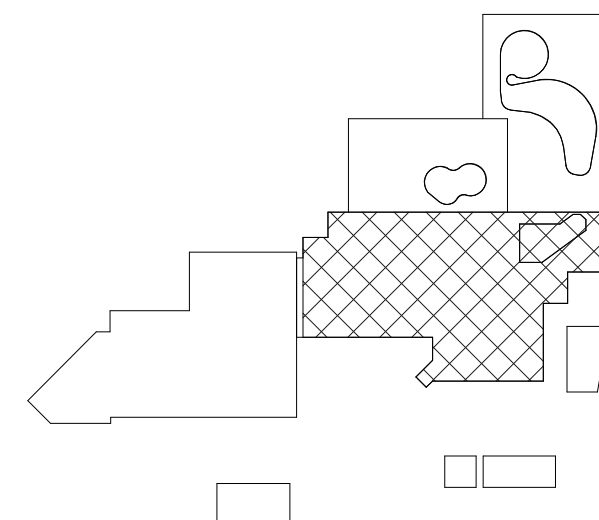

CBHF
Engineers, PLLC

2246 Yaupon Drive
Wilmington, NC 28401
Phone: 910.791.4000
Fax: 910.791.5266
www.cbhfengineers.com
© Copyright 2025 CBHF Engineers, PLLC NC# P-058

1ST FLOOR - CAPE FEAR SHOALS - WASTE VENT - CONST

SCALE : 1/8" = 1'-0"

KEYNOTES THIS SHEET	
1	2" VENT. INSTALL PER 2018 NCPC SECTION 905.4, EXCEPTION 2.
2	2" CIRCUIT VENT
3	EXISTING 4" WASTE TO BE CONNECTED TO NEW PIPING SYSTEM. EXISTING PIPING SYSTEM TO REMAIN ACTIVE.
4	2" VENT UP IN WALL. PROVIDE WCO IN RISER WITH ACCESS FROM INSIDE CUSTODIAL CLOSET
5	6" ORDL FROM ABOVE
6	4" W STACK FROM ABOVE. INSTALL CLEANOUT AT BASE OF STACK.
7	INSTALL CLEANOUT AT BASE OF STACK
8	2" VENT UP
9	4" W STACK FROM ABOVE. INSTALL CLEANOUT AT BASE OF STACK.
10	2" V-UP. 2" AAV. SEE 1/PS2.22B FOR CONTINUATION.
11	PROVIDE AUTOMATIC BACKWATER VALVE ON SANITARY MAIN SERVING FIXTURES AND FLOOR DRAINS LOCATED WITHIN DRY FLOODPROOFED AREA. VALVE SHALL BE LOCATED OUTSIDE OR AT THE EDGE OF THE FLOODPROOFED ENVELOPE AND BE ACCESSIBLE FOR MAINTENANCE. BACKWATER VALVE SHALL BE DESIGNED TO CLOSE AUTOMATICALLY UNDER BACKFLOW CONDITIONS.
12	4" RDL FROM ABOVE. SEE SHEET PS2.22B FOR CONTINUATION.
13	4" STORM LINE TO DROP INLET DI-2.3. SEE SHEET C-2.1 FOR CONTINUATION.

PHASING REQUIREMENTS

REFER TO ARCHITECTURAL DRAWING SET FOR CONSTRUCTION PHASING REQUIREMENTS. COORDINATE WORK CLOSELY WITH GENERAL CONTRACTOR AND ALL OTHER TRADES.

FLOOR PLAN LEGEND	
	EXISTING BUILDING
	RENOVATED AREA
	UPFIT BY OTHERS
	1-HR RATED WALL
	2-HR RATED WALL
	3-HR RATED WALL

FLOOR PLAN SHEET NOTES

- PLUMBING CONTRACTOR TO COORDINATE WITH OTHER TRADES PRIOR TO BEGINNING WORK.
- REFER TO ARCHITECTURAL DRAWINGS FOR RATED ASSEMBLY UL NUMBERS (WALLS, FLOOR / CEILING, ETC.)
- DRAWINGS: DRAWINGS ARE DIAGRAMMATIC AND MAY NOT COMPLETELY DESCRIBE EVERY DETAIL OF THE INSTALLATION. HOWEVER, CONTRACTOR IS RESPONSIBLE FOR FURNISHING COMPLETE PLUMBING SYSTEMS.
- EQUIPMENT LOCATIONS: DETERMINE EXACT EQUIPMENT AND MATERIALS LOCATIONS TO PROVIDE BEST ARRANGEMENT AND TO FACILITATE PROPER MAINTENANCE AND SERVICING OF EQUIPMENT.
- LISTING AND LABELING: ALL EQUIPMENT SHALL BE LABELED OR LISTED BY UL OR OTHER APPROVED TESTING AGENCY WHERE REQUIRED.

SZOSTAK DESIGN

FORT FISHER
AQUARIUM
RENOVATION
& EXPANSION:
PHASE 1

SCO #17-18042-02A
CODE: 42014-4G02
ITEM: 41414-4Y4A

900 LOGGERHEAD RD,
KURE BEACH, NC 28449

NORTH CAROLINA DEPT. OF
NATURAL & CULTURAL RESOURCES

SZOSTAK DESIGN, INC.

ARCHITECT
310 1/2 WEST FRANKLIN STREET
CHapel Hill, NC 27514
TEL: 919.929.3244
FAX: 919.960.7967
WWW.SZOSTAKDESIGN.COM
LICENSE # 31079

TJP ENGINEERING, INC.

LIFE SUPPORT SYSTEMS ENGINEER
5680 VENTURE LANE SUITE 205N
BEND, OR 97007
TEL: 503.433.0300
WWW.TJPEENGINEERING.COM
LICENSE # C-3505

ROTO GROUP, LLC.

EXHIBIT DESIGNER
7001 DISCOVERY BOULEVARD
DURHAM, NC 27707
TEL: 919.282.5587
WWW.ROTO.COM

BENNETT & PLESS

STRUCTURAL ENGINEER
5430 WADE PARK BOULEVARD SUITE 400
RALEIGH, NC 27607
TEL: 919.822.5587
WWW.BENNETT-PLESS.COM
LICENSE # F-1105

CBHF ENGINEERS, PLLC

MFP ENGINEER
2244 YAUPON DRIVE
WILMINGTON, NC 28401
TEL: 910.791.4000
FAX: 910.791.2504
WWW.CBHFENGINEERS.COM
LICENSE # F-6554

LIGHTSWITCH

LIGHTING DESIGNER
10065 INDIANA COURT
RANCHO CUCAMONGA, CA 91730
TEL: 909.360.7000
WWW.LIGHTSWITCH.NET

TUNSTALL CONSULTING ENGINEERS PLLC

CIVIL ENGINEER
2405 BROWN GATE DRIVE SUITE 102
WILMINGTON, NC 28412
TEL: 910.343.8433
FAX: 910.343.9404
WWW.TUNSTALLENGINEERS.COM
LICENSE # F-3132

SURFACE 678, PA

LANDSCAPE ARCHITECT
215 AGRIS STREET SUITE 150
DURHAM, NC 27705
TEL: 919.419.1199
FAX: 919.419.1689
WWW.SURFACE678.COM
LICENSE # F-3132

CHEATHAM & ASSOCIATES, PA

RRE PROTECTION ENGINEER
3412 ENTERPRISE DRIVE
WILMINGTON, NC 28405
TEL: 910.452.8100
WWW.CHEATHAMPA.COM
LICENSE # C-1073

PALACIO COLLABORATIVE

COST ESTIMATOR
4815 ENTERPRISE BOULEVARD SUITE 400
DURHAM, NC 27705
TEL: 919.452.8100
WWW.PALACIOCOLLABORATIVE.COM

NOTE: IF THIS DRAWING IS NOT 30" X 42", IT IS A
REDUCED PRINT. REFER TO GRAPHIC SCALE.

NOT FOR
CONSTRUCTION

SEAL
23551
ENGINEER
DAVID M. HARRIS

NOT FOR
CONSTRUCTION

NO.	DATE	DESCRIPTION
1	9-8-25	BID SET

FIRST FLOOR PLAN -
TOUCH AND SHARK TANK -
WASTE-VENT

PS2.21 B

CBHF
Engineers, PLLC

2246 Yaupon Drive
Wilmington, NC 28401
Phone: 910.791.4000
Fax: 910.791.5266
www.cbhfindesign.com
© Copyright 2025 CBHF Engineers, PLLC. NCPC # 0306

8' 4' 0' 8'
SCALE: 1/8" = 1'-0"

1ST FLOOR - TOUCH AND SHARK TANK - WASTE-VENT
SCALE: 1/8" = 1'-0"

SZOSTAK DESIGN

FORT FISHER
AQUARIUM
RENOVATION
& EXPANSION:
PHASE 1

SCO #17-18042-02A
CODE: 42014-4G02
ITEM: 41414-4Y4A

900 LOGGERHEAD RD,
KURE BEACH, NC 28449

NORTH CAROLINA DEPT. OF
NATURAL & CULTURAL RESOURCES

SZOSTAK DESIGN, INC.

ARCHITECT
310 1/2 WEST FRANKLIN STREET
CHAPEL HILL, NORTH CAROLINA 27514
TEL: 919.929.5244
FAX: 919.960.7967
WWW.SZOSTAKDESIGN.COM
LICENSE # 31079

TJP ENGINEERING, INC.

LIFE SUPPORT SYSTEMS ENGINEER
5680 VENTURE LANE SUITE 205N
BEND, OR 97707
TEL: 414.433.0000
WWW.TJPENGINEERING.COM
LICENSE # C-3505

ROTO GROUP, LLC.

EXHIBIT DESIGNER
7001 DISCOVERY BOULEVARD
DURHAM, NC 27707
TEL: 817.760.6690
WWW.ROTO.COM

BENNETT & PLESS

STRUCTURAL ENGINEER
5430 WADE PARK BOULEVARD SUITE 400
RALEIGH, NC 27607
TEL: 919.832.5587
WWW.BENNETT-PLESS.COM
LICENSE # F-1105

CBHF ENGINEERS, PLLC

MFP ENGINEER
2246 YAUPOH DRIVE
WILMINGTON, NC 28401
TEL: 910.791.4000
FAX: 910.791.2546
WWW.CBHFENGINEERS.COM
LICENSE # P-6554

LIGHTSWITCH

LIGHTING DESIGNER
10365 INDIANA COURT
RAJNCHO CUCAMONGA, CA 91730
TEL: 909.360.0900
WWW.LIGHTSWITCH.NET

TUNSTALL CONSULTING ENGINEERS PLLC

CIVIL ENGINEER
2405 BROWN GATE DRIVE SUITE 102
WILMINGTON, NC 28412
TEL: 910.343.9433
FAX: 910.343.9404
WWW.TUNSTALLENGINEERS.COM
LICENSE # F-3132

SURFACE 678, PA

LANDSCAPE ARCHITECT
215 AGERS STREET SUITE 150
DURHAM, NC 27701
TEL: 919.419.1199
FAX: 919.419.1689
WWW.SURFACE678.COM
LICENSE # C-098

CHEATHAM & ASSOCIATES, PA

FIRE PROTECTION ENGINEER
3413 ENDSWEGE DRIVE
WILMINGTON, NC 28405
TEL: 910.452.4510
WWW.CHEATHAMP.A.COM
LICENSE # C-1073

PALACIO COLLABORATIVE

COST ESTIMATOR
4815 EXETER BOULEVARD SUITE 400
DURHAM, NC 27705
TEL: 919.403.9010
WWW.PALACIOCOLLABORATIVE.COM

NOTE: IF THIS DRAWING IS NOT 30" X 42", IT IS A
REDUCED PRINT. REFER TO GRAPHIC SCALE.

NOT FOR
CONSTRUCTION



NOT FOR
CONSTRUCTION

NO.	DATE	DESCRIPTION
1	9-8-25	BID SET

FIRST FLOOR PLAN - MAIN
ENTRY & MECH BLDG -
WASTE-VENT


PS2.21 D

FLOOR PLAN LEGEND


- EXISTING BUILDING
- RENOVATED AREA
- UPFIT BY OTHERS
- 1-HR RATED WALL
- 2-HR RATED WALL
- 3-HR RATED WALL

FLOOR PLAN SHEET NOTES

1. PLUMBING CONTRACTOR TO COORDINATE WITH OTHER TRADES PRIOR TO BEGINNING WORK.
2. REFER TO ARCHITECTURAL DRAWINGS FOR RATED ASSEMBLY UL NUMBERS (WALLS, FLOOR / CEILING, ETC.)
3. DRAWINGS: DRAWINGS ARE DIAGRAMMATIC AND MAY NOT COMPLETELY DESCRIBE EVERY DETAIL OF THE INSTALLATION. HOWEVER, CONTRACTOR IS RESPONSIBLE FOR FURNISHING COMPLETE SYSTEMS INCLUDING ALL REQUIRED EQUIPMENT AND ACCESSORIES TO OBTAIN FULLY FUNCTIONING PLUMBING SYSTEMS.
4. EQUIPMENT LOCATIONS: DETERMINE EXACT EQUIPMENT AND MATERIALS LOCATIONS TO PROVIDE BEST ARRANGEMENT AND TO FACILITATE PROPER MAINTENANCE AND SERVICING OF EQUIPMENT.
5. LISTING AND LABELING: ALL EQUIPMENT SHALL BE LABELED OR LISTED BY UL OR OTHER APPROVED TESTING AGENCY WHERE REQUIRED.

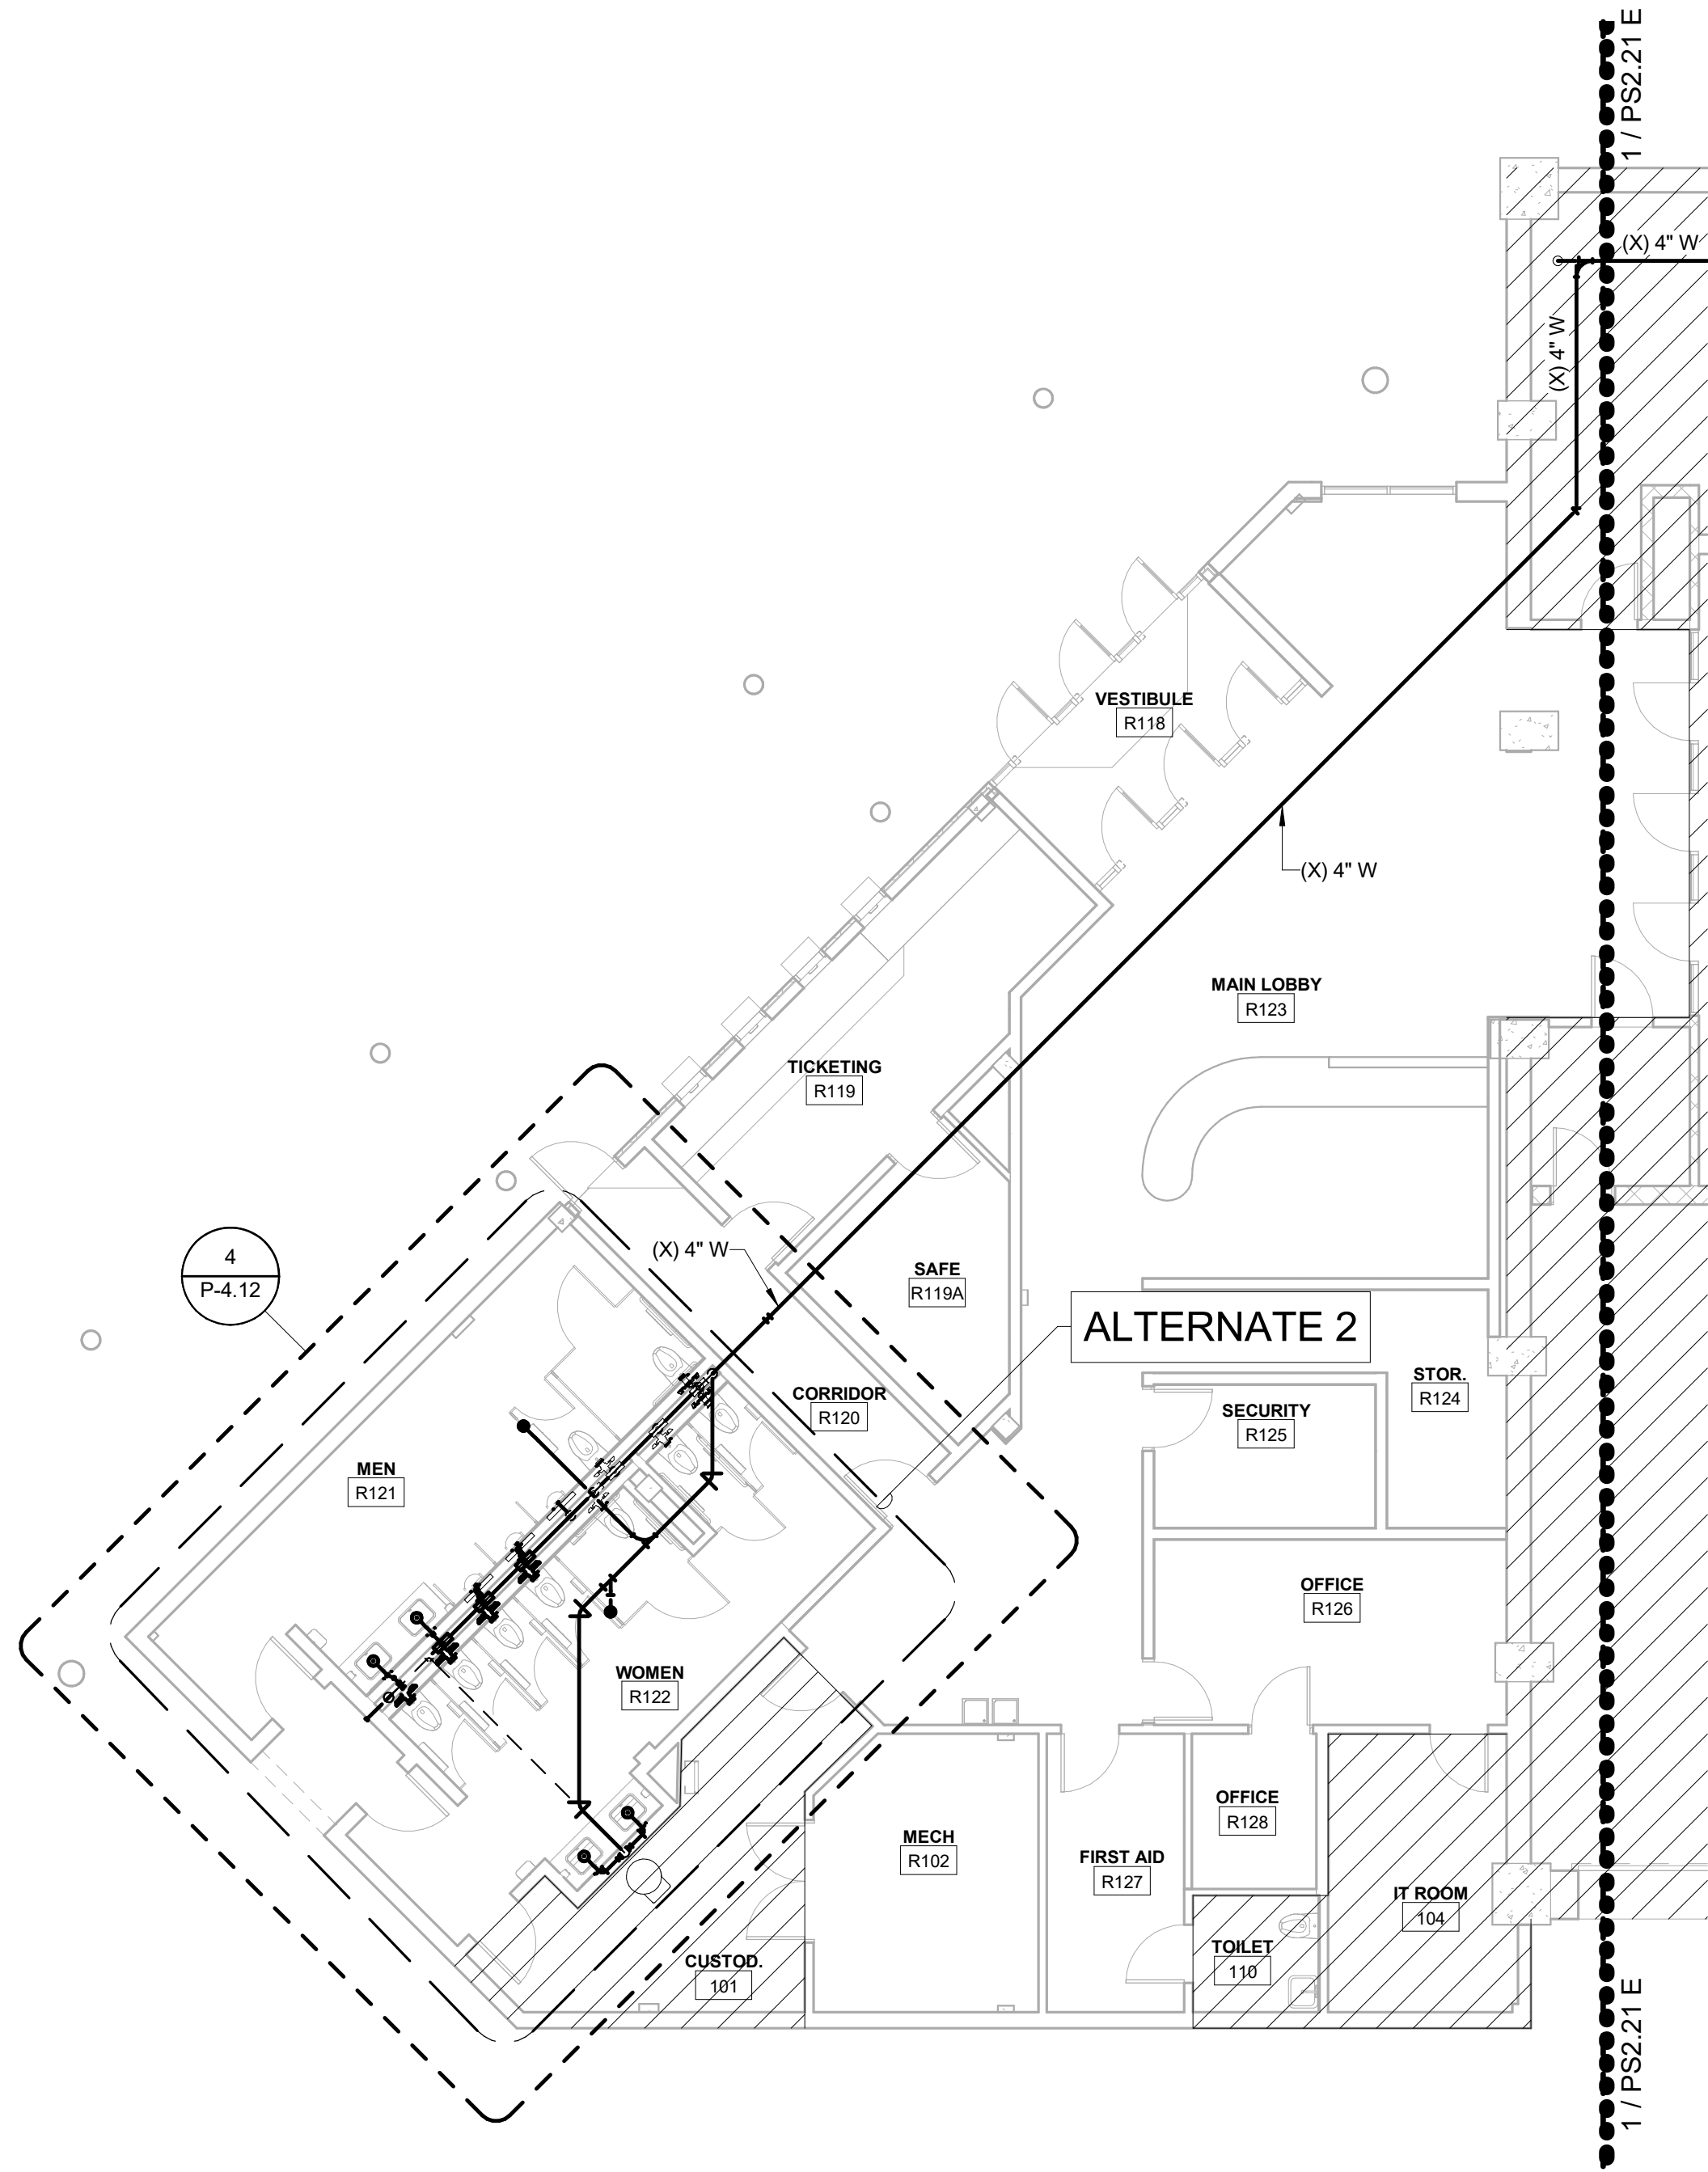


KEY PLAN

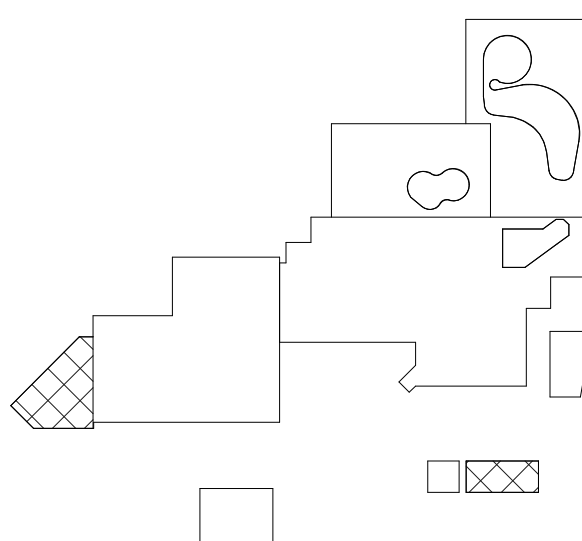

CBHF
Engineers, PLLC

2246 Yaupon Drive
Wilmington, NC 28401
Phone: 910.791.4000
Fax: 910.791.5266
www.cbhfenr.com
© Copyright 2025 CBHF Engineers, PLLC. NCIP # 0356

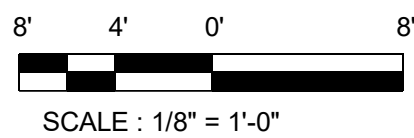

SCALE: 1/8" = 1'-0"



1ST FLOOR - MAIN ENTRY - WASTE-VENT

SCALE: 1/8" = 1'-0"

SCO #17-18042-02A
CODE: 42014-4G02
ITEM: 41414-4Y4A

900 LOGGERHEAD RD,
KURE BEACH, NC 28449

NORTH CAROLINA DEPT. OF
NATURAL & CULTURAL RESOURCES

ARCHITECT
310 1/2 WEST FRANKLIN STREET
CHAPEL HILL, NORTH CAROLINA 27516
TEL: 919.929.5244
FAX: 919.960.7967
WWW.S2OSTAKDESIGN.COM
LICENSE # 51679

LIFE SUPPORT SYSTEMS ENGINEER
56880 VENTURE LANE SUITE 205N
BEND, OR 97707
TELE: 619.423.6700
WWW.TJPENGINEERING.COM
LICENSE # C-3505

EXHIBIT DESIGNER
7001 DISCOVERY BOULEVARD
DUBLIN, OHIO 43017
TELE: 617.760.8690
WWW.ROTO.COM

STRUCTURAL ENGINEER
5430 WADE PARK BOULEVARD SUITE 400
RALEIGH, NC 27607
TELE: 919.832.5587
WWW.BENNETT-PLESS.COM
LICENSE # F-1105

MEP ENGINEER
2246 YAUPON DRIVE
WILMINGTON, NC 28401
TEL: 910.791.4000
FAX: 910.791.5266
WWW.CBHFENGINEERS.COM
LICENSE # P-0506

LIGHTING DESIGNER
10265 INDIANA COURT
RANCHO CUCAMONGA, CA 91730
TELE: 909.360.2900
WWW.LIGHTSWITCH.NET

CIVIL ENGINEER
2602 IRON GATE DRIVE SUITE 102
WILMINGTON, NC 28412
TELE: 910.343.9653
FAX: 910.343.9604
WWW.NTEENGINEERS.COM
LICENSE # P-3152

LANDSCAPE ARCHITECT
215 MORRIS STREET SUITE 150
DURHAM, NC 27701
TEL: 919.419.1199
FAX: 919.419.1669
WWW.SURFACE678.COM
LICENSE # C-098

FIRE PROTECTION ENGINEER
3412 ENTERPRISE DRIVE
WILMINGTON, NC 28405
TEL: 910.452.4210
WWW.CHEATHAMPA.COM
LICENSE # C-1073

COST ESTIMATOR
4819 EMPEROR BOULEVARD SUITE 400
DURHAM, NC 27703
TELE: 919.605.8952
WWW.PALACIOCOLLABORATIVE.COM

NOTE: IF THIS DRAWING IS NOT 30" X 42", IT IS A
REDUCED PRINT. REFER TO GRAPHIC SCALE.

NOT FOR
CONSTRUCTION

**NOT FOR
CONSTRUCTION**


NO.	DATE	DESCRIPTION
1	9-8-25	BID SET

FIRST FLOOR PLAN -
FRESHWATER HABITAT -
WASTE-VENT


PS2.21 E

	EXISTING BUILDING
	RENOVATED AREA
	UPFIT BY OTHERS
	1-HR RATED WALL
	2-HR RATED WALL
	3-HR RATED WALL

1. PLUMBING CONTRACTOR TO COORDINATE WITH OTHER TRADES PRIOR TO BEGINNING WORK.
2. REFER TO ARCHITECTURAL DRAWINGS FOR RATED ASSEMBLY UL NUMBERS (WALLS, FLOOR / CEILING, ETC.)
3. DRAWINGS: DRAWINGS ARE DIAGRAMMATIC AND MAY NOT COMPLETELY DESCRIBE EVERY DETAIL OF THE INSTALLATION. HOWEVER, CONTRACTOR IS RESPONSIBLE FOR PROVIDING ALL REQUIRED SYSTEMS INCLUDING ALL REQUIRED EQUIPMENT AND ACCESSORIES TO OBTAIN FULLY FUNCTIONING PLUMBING SYSTEMS.
4. EQUIPMENT LOCATION: DETERMINE EXACT EQUIPMENT AND MATERIALS LOCATIONS TO PROVIDE BEST ARRANGEMENT AND TO FACILITATE PROPER MAINTENANCE AND SERVING OF EQUIPMENT.
5. LISTING AND LABELING: ALL EQUIPMENT SHALL BE LABELED OR LISTED BY UL OR OTHER APPROVED TESTING AGENCY WHERE REQUIRED.

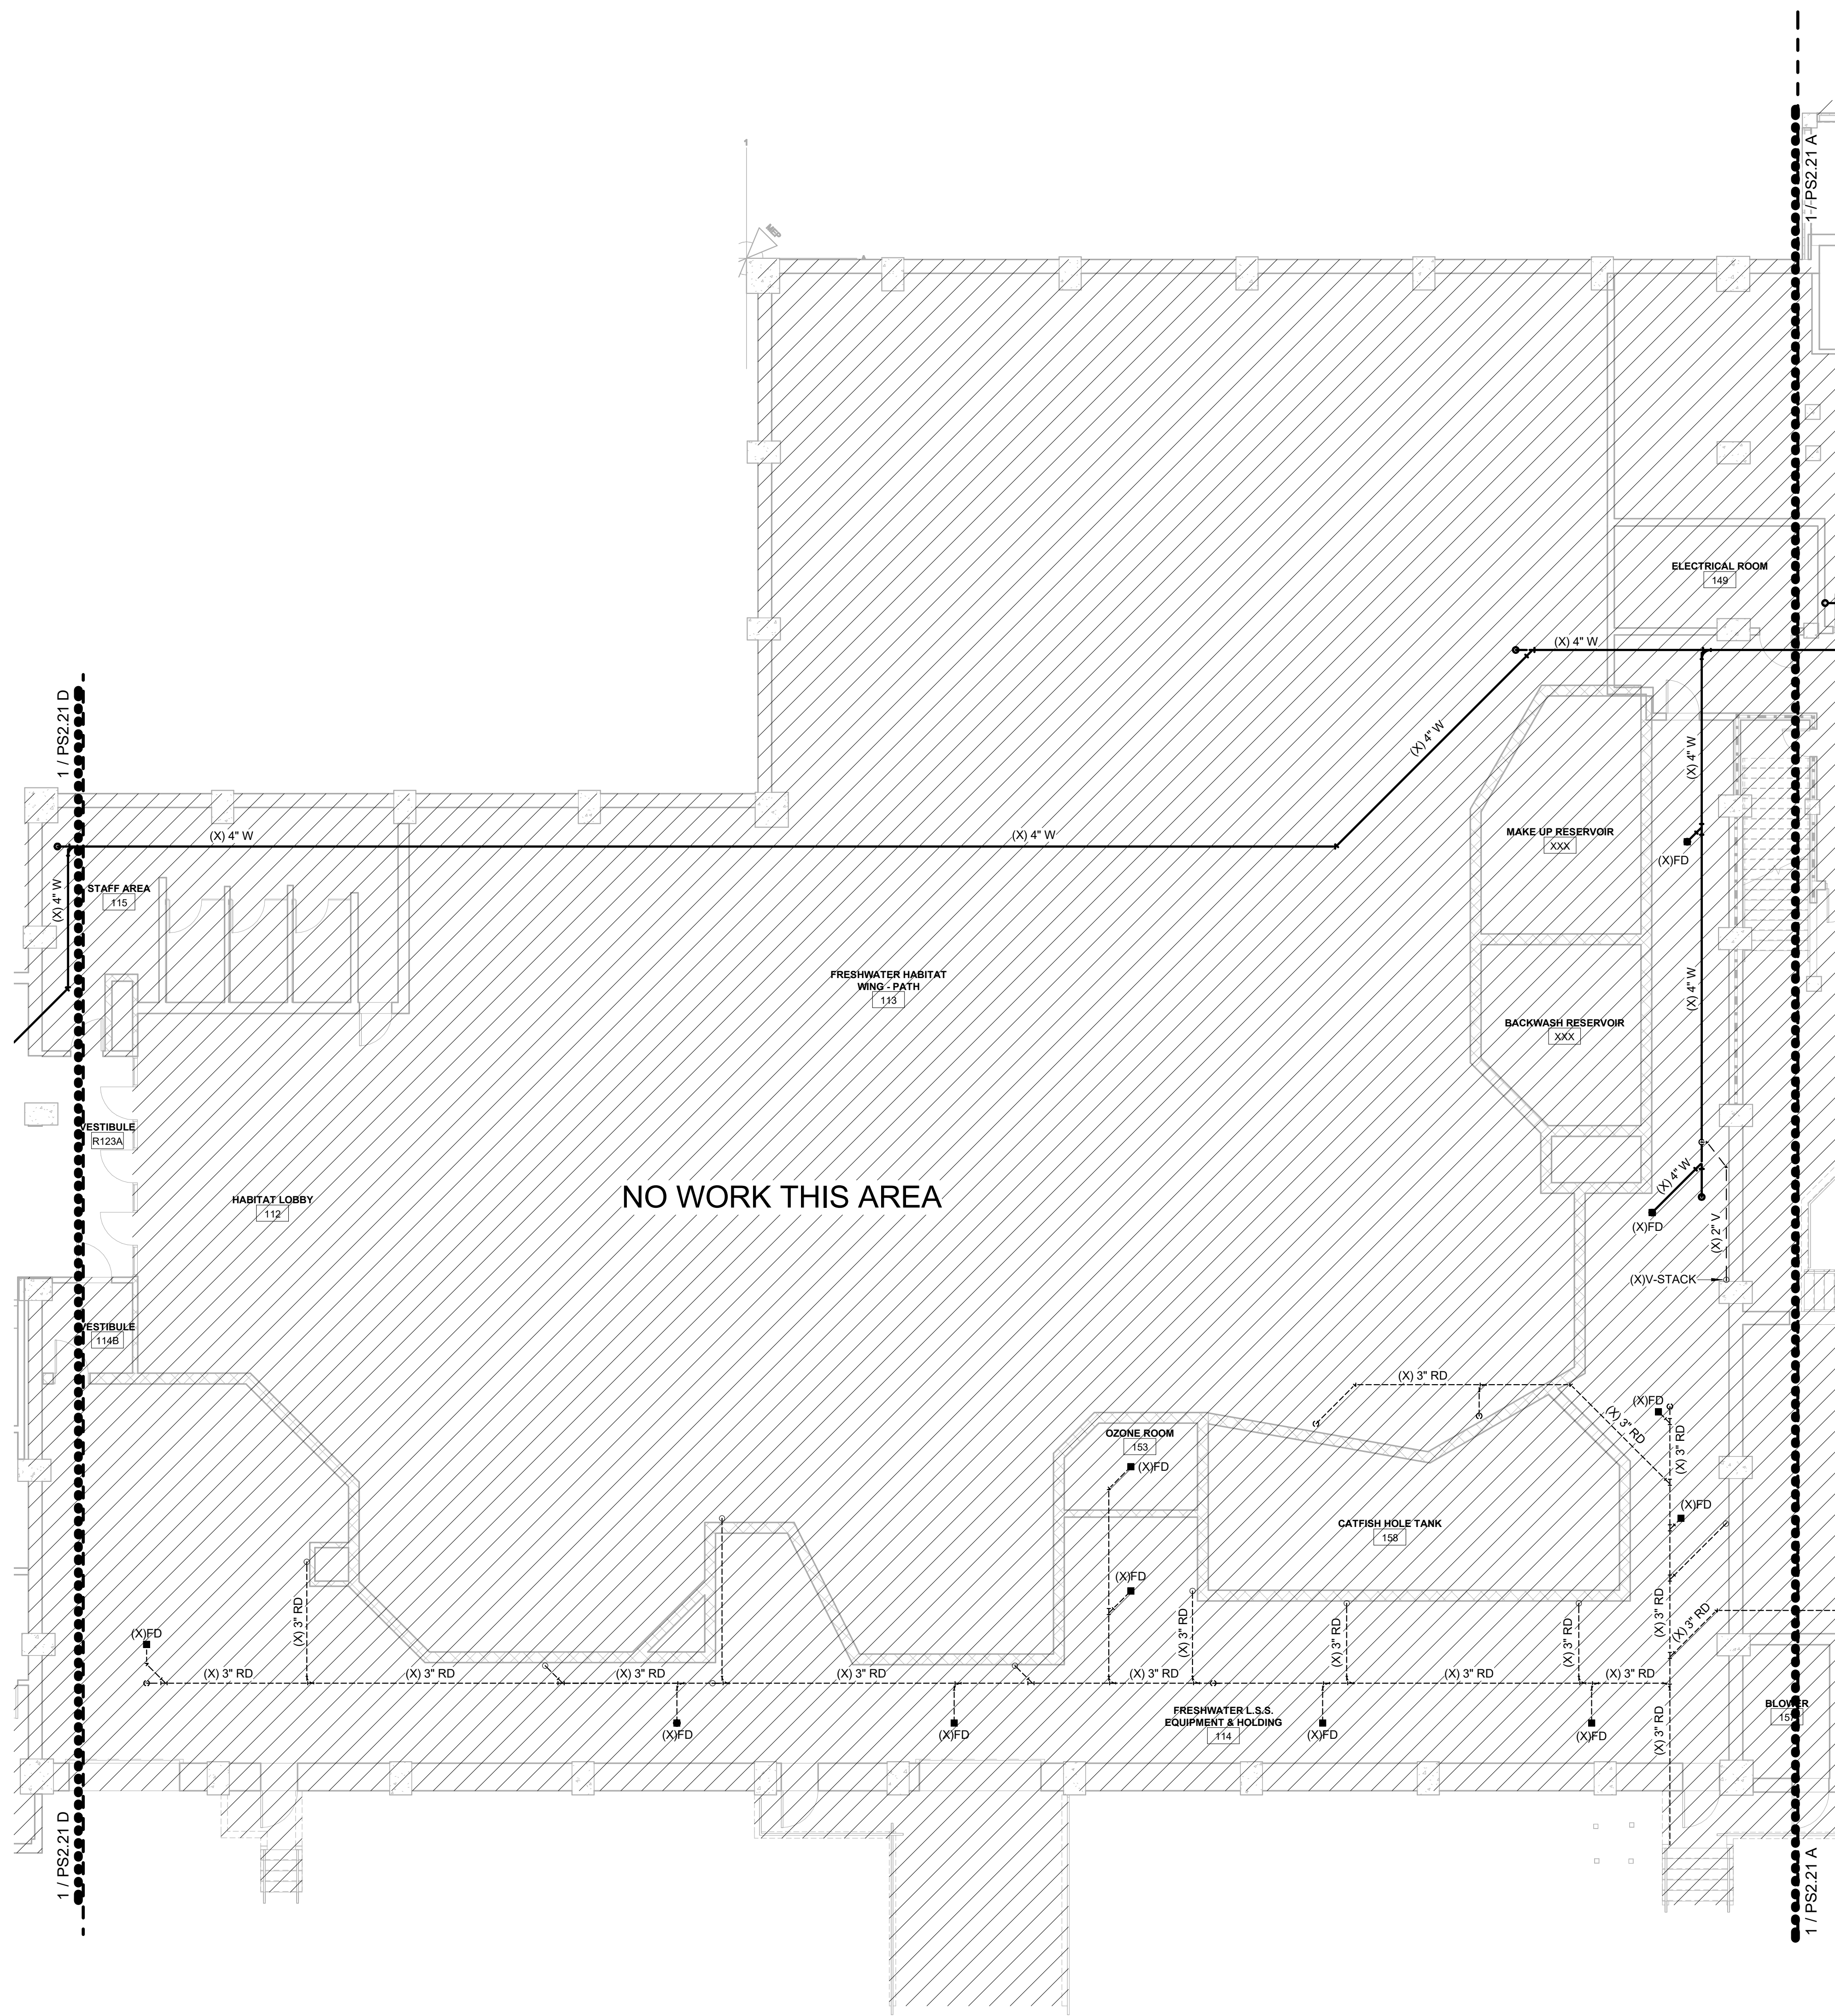


KEY PLAN

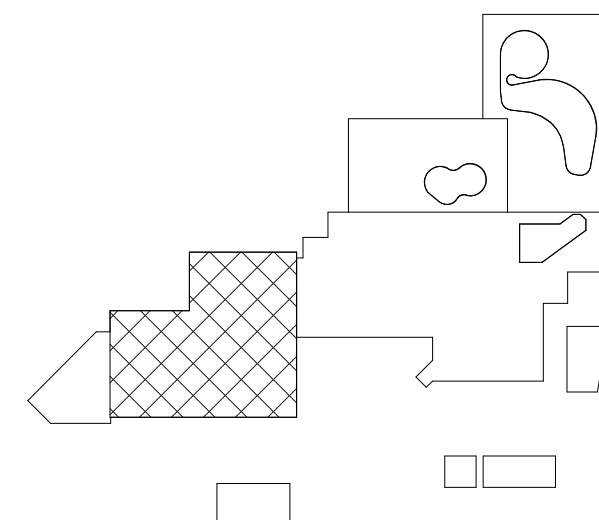

CBHF
Engineers, PLLC

2246 Yaupon Drive
Wilmington, NC 28401
Phone: 910.791.4000
Fax: 910.791.5266
www.cbhfengineers.com
Copyright 2025 CBHF Engineers, P.L.L.C. NC# P-051

© Copyright 2025 CBHF Engineers, PLLC NC# P-0506

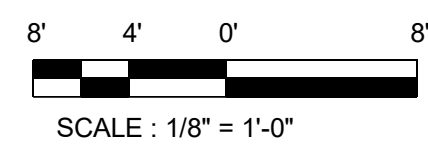

1ST FLOOR - FRESHWATER HABITAT - WASTE-VENT

SCO #17-18042-02A
CODE: 42014-4G02
ITEM: 41414-4Y4A

900 LOGGERHEAD RD,
KURE BEACH, NC 28449

NORTH CAROLINA DEPT. OF
NATURAL & CULTURAL RESOURCES

ARCHITECT
310 1/2 WEST FRANKLIN STREET
CHAPEL HILL, NORTH CAROLINA 27516
TEL: 919.929.5244
FAX: 919.960.7967
WWW.S2OSTAKDESIGN.COM
LICENSE # 51679

LIFE SUPPORT SYSTEMS ENGINEER
56880 VENTURE LANE SUITE 205N
BEND, OR 97707
TELE: 619.423.6700
WWW.TJPENGINEERING.COM
LICENSE # C-3505

EXHIBIT DESIGNER
7001 DISCOVERY BOULEVARD
DUBLIN, OHIO 43017
TELE: 617.760.8690
WWW.ROTO.COM

STRUCTURAL ENGINEER
5430 WADE PARK BOULEVARD SUITE 400
RALEIGH, NC 27607
TELE: 919.832.5587
WWW.BENNETT-PLESS.COM
LICENSE # F-1105

MEP ENGINEER
2246 YAUPON DRIVE
WILMINGTON, NC 28401
TEL: 910.791.4000
FAX: 910.791.5266
WWW.CBHENGINEERS.COM
LICENSE # P-0506

LIGHTING DESIGNER
10265 INDIANA COURT
RANCHO CUCAMONGA, CA 91730
TELE: 909.360.2900
WWW.LIGHTSWITCH.NET

CIVIL ENGINEER
2602 IRON GATE DRIVE SUITE 102
WILMINGTON, NC 28412
TELE: 910.343.9653
FAX: 910.343.9604
WWW.NTENGINEERS.COM
LICENSE # P-3152

LANDSCAPE ARCHITECT
215 MORRIS STREET SUITE 150
DURHAM, NC 27701
TEL: 919.419.1199
FAX: 919.419.1669
WWW.SURFACE678.COM
LICENSE # C-098

FIRE PROTECTION ENGINEER
3412 ENTERPRISE DRIVE
WILMINGTON, NC 28405
TEL: 910.452.4210
WWW.CHEATHAMPA.COM
LICENSE # C-1073

COST ESTIMATOR
4819 EMPEROR BOULEVARD SUITE 400
DURHAM, NC 27703
TELE: 919.605.8952
WWW.PALACIOCOLLABORATIVE.COM



NO.	DATE	DESCRIPTION
-----	------	-------------

1	9-8-25	BID SET
---	--------	---------

SECOND FLOOR PLAN

TOUCH AND SHARK TANK

WASTE-VENT

CBHF
Engineers, PLLC

2246 Yaupon Drive
Wilmington, NC 28401
Phone: 910.791.4000
Fax: 910.791.5266
www.cbhfengineers.com
Copyright 2025 CBHF Engineers, P.L.L.C. NC# P-051

© Copyright 2025 CBHF Engineers, PLLC NC# P-059

8' 4' 0' 8'



SCALE : 1/8" = 1'-0"


2ND FLOOR - SHARK TANK - WASTE-VENT

SCALE: 1/8" = 1'-0'

1

1

 PS2.23 A



1. PLUMBING CONTRACTOR TO COORDINATE WITH OTHER TRADES PRIOR TO BEGINNING WORK.
2. REFER TO ARCHITECTURAL DRAWINGS FOR RATED ASSEMBLY U.L. NUMBERS (WALLS, FLOOR / CEILING ETC.)
3. DRAWINGS: DRAWINGS ARE DIAGRAMMATIC AND MAY NOT COMPLETELY DESCRIBE EVERY DETAIL OF THE INSTALLATION. HOWEVER, CONTRACTOR IS RESPONSIBLE FOR PROVIDING ALL COMPONENTS INCLUDING ALL REQUIRED EQUIPMENT AND ACCESSORIES TO OBTAIN FULLY FUNCTIONING PLUMBING SYSTEMS.
4. EQUIPMENT LOCATIONS: DETERMINE EXACT EQUIPMENT AND MATERIALS LOCATIONS TO PROVIDE BEST ARRANGEMENT AND TO FACILITATE PROPER MAINTENANCE AND SERVING OF EQUIPMENT.
5. LISTING AND LABELING: ALL EQUIPMENT SHALL BE LABELED OR LISTED BY UL OR OTHER APPROVED TESTING AGENCY WHERE REQUIRED.

8' 4' 0' 8'



SCALE : 1/8" = 1'-0"

3RD FLOOR - SOUTHEAST WING - WASTE-VENT
SCALE : 1/8" = 1'-0"

1

SCO #17-18042-02A
CODE: 42014-4G02
ITEM: 41414-4Y4A

NORTH CAROLINA DEPT. OF
NATURAL & CULTURAL RESOURCES

ARCHITECT
310 1/2 WEST FRANKLIN STREET
CHAPEL HILL, NORTH CAROLINA 27516
TELE: 919.929.5244
FAX: 919.960.7967
WWW.S2CSTAKDESIGN.COM
LICENSE # 51679

LIFE SUPPORT SYSTEMS ENGINEER
56880 VENTURE LANE SUITE 205N
BEND, OR 97707
TELE: 619.423.8700
WWW.TJENGINEERING.COM
LICENSE # C-3505

EXHIBIT DESIGNER
7001 DISCOVERY BOULEVARD
DUBLIN, OHIO 43017
TELE: 617.760.8690
WWW.ROFO.COM

STRUCTURAL ENGINEER
5430 WADE PARK BOULEVARD SUITE 400
RALEIGH, NC 27607
TELE: 919.832.5587
WWW.BENNETT-FLEISS.COM
LICENSE # F-1105

MEP ENGINEER
2246 YAUPON DRIVE
WILMINGTON, NC 28401
TELE: 910.791.4000
FAX: 910.791.5266
WWW.CBHFENGINEERS.COM
LICENSE # P-0506

LIGHTING DESIGNER
10265 INDIANA COURT
RANCHO CUCAMONGA, CA 91730
TELE: 909.360.2900
WWW.LIGHTSWITCH.NET

CIVIL ENGINEER
2602 IRON GATE DRIVE SUITE 102
WILMINGTON, NC 28412
TELE: 910.343.9653
FAX: 910.343.9604
WWW.NTEENGINEERS.COM
LICENSE # P-3152

LANDSCAPE ARCHITECT
215 MORRIS STREET SUITE 150
DURHAM, NC 27701
TELE: 919.419.1199
FAX: 919.419.1669
WWW.SURFACE678.COM
LICENSE # C-098

FIRE PROTECTION ENGINEER
3412 ENTERPRISE DRIVE
WILMINGTON, NC 28405
TELE: 910.452.4210
WWW.CHEATHAMPA.COM
LICENSE # C-1073

COST ESTIMATOR
4819 EMPEROR BOULEVARD SUITE 400
DURHAM, NC 27703
TELE: 919.405.8952
WWW.PALACIOCOLLABORATIVE.COM

SEAL
23551
ENGINEER
DAVID M. HAHN

PS2.23 B

	EXISTING BUILDING
	RENOVATED AREA
	UPFIT BY OTHERS
	1-HR RATED WALL
	2-HR RATED WALL
	3-HR RATED WALL

1. PLUMBING CONTRACTOR TO COORDINATE WITH OTHER TRADES PRIOR TO BEGINNING WORK.
2. REFER TO ARCHITECTURAL DRAWINGS FOR RATED ASSEMBLY UL NUMBERS (WALLS, FLOOR / CEILING, ETC.)
3. DRAWINGS: DRAWINGS ARE DIAGRAMMATIC AND MAY NOT COMPLETELY DESCRIBE EVERY DETAIL OF THE INSTALLATION. HOWEVER, CONTRACTOR IS RESPONSIBLE FOR PROVIDING ALL NECESSARY SYSTEMS INCLUDING ALL REQUIRED EQUIPMENT AND ACCESSORIES TO OBTAIN FULLY FUNCTIONING PLUMBING SYSTEMS.
4. EQUIPMENT LOCATIONS: DETERMINE EXACT EQUIPMENT AND MATERIALS LOCATIONS TO PROVIDE BEST ARRANGEMENT AND TO FACILITATE PROPER MAINTENANCE AND SERVING OF EQUIPMENT.
5. TESTING AND LABELING: ALL EQUIPMENT SHALL BE LABELED OR LISTED BY UL OR OTHER APPROVED TESTING AGENCY WHERE REQUIRED.

1	4"RDL DOWN. SEE SHEET PS2.22B FOR CONTINUATION
---	--



8' 4' 0' 8'



SCALE : 1/8" = 1'-0"

2246 Yaupon Drive
Wilmington, NC 28401
Phone: 910.791.4000
Fax: 910.791.5266
www.cbhfengineers.com
Copyright 2025 CBHF Engineers, PLLC NC# P-0506

1

FORT FISHER AQUARIUM RENOVATION & EXPANSION: PHASE 1

900 LOGGERHEAD RD,
JURE BEACH, NC 28449

NORTH CAROLINA DEPT. OF
NATURAL & CULTURAL RESOURCE

SZOSTAK DESIGN, INC.

ARCHITECT
310 1/2 WEST FRANKLIN STREET
CHAPEL HILL, NORTH CAROLINA 27516
TEL: 919.929.5244
FAX: 919.960.7967
WWW.S2OSTAKDESIGN.COM
LICENSE # 51679

TJP ENGINEERING, INC

LIFE SUPPORT SYSTEMS ENGINEER
56880 VENTURE LANE SUITE 205N
BEND, OR 97707
TELE: 619.423.8700
WWW.TJPEENGINEERING.COM
LICENSE # C-3505

ROTO GROUP, LLC.

EXHIBIT DESIGNER
7001 DISCOVERY BOULEVARD
DUBLIN, OHIO 43017
TELE: 617.760.8690
WWW.ROFO.COM

BENNETT & PLESS

STRUCTURAL ENGINEER
5430 WADE PARK BOULEVARD SUITE 400
RALEIGH, NC 27607
TELE: 919.832.5587
WWW.BENNETT-PLESS.COM
LICENSE # F-1105

CBHF ENGINEERS, PLLC

MEP ENGINEER
2246 YAJPON DRIVE
WILMINGTON, NC 28401
TELE: 910.791.4000
FAX: 910.791.5266
WWW.CMHFENGINEERS.COM
LICENSE # P-0506

LIGHTSWITCH

LIGHTING DESIGNER
10265 INDIANA COURT
RANCHO CUCAMONGA, CA 91730
TELE: 909.360.2900
WWW.LIGHTSWITCH.NET

TUNSTALL CONSULTING ENGINEERS PLLC

CIVIL ENGINEER
2602 IRON GATE DRIVE SUITE 102
WILMINGTON, NC 28412
TELE: 910.343.9653
FAX: 910.343.9604
WWW.NTENGINEERS.COM
LICENSE # P-3152

SURFACE 678, PA

LANDSCAPE ARCHITECT
215 MORRIS STREET SUITE 150
DURHAM, NC 27701
TELE: 919.419.1199
FAX: 919.419.1669
WWW.SURFACE678.COM
LCSIFF-IL-000

CHEATHAM & ASSOCIATES, PA

FIRE PROTECTION ENGINEER
3412 ENTERPRISE DRIVE
WILMINGTON, NC 28405
TELE: 910.452.4210
WWW.CHEATHAMPA.COM
LICENSE # C-1073

PALACIO COLLABORATIVE

COST ESTIMATOR
4819 EMPEROR BOULEVARD SUITE 400
DURHAM, NC 27703
TELE: 919.605.8952
WWW.PALACIOCOLLABORATIVE.COM

NOTE: IF THIS DRAWING IS NOT 30" X 42", IT
REDUCED PRINT. REFER TO GRAPHIC SCALE

NOT FOR
CONSTRUCTION



**NOT FOR
CONSTRUCTION**


NO.	DATE	DESCRIPTION
1	9-8-25	BID SET

ROOF PLAN - SHARK TANK

PS2.24 B

FLOOR PLAN SHEET NOTES

1. PLUMBING CONTRACTOR TO COORDINATE WITH OTHER TRADES PRIOR TO BEGINNING WORK.
2. REFER TO ARCHITECT'S SPECIFICATIONS FOR RATED ASSEMBLY UL NUMBERS (WALLS, FLOOR / CEILING, ETC.).
3. FINISHES: DRAWINGS ARE DIAGRAMMATIC AND MAY NOT COMPLETELY DESCRIBE EVERY DETAIL OF THE INSTALLATION. HOWEVER, CONTRACTOR IS RESPONSIBLE FOR FURNISHING COMPLETE SYSTEMS INCLUDING ALL REQUIRED EQUIPMENT AND ACCESSORIES TO OBTAIN FULLY FUNCTIONING SYSTEM.
4. EQUIPMENT LOCATIONS: DETERMINE EXIST EQUIPMENT AND MATERIALS LOCATIONS TO DETERMINE BEST AREA FOR INSTALLATION. FACILITATE PROPER MAINTENANCE AND SERVING OF EQUIPMENT.
5. LABELING AND LABELING: ALL EQUIPMENT SHALL BE LABELED OR LISTED BY UL OR OTHER APPROVED TESTING AGENCY WHERE REQUIRED.

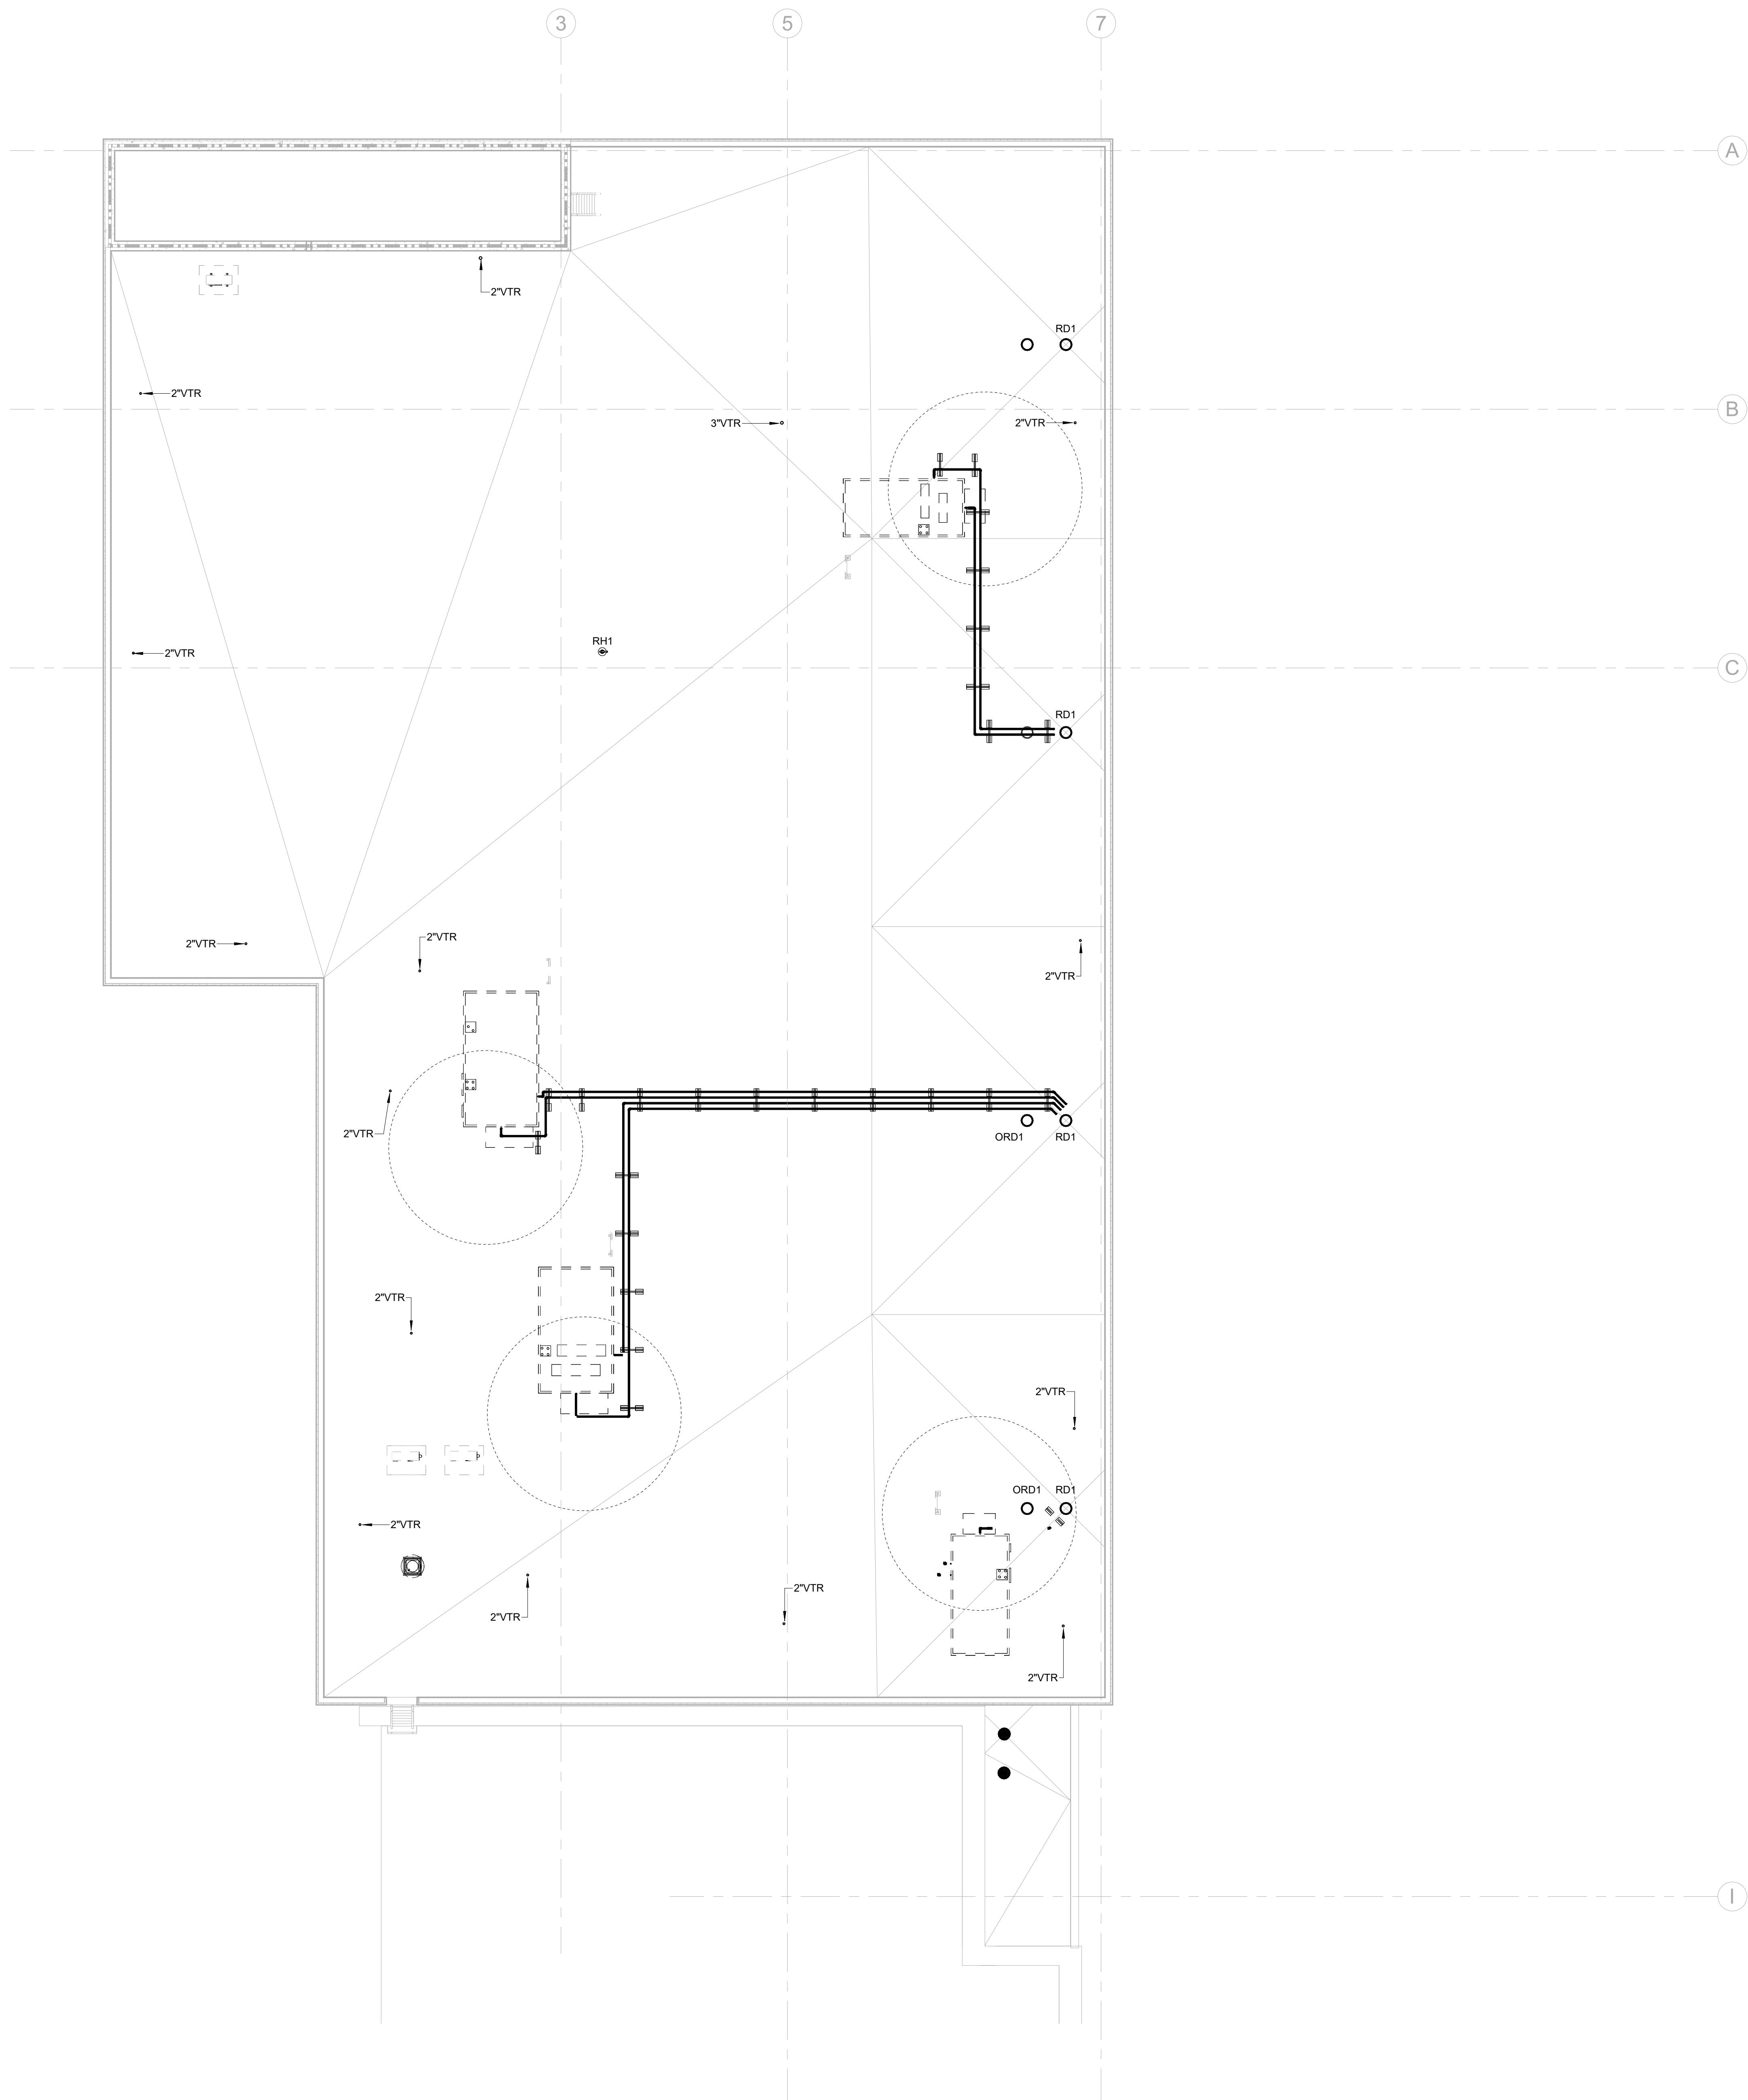


KEY PLAIN

CBHF
Engineers, PLLC

2246 Yaupon Drive
Wilmington, NC 28401
Phone: 910.791.4000
Fax: 910.791.5266
www.cbhfengineers.com
Copyright 2025 CBHF Engineers, PLLC NC# P-0506

© Copyright 2025 CBHF Engineers, PLLC NC# P-0506

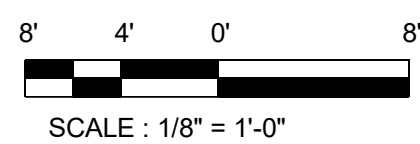

ENLARGED SHARKTANK ROOF PLAN
SCALE : 1/8" = 1'-0"

SZOSTAK DESIGN, INC.

ARCHITECT
310 1/2 WEST FRANKLIN STREET
CHAPEL HILL, NORTH CAROLINA 27514
TEL: 919.929.5244
FAX: 919.960.7967
WWW.SZOSTAKDESIGN.COM
LICENSE # 31079

TJP ENGINEERING, INC.

LIFE SUPPORT SYSTEMS ENGINEER
56880 VENTURE LANE SUITE 205N
BEND, OR 97007
TEL: 503.433.0300
WWW.TJPEENGINEERING.COM
LICENSE # C-3505

ROTO GROUP, LLC.

EXHIBIT DESIGNER
7001 DISCOVERY BOULEVARD
DUBLIN, OHIO 43017
TEL: 617.760.6695
WWW.ROTO.COM

BENNETT & PLESS

STRUCTURAL ENGINEER
5430 WADE PARK BOULEVARD SUITE 400
RALEIGH, NC 27607
TEL: 919.832.5587
WWW.BENNETT-PLESS.COM
LICENSE # F-1105

CBHF ENGINEERS, PLLC

MFP ENGINEER
2246 YAUPON DRIVE
WILMINGTON, NC 28401
TEL: 910.791.4000
FAX: 910.791.2546
WWW.CBHFENGINEERS.COM
LICENSE # P-6564

LIGHTSWITCH

LIGHTING DESIGNER
10365 INDIANA COURT
RANCHO CUCAMONGA, CA 91730
TEL: 909.360.0000
WWW.LIGHTSWITCH.NET

TUNSTALL CONSULTING ENGINEERS PLLC

CIVIL ENGINEER
2405 BROWN GATE DRIVE SUITE 102
WILMINGTON, NC 28412
TEL: 910.343.8433
FAX: 910.343.9044
WWW.TUNSTALLENGINEERS.COM
LICENSE # F-3132

SURFACE 678, PA

LANDSCAPE ARCHITECT
215 MORRIS STREET SUITE 150
DURHAM, NC 27701
TEL: 919.419.1199
FAX: 919.419.1689
WWW.SURFACE678.COM
LICENSE # C-096

CHEATHAM & ASSOCIATES, PA

FIRE PROTECTION ENGINEER
3412 ENTERPRISE DRIVE
WILMINGTON, NC 28405
TEL: 910.452.4510
WWW.CHEATHAMPA.COM
LICENSE # C-1073

PALACIO COLLABORATIVE

COST ESTIMATOR
4815 ENTERPRISE BOULEVARD SUITE 400
DURHAM, NC 27703
TEL: 919.453.9100
WWW.PALACIOCOLLABORATIVE.COM

NOTE: IF THIS DRAWING IS NOT 30" X 42", IT IS A
REDUCED PRINT. REFER TO GRAPHIC SCALE.

NOT FOR
CONSTRUCTION



NOT FOR
CONSTRUCTION

NO.	DATE	DESCRIPTION
1	9-8-25	BID SET

FIRST FLOOR PLAN -
DOMESTIC WATER

PW2.11

FLOOR PLAN LEGEND


- EXISTING BUILDING
- RENOVATED AREA
- UPFIT BY OTHERS
- 1-HR RATED WALL
- 2-HR RATED WALL
- 3-HR RATED WALL

PHASING REQUIREMENTS

REFER TO ARCHITECTURAL DRAWING SET FOR CONSTRUCTION PHASING REQUIREMENTS. COORDINATE WORK CLOSELY WITH GENERAL CONTRACTOR AND ALL OTHER TRADES.

FLOOR PLAN SHEET NOTES

- PLUMBING CONTRACTOR TO COORDINATE WITH OTHER TRADES PRIOR TO BEGINNING WORK.
- REFER TO ARCHITECTURAL DRAWINGS FOR RATED ASSEMBLY UL NUMBERS (WALLS, FLOOR / CEILING, ETC.).
- DRAWINGS: DRAWINGS ARE DIAGRAMMATIC AND MAY NOT COMPLETELY DESCRIBE EVERY DETAIL OF THE INSTALLATION. HOWEVER, CONTRACTOR IS RESPONSIBLE FOR FURNISHING COMPLETE SYSTEMS INCLUDING ALL REQUIRED EQUIPMENT AND ACCESSORIES TO OBTAIN FULLY FUNCTIONING PLUMBING SYSTEMS.
- EQUIPMENT LOCATIONS: DETERMINE EXACT EQUIPMENT AND MATERIALS LOCATIONS TO PROVIDE BEST ARRANGEMENT AND TO FACILITATE PROPER MAINTENANCE AND SERVICING OF EQUIPMENT.
- LISTING AND LABELING: ALL EQUIPMENT SHALL BE LABELED OR LISTED BY UL OR OTHER APPROVED TESTING AGENCY WHERE REQUIRED.

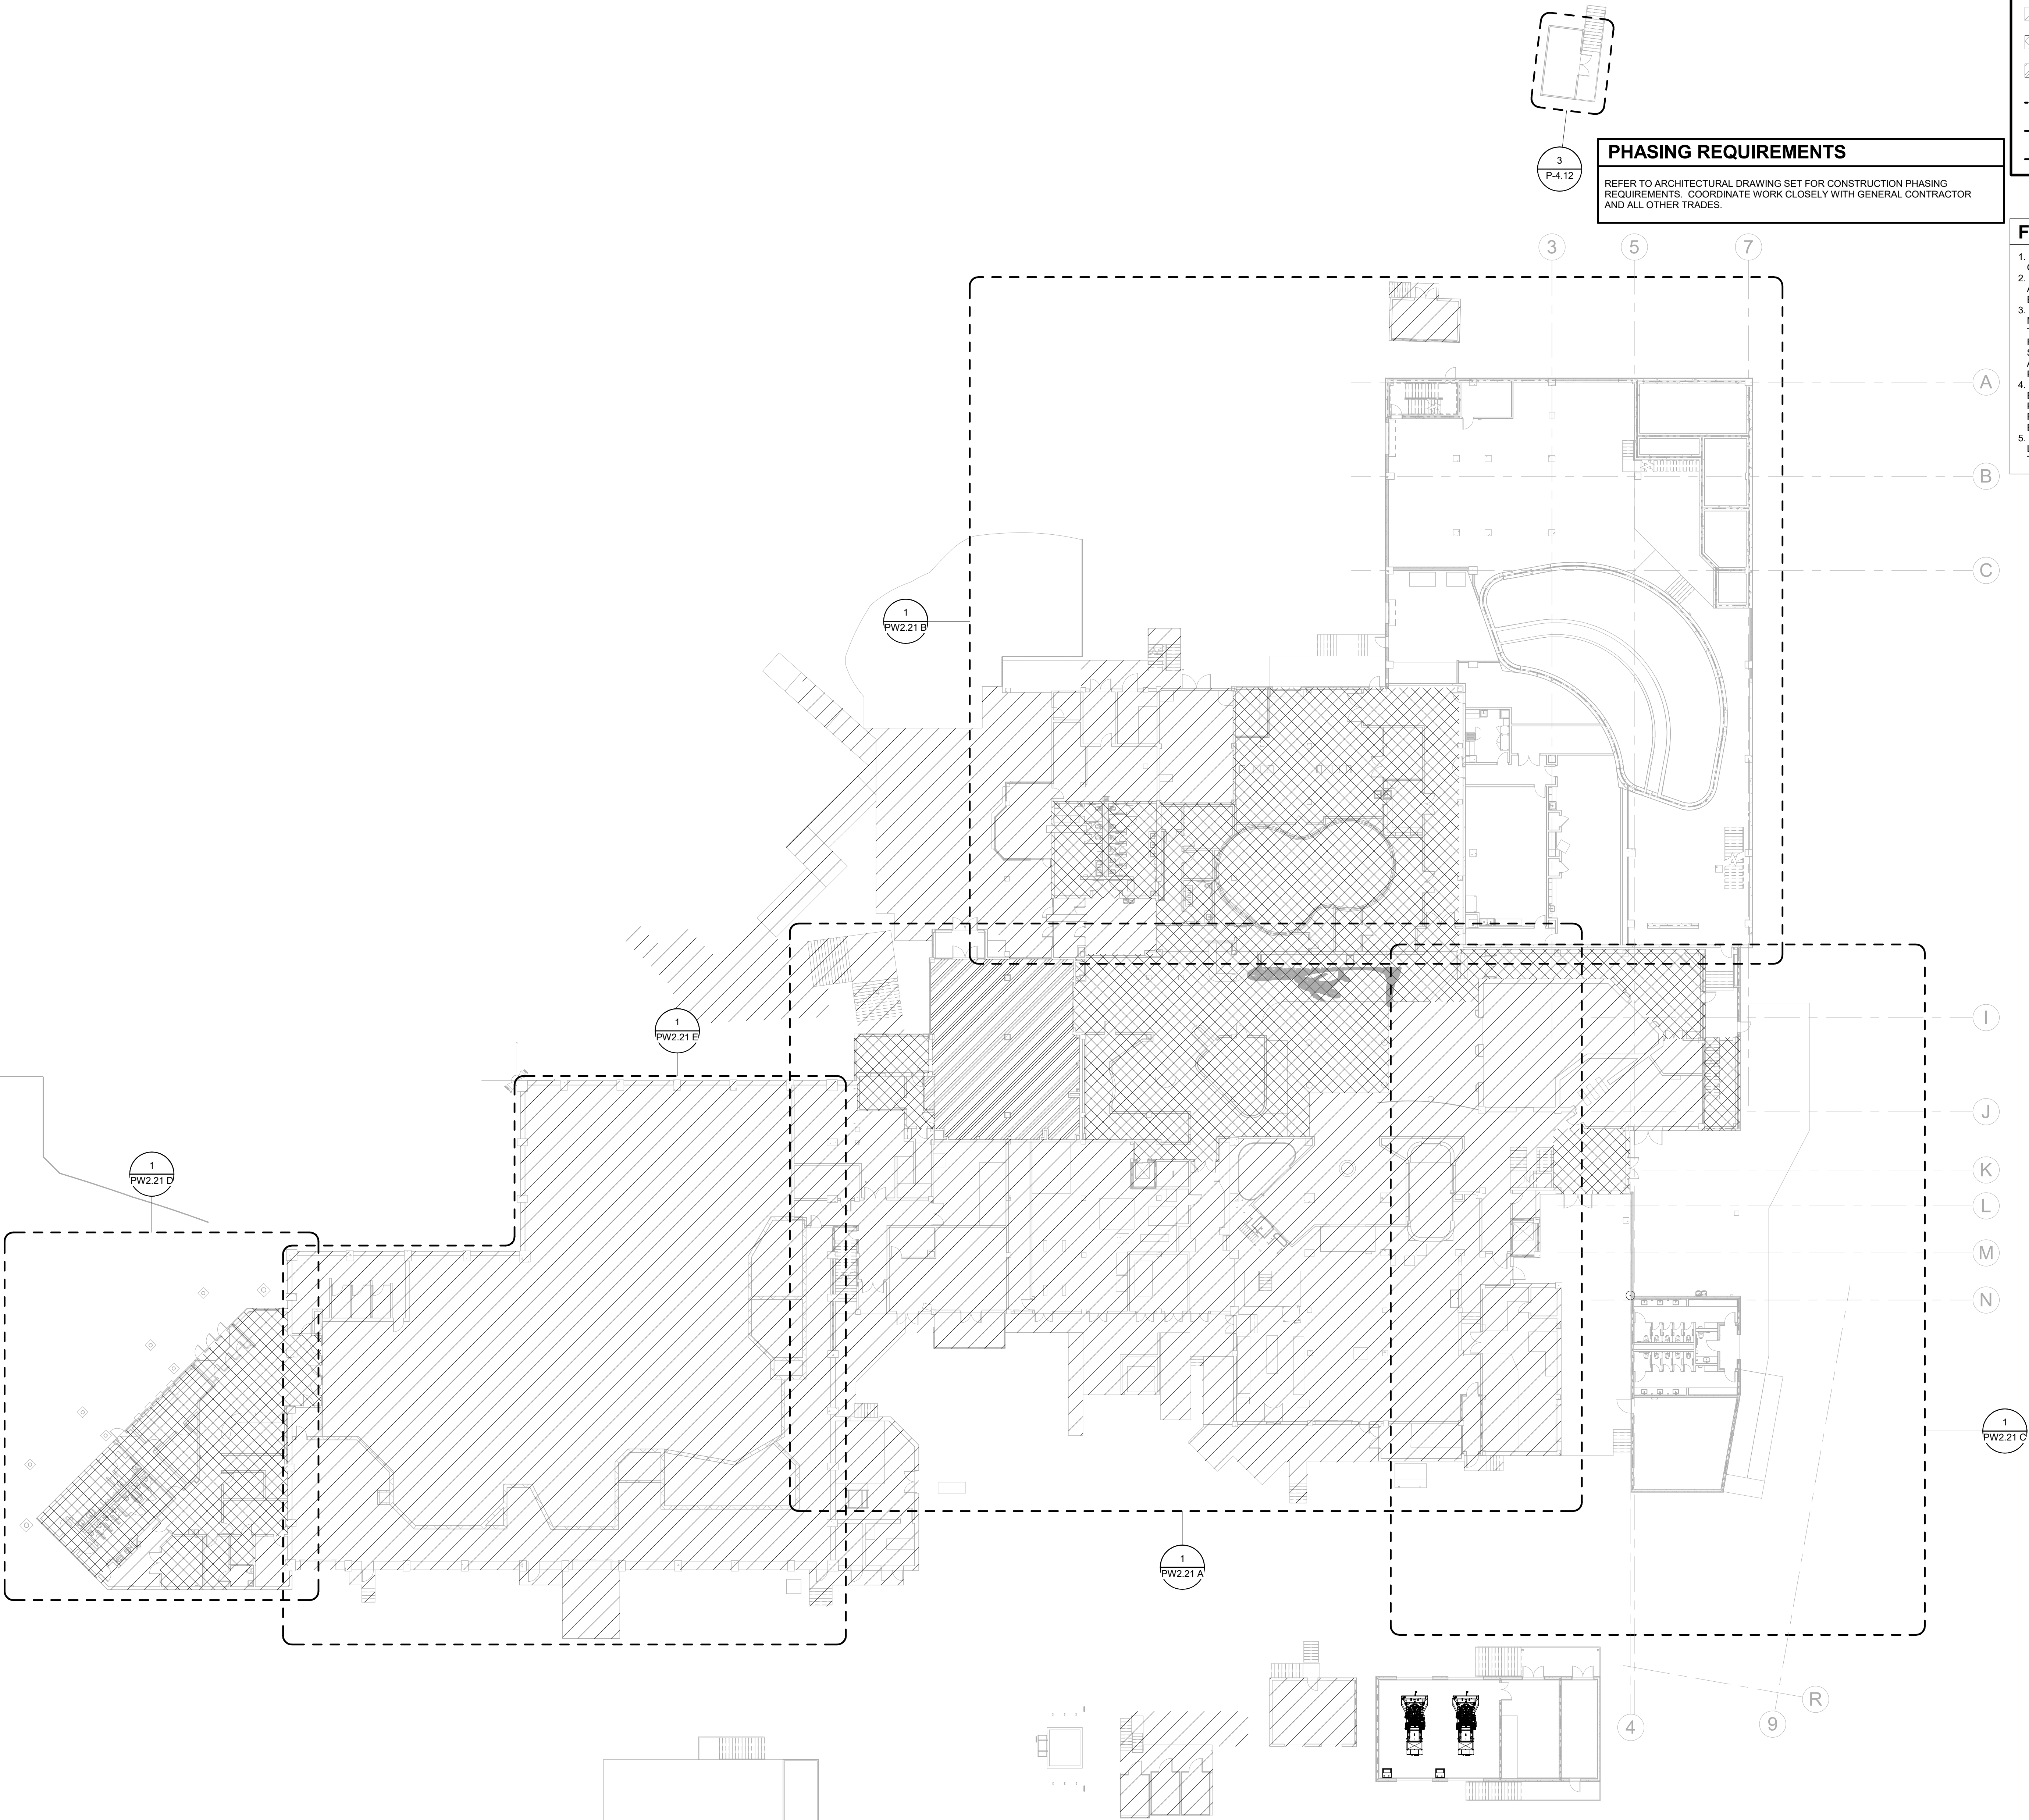

CBHF
Engineers, PLLC

2246 Yaupon Drive
Wilmington, NC 28401
Phone: 910.791.4000
Fax: 910.791.5266
www.cbhfenr.com
© Copyright 2025 CBHF Engineers, PLLC. NCIP P-0356

20' 10' 20'
SCALE: 1" = 20'-0"

OVERALL 1ST FLOOR - DOMESTIC WATER PLAN
SCALE: 1" = 20'-0"

SZOSTAK DESIGN

FORT FISHER
AQUARIUM
RENOVATION
& EXPANSION:
PHASE 1

SCO #17-18042-02A
CODE: 42014-4G02
ITEM: 41414-4Y4A

900 LOGGERHEAD RD,
KURE BEACH, NC 28449

NORTH CAROLINA DEPT. OF
NATURAL & CULTURAL RESOURCES

SZOSTAK DESIGN, INC.

ARCHITECT
310 1/2 WEST FRANKLIN STREET
CHAPEL HILL, NORTH CAROLINA 27514
TEL: 919.929.5244
FAX: 919.960.7967
WWW.SZOSTAKDESIGN.COM
LICENSE # 31079

TJP ENGINEERING, INC.

LIFE SUPPORT SYSTEMS ENGINEER
5680 VENTURE LANE SUITE 205N
BEND, OR 97707
TEL: 503.433.0300
WWW.TJPEENGINEERING.COM
LICENSE # C-3505

ROTO GROUP, LLC.

EXHIBIT DESIGNER
7001 DISCOVERY BOULEVARD
DURHAM, NC 27707
TEL: 919.282.5587
WWW.ROTO.COM

BENNETT & PLESS

STRUCTURAL ENGINEER
5430 WADE PARK BOULEVARD SUITE 400
RALEIGH, NC 27607
TEL: 919.832.5587
WWW.BENNETT-PLESS.COM
LICENSE # F-1105

CBHF ENGINEERS, PLLC

MFP ENGINEER
2246 YAUPOH DRIVE
WILMINGTON, NC 28401
TEL: 910.791.4000
FAX: 910.791.2556
WWW.CBHFENGINEERS.COM
LICENSE # P-6554

LIGHTSWITCH

LIGHTING DESIGNER
10365 INDIANA COURT
RANCHO CUCAMONGA, CA 91730
TEL: 909.360.0900
WWW.LIGHTSWITCH.NET

TUNSTALL CONSULTING ENGINEERS PLLC

CIVIL ENGINEER
2405 BROWN GATE DRIVE SUITE 102
WILMINGTON, NC 28412
TEL: 910.343.9433
FAX: 910.343.9404
WWW.TUNSTALLENGINEERS.COM
LICENSE # F-3132

SURFACE 678, PA

LANDSCAPE ARCHITECT
215 AGRIS STREET SUITE 150
DURHAM, NC 27703
TEL: 919.419.1199
FAX: 919.419.1688
WWW.SURFACE678.COM
LICENSE # C-096

CHEATHAM & ASSOCIATES, PA

FIRE PROTECTION ENGINEER
3412 ENTERPRISE DRIVE
WILMINGTON, NC 28405
TEL: 910.452.4110
WWW.CHEATHAMPA.COM
LICENSE # C-1073

PALACIO COLLABORATIVE

COST ESTIMATOR
4815 ENTERPRISE BOULEVARD SUITE 400
DURHAM, NC 27709
TEL: 919.453.9100
WWW.PALACIOCOLLABORATIVE.COM

NOTE: IF THIS DRAWING IS NOT 30" X 42", IT IS A
REDUCED PRINT. REFER TO GRAPHIC SCALE.

NOT FOR
CONSTRUCTION

SEAL
23551
ENGINEER
DAVID M. HARR

NOT FOR
CONSTRUCTION

NO.	DATE	DESCRIPTION
1	9-8-25	BID SET

SECOND FLOOR PLAN -
DOMESTIC WATER

PW2.12

PHASING REQUIREMENTS


REFER TO ARCHITECTURAL DRAWING SET FOR CONSTRUCTION PHASING
REQUIREMENTS. COORDINATE WORK CLOSELY WITH GENERAL CONTRACTOR
AND ALL OTHER TRADES.

FLOOR PLAN LEGEND

- EXISTING BUILDING
- RENOVATED AREA
- UPFIT BY OTHERS
- 1-HR RATED WALL
- 2-HR RATED WALL
- 3-HR RATED WALL

FLOOR PLAN SHEET NOTES


- PLUMBING CONTRACTOR TO COORDINATE WITH OTHER TRADES PRIOR TO BEGINNING WORK.
- REFER TO ARCHITECTURAL DRAWINGS FOR RATED ASSEMBLY UL NUMBERS (WALLS, FLOOR / CEILING, ETC.)
- DRAWINGS: DRAWINGS ARE DIAGRAMMATIC AND MAY NOT COMPLETELY DESCRIBE EVERY DETAIL OF THE INSTALLATION. HOWEVER, CONTRACTOR IS RESPONSIBLE FOR FURNISHING COMPLETE SYSTEMS INCLUDING ALL REQUIRED EQUIPMENT AND ACCESSORIES TO OBTAIN FULLY FUNCTIONING PLUMBING SYSTEMS.
- EQUIPMENT LOCATIONS: DETERMINE EXACT EQUIPMENT AND MATERIALS LOCATIONS TO PROVIDE BEST ARRANGEMENT AND TO FACILITATE PROPER MAINTENANCE AND SERVICING OF EQUIPMENT.
- LISTING AND LABELING: ALL EQUIPMENT SHALL BE LABELED OR LISTED BY UL OR OTHER APPROVED TESTING AGENCY WHERE REQUIRED.

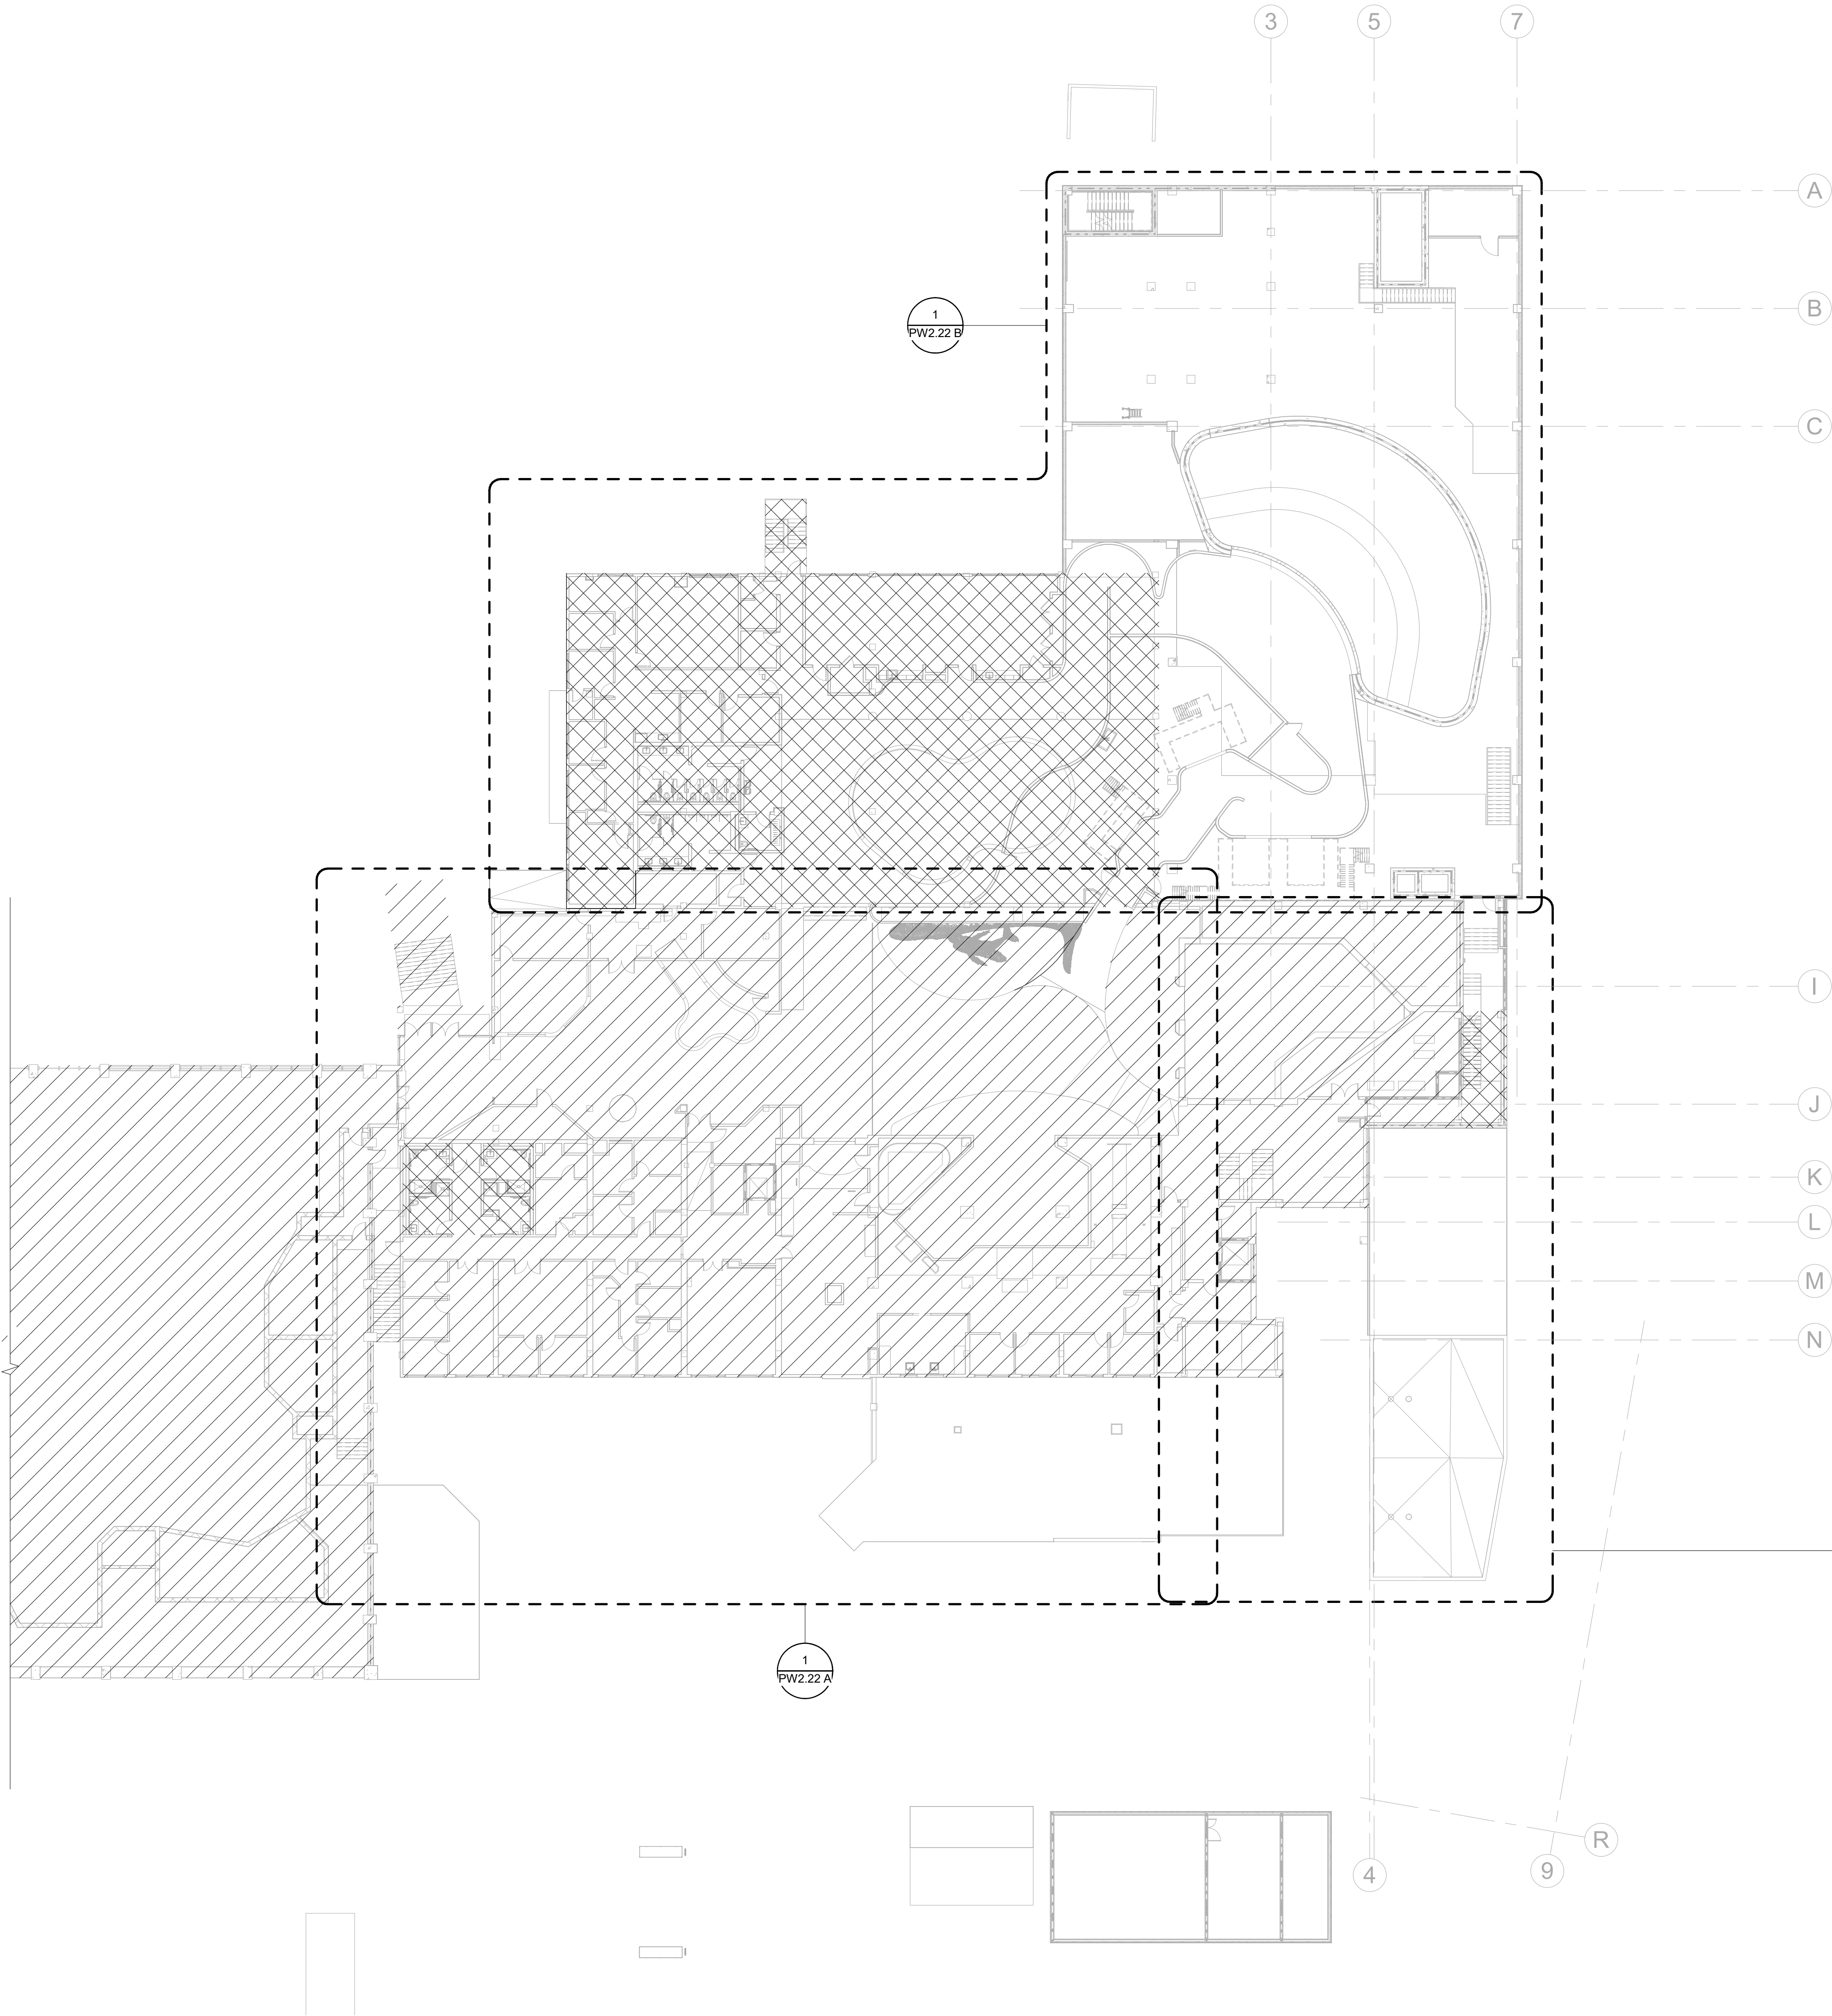

20' 10' 20'
SCALE: 1" = 20'-0"

CBHF
Engineers, PLLC

 2246 Yaupon Drive
Wilmington, NC 28401
Phone: 910.791.4000
Fax: 910.791.5566
www.cbhfenr.com
© Copyright 2025 CBHF Engineers, PLLC. NCIP P-0356



OVERALL 2ND FLOOR -DOMESTIC WATER PLAN

SCALE: 1" = 20'-0"

SZOSTAK DESIGN

FORT FISHER
AQUARIUM
RENOVATION
& EXPANSION:
PHASE 1

SCO #17-18042-02A
CODE: 42014-4G02
ITEM: 41414-4Y4A

900 LOGGERHEAD RD,
KURE BEACH, NC 28449

NORTH CAROLINA DEPT. OF
NATURAL & CULTURAL RESOURCES

SZOSTAK DESIGN, INC.

ARCHITECT
310 1/2 WEST FRANKLIN STREET
CHAPEL HILL, NORTH CAROLINA 27514
TEL: 919.929.5244
FAX: 919.960.7967
WWW.SZOSTAKDESIGN.COM
LICENSE # 31079

TJP ENGINEERING, INC.

LIFE SUPPORT SYSTEMS ENGINEER
5680 VENTURE LAKE SUITE 205N
BEND, OR 97707
TEL: 503.433.0300
WWW.TJPEENGINEERING.COM
LICENSE # C-35065

ROTO GROUP, LLC.

EXHIBIT DESIGNER
7001 DISCOVERY BOULEVARD
DURHAM, NC 27707
TEL: 817.760.6695
WWW.ROTO.COM

BENNETT & PLESS

STRUCTURAL ENGINEER
5430 WADE PARK BOULEVARD SUITE 400
RALEIGH, NC 27607
TEL: 919.822.5587
WWW.BENNETT&PLESS.COM
LICENSE # F-1105

CBHF ENGINEERS, PLLC

MFP ENGINEER
2246 YAUPOH DRIVE
WILMINGTON, NC 28401
TEL: 910.791.4000
FAX: 910.791.5266
WWW.CBHFENGINEERS.COM
LICENSE # P-05061

LIGHTSWITCH

LIGHTING DESIGNER
10065 INDIANA COURT
RANCHO CUCAMONGA, CA 91730
TEL: 909.360.7000
WWW.LIGHTSWITCH.NET

TUNSTALL CONSULTING ENGINEERS PLLC

CIVIL ENGINEER
2405 IRON GATE DRIVE SUITE 102
WILMINGTON, NC 28412
TEL: 910.343.9433
FAX: 910.343.9404
WWW.TUNSTALLENGINEERS.COM
LICENSE # F-3132

SURFACE 678, PA

LANDSCAPE ARCHITECT
215 AGRIUS STREET SUITE 150
DURHAM, NC 27705
TEL: 919.419.1199
FAX: 919.419.1689
WWW.SURFACE678.COM
LICENSE # C-096

CHEATHAM & ASSOCIATES, PA

FIRE PROTECTION ENGINEER
3412 ENTERPRISE DRIVE
WILMINGTON, NC 28405
TEL: 910.452.6110
WWW.CHEATHAMPA.COM
LICENSE # C-1073

PALACIO COLLABORATIVE

COST ESTIMATOR
4817 ENTERPRISE BOULEVARD SUITE 400
DURHAM, NC 27705
TEL: 919.453.9100
WWW.PALACIOCOLLABORATIVE.COM

NOTE: IF THIS DRAWING IS NOT 36" X 42", IT IS A
REDUCED PRINT. REFER TO GRAPHIC SCALE.

NOT FOR
CONSTRUCTION



NOT FOR
CONSTRUCTION

NO.	DATE	DESCRIPTION
1	9-8-25	BID SET

FIRST FLOOR PLAN - CAPE
FEAR SHOALS - DOMESTIC
WATER


PW2.21 A

FLOOR PLAN LEGEND


- EXISTING BUILDING
- RENOVATED AREA
- UPFIT BY OTHERS
- 1-HR RATED WALL
- 2-HR RATED WALL
- 3-HR RATED WALL

FLOOR PLAN SHEET NOTES

- PLUMBING CONTRACTOR TO COORDINATE WITH OTHER TRADES PRIOR TO BEGINNING WORK.
- REFER TO ARCHITECTURAL DRAWINGS FOR RATED ASSEMBLY UL NUMBERS (WALLS, FLOOR / CEILING, ETC.)
- DRAWINGS: DRAWINGS ARE DIAGRAMMATIC AND MAY NOT COMPLETELY DESCRIBE EVERY DETAIL OF THE INSTALLATION. HOWEVER, CONTRACTOR IS RESPONSIBLE FOR FURNISHING COMPLETE SYSTEMS INCLUDING ALL REQUIRED EQUIPMENT AND ACCESSORIES TO OBTAIN FULLY FUNCTIONING PLUMBING SYSTEMS.
- EQUIPMENT LOCATIONS: DETERMINE EXACT EQUIPMENT AND MATERIALS LOCATIONS TO PROVIDE BEST ARRANGEMENT AND TO FACILITATE PROPER MAINTENANCE AND SERVICING OF EQUIPMENT.
- LISTING AND LABELING: ALL EQUIPMENT SHALL BE LABELED OR LISTED BY UL OR OTHER APPROVED TESTING AGENCY WHERE REQUIRED.

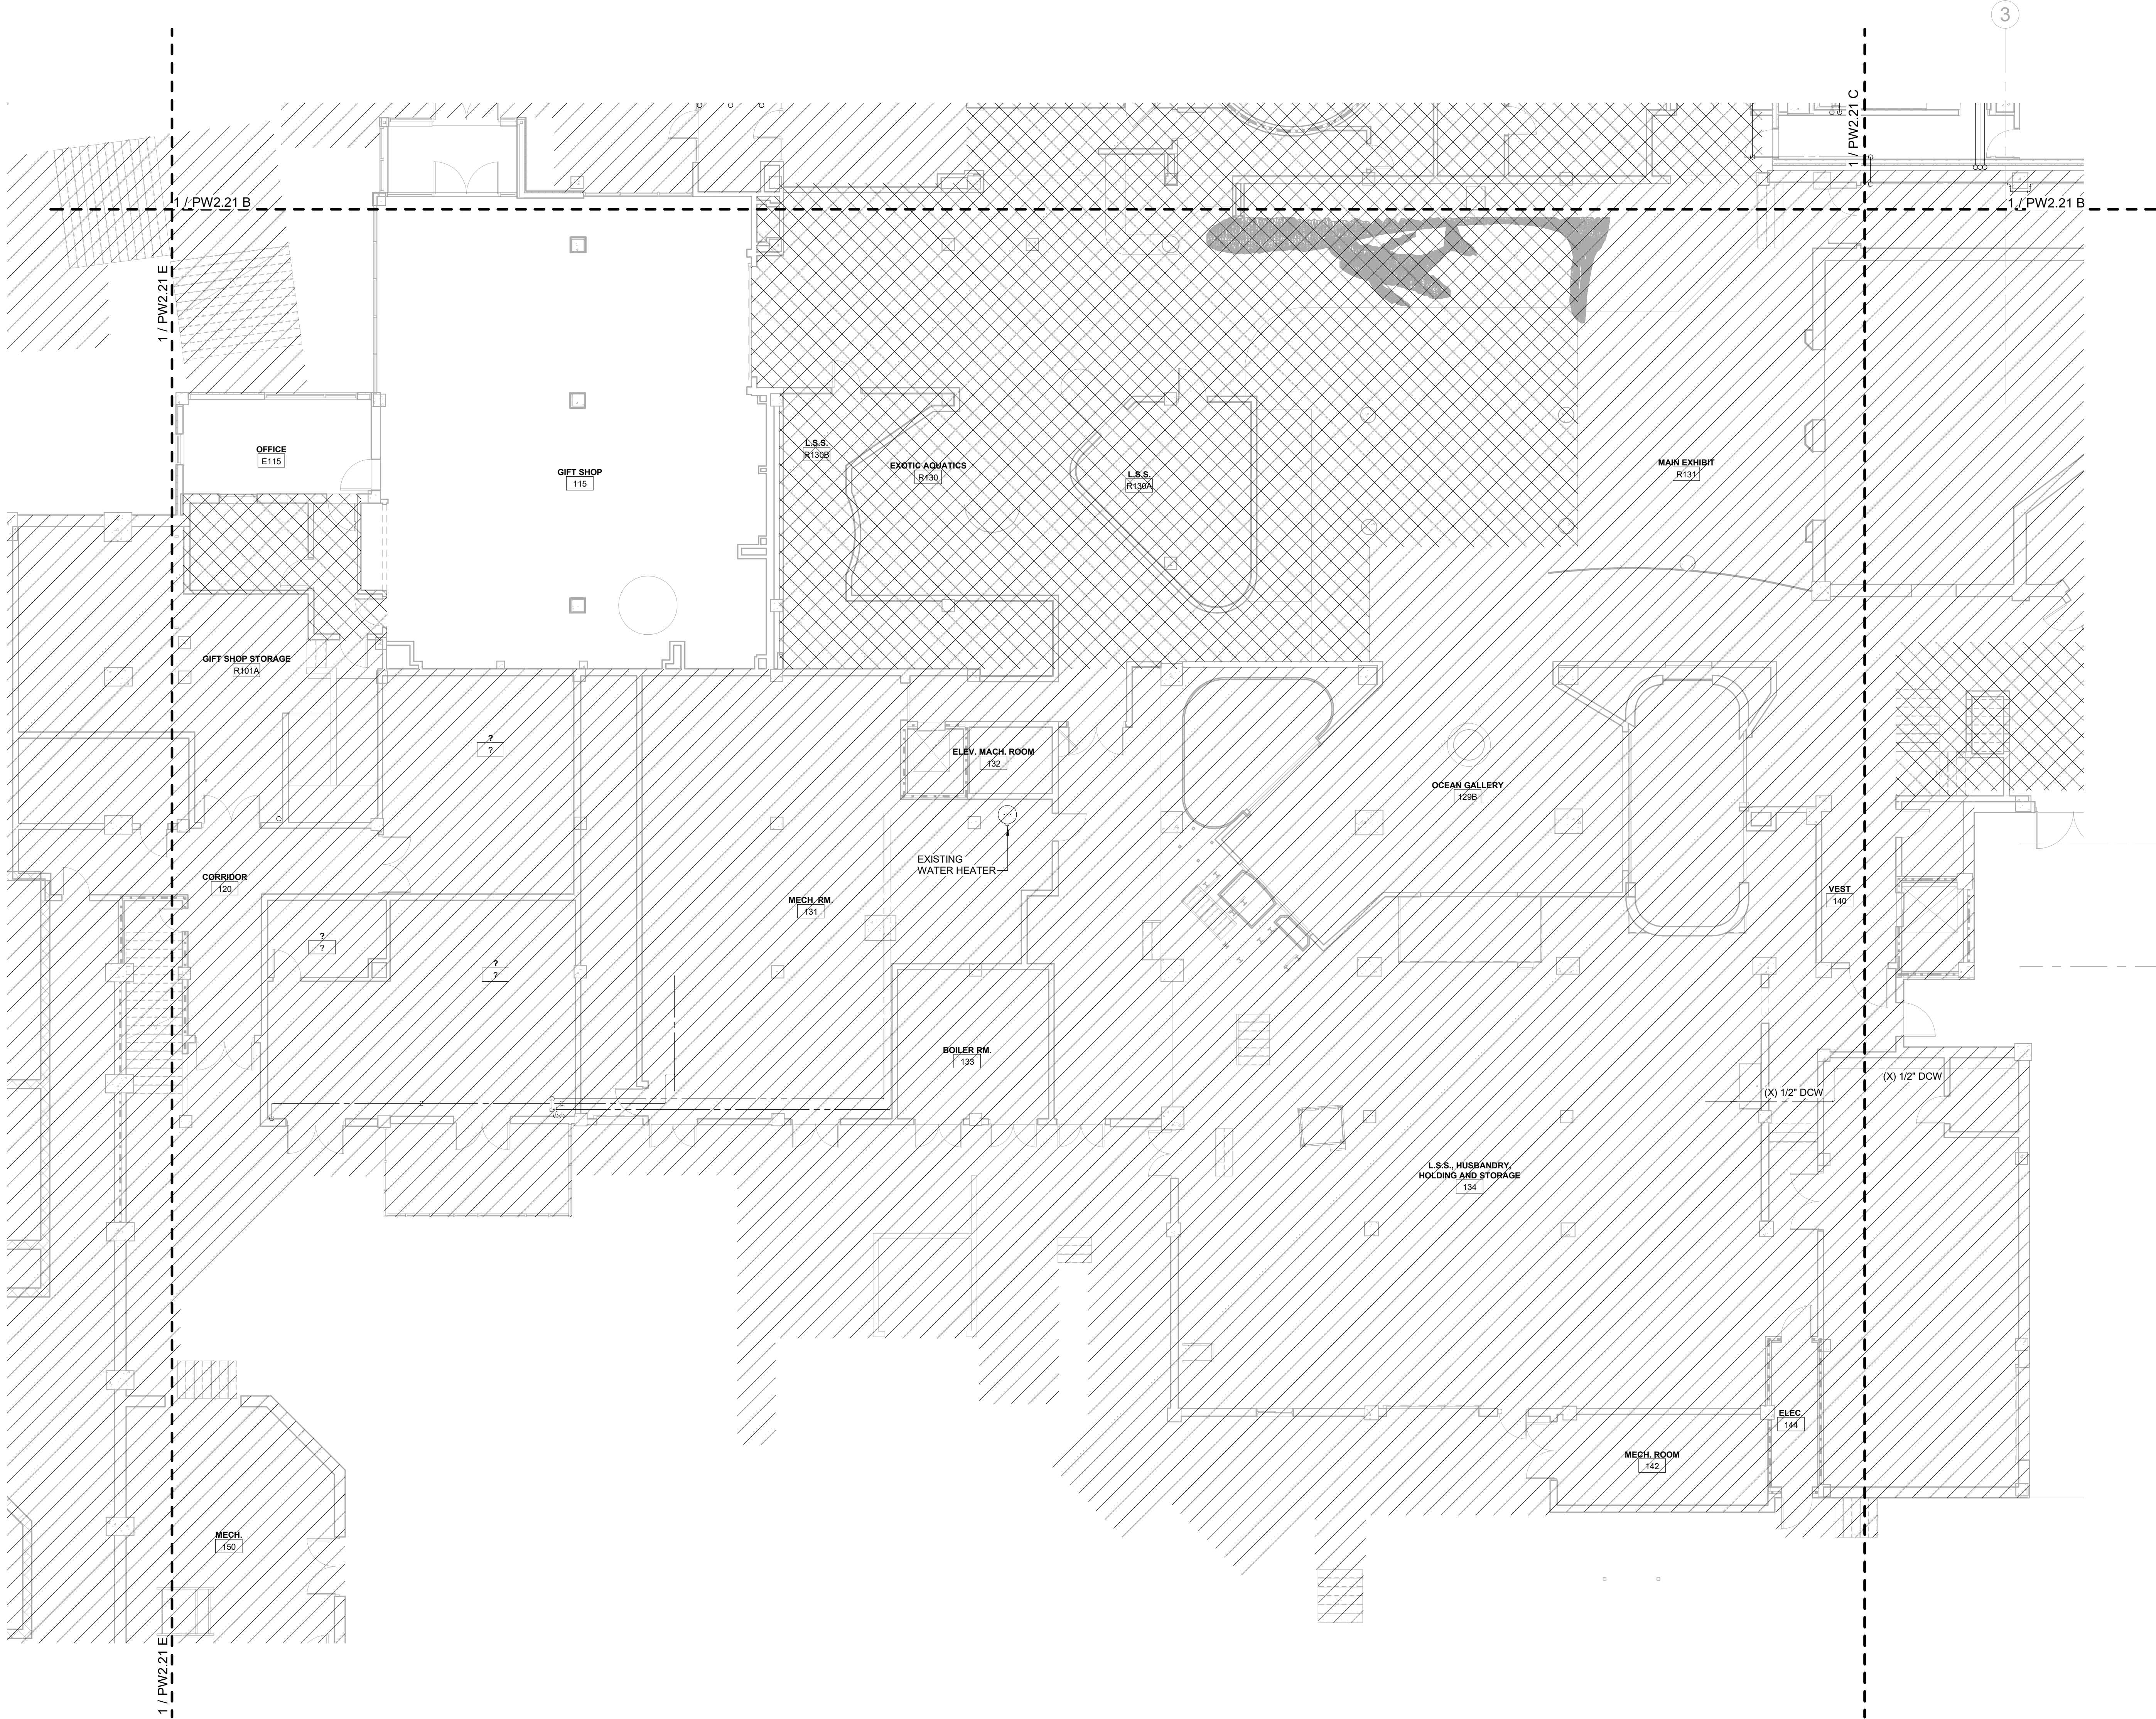

KEY PLAN

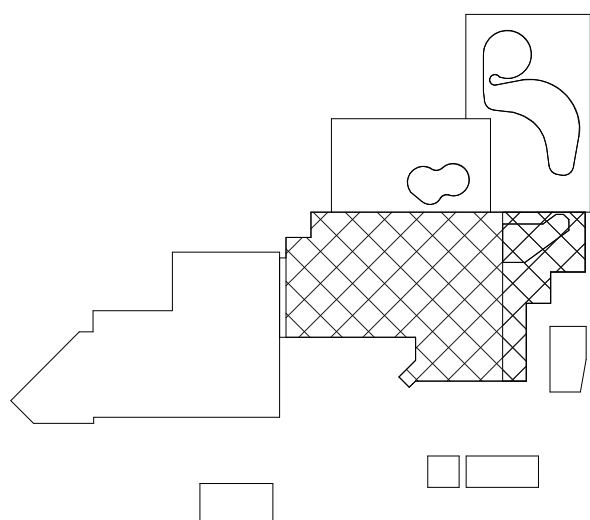



CBHF
Engineers, PLLC

2246 Yaupon Drive
Wilmington, NC 28401
Phone: 910.791.4000
Fax: 910.791.5266
www.cbhfindesign.com
© Copyright 2025 CBHF Engineers, PLLC. NCCE P-0506

8' 4' 0' 8'
SCALE: 1/8" = 1'-0"

1ST FLOOR - CAPE FEAR SHOALS - DOMESTIC WATER
SCALE: 1/8" = 1'-0"

KEYNOTES THIS SHEET	
1	1/2" DCW TO ICE MACHINE. CONTRACTOR MUST INSTALL INLINE FILTER AND BACKFLOW PREVENTION DEVICE MEETING ASSE 1024.
2	2-1/2" DCW UP. SEE DRAWING PW2.22B FOR CONTINUATION.

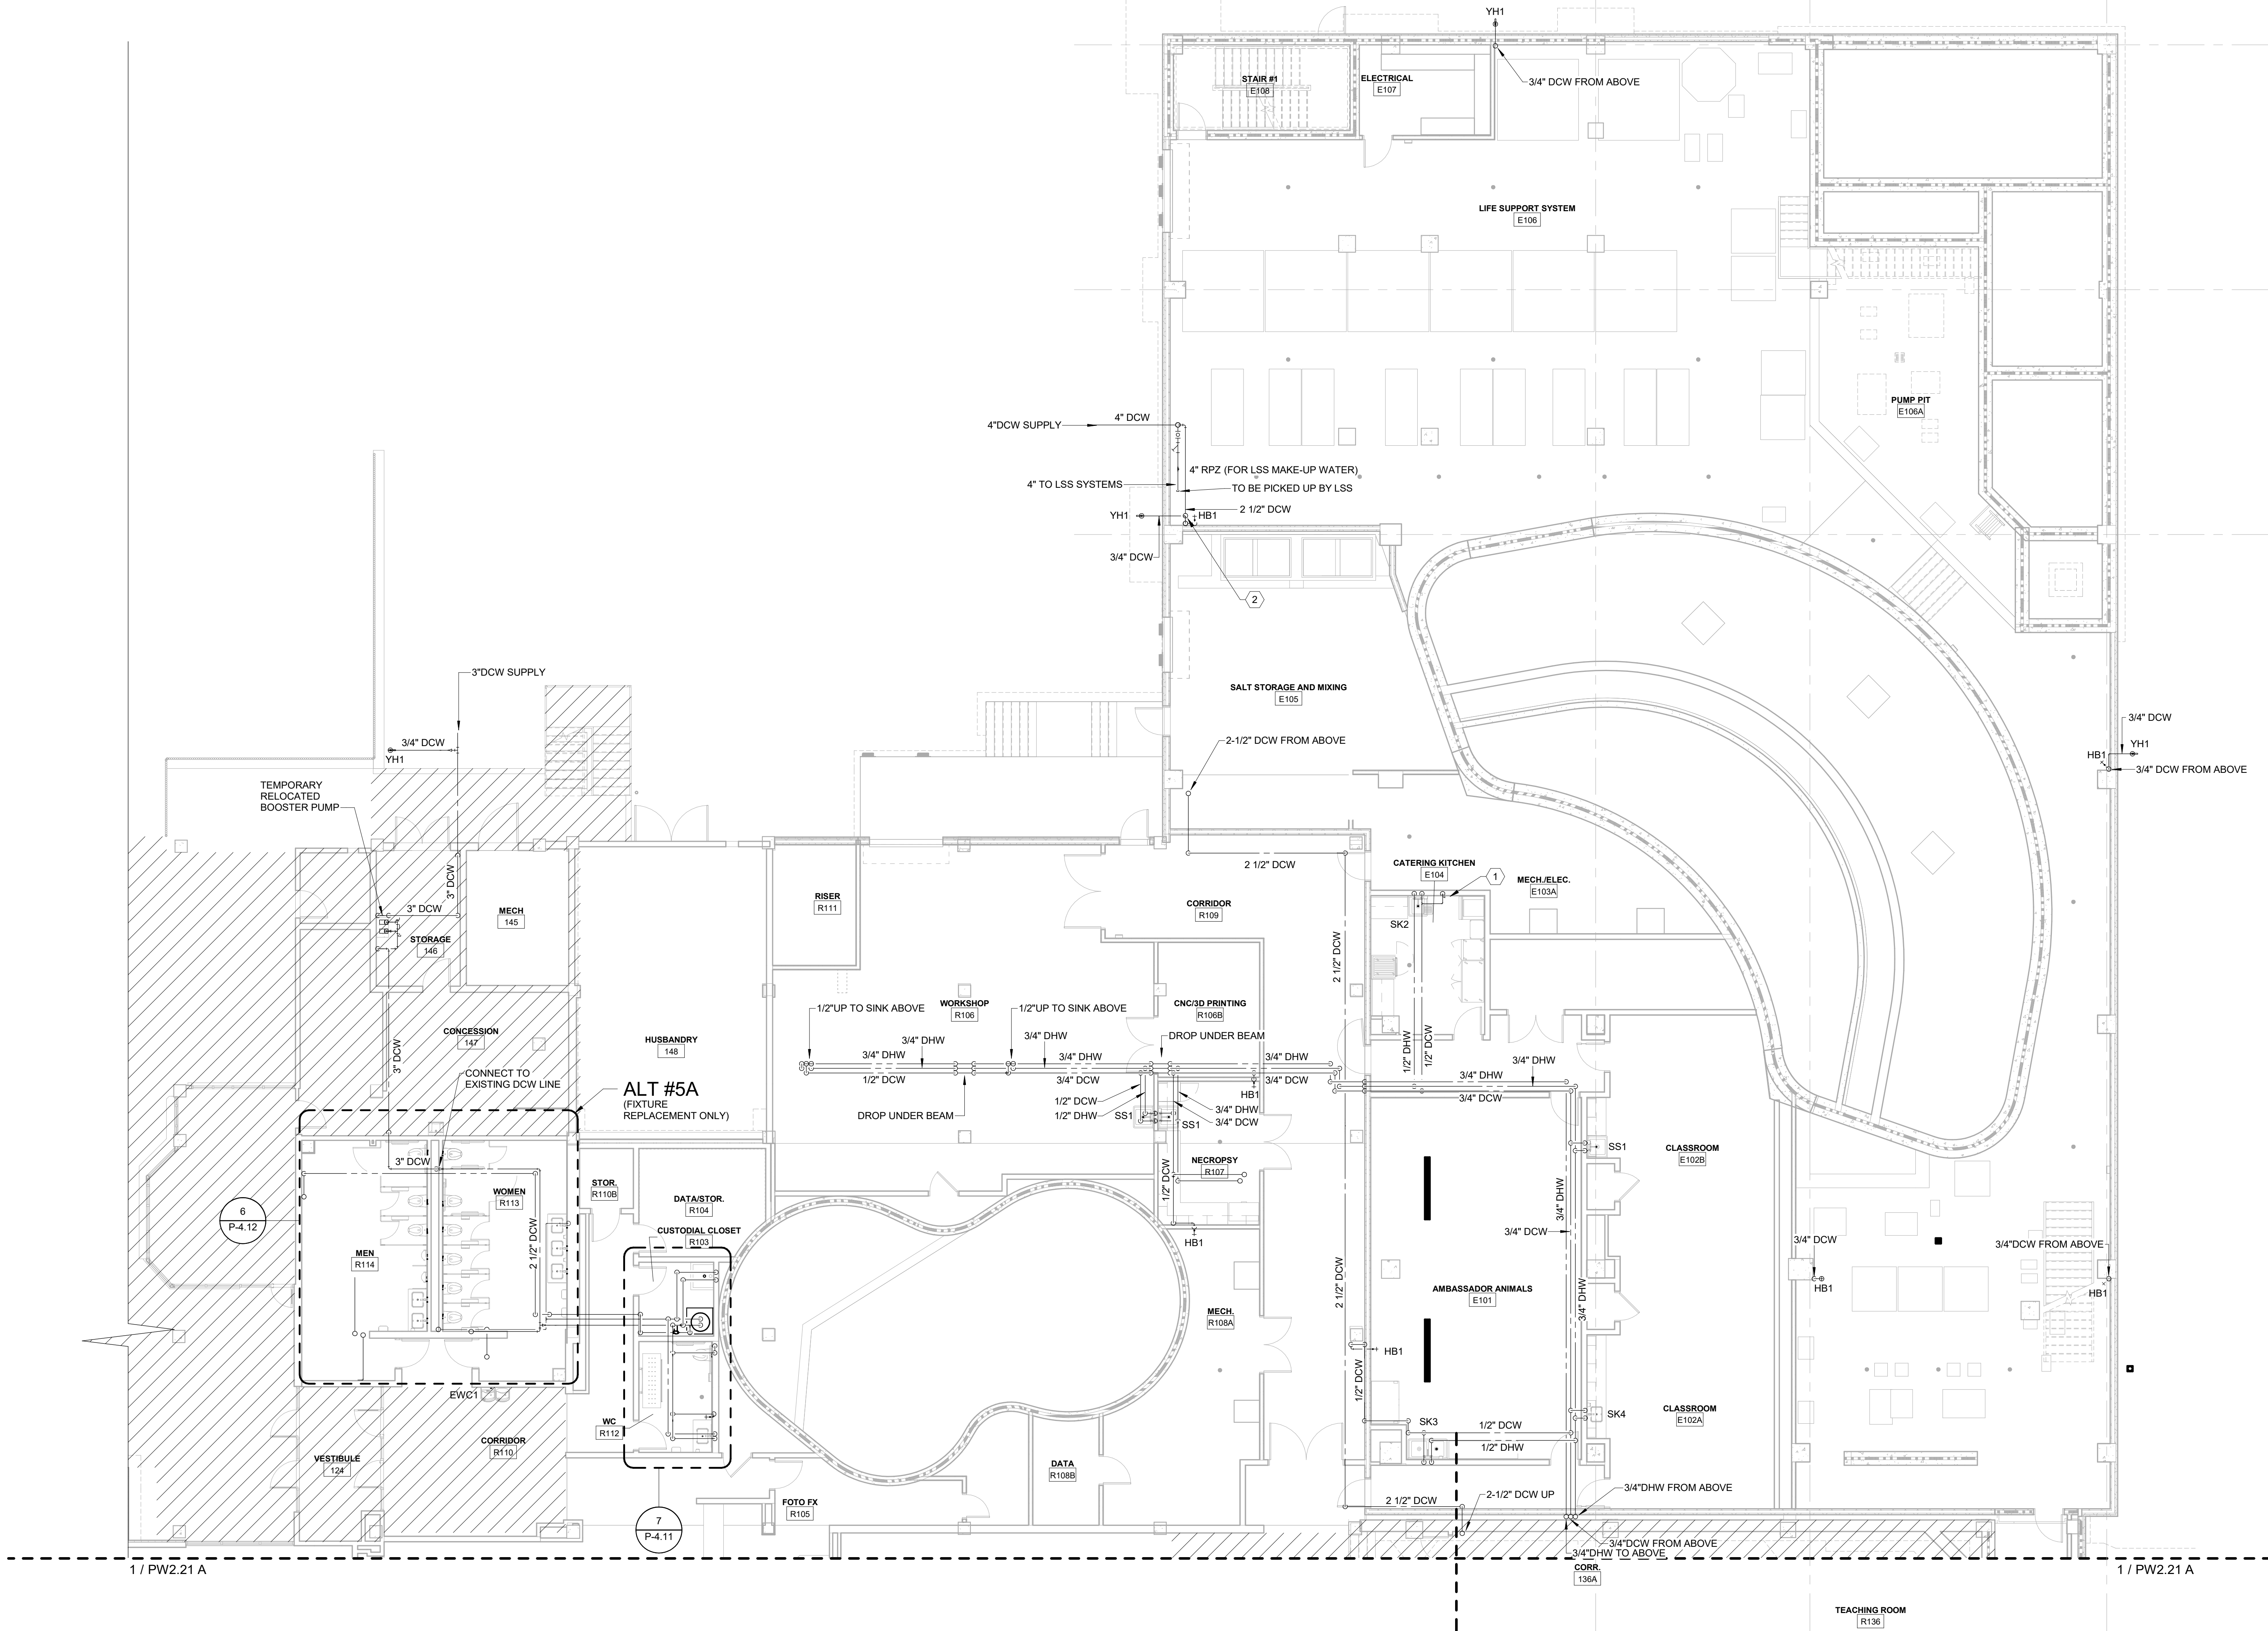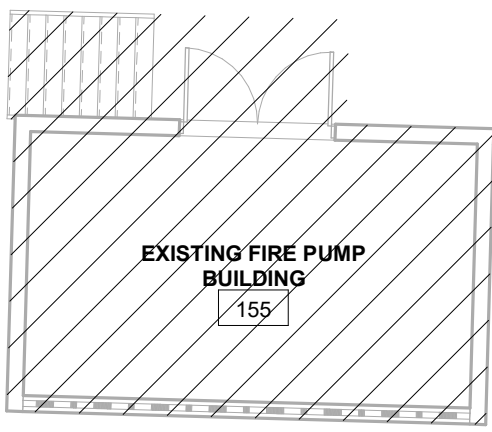

FLOOR PLAN LEGEND	
	EXISTING BUILDING
	RENOVATED AREA
	UPFIT BY OTHERS
	1-HR RATED WALL
	2-HR RATED WALL
	3-HR RATED WALL

FLOOR PLAN SHEET NOTES	
1	PLUMBING CONTRACTOR TO COORDINATE WITH OTHER TRADES PRIOR TO BEGINNING WORK.
2	REFER TO ARCHITECTURAL DRAWINGS FOR RATED ASSEMBLY UL NUMBERS (WALLS, FLOOR / CEILING, ETC.).
3	DRAWINGS: DRAWINGS ARE DIAGRAMMATIC AND MAY NOT COMPLETELY DESCRIBE EVERY DETAIL OF THE INSTALLATION. HOWEVER, CONTRACTOR IS RESPONSIBLE FOR FURNISHING COMPLETE SYSTEMS INCLUDING ALL REQUIRED EQUIPMENT AND ACCESSORIES TO OBTAIN FULLY FUNCTIONING PLUMBING SYSTEMS.
4	EQUIPMENT LOCATIONS: DETERMINE EXACT EQUIPMENT AND MATERIALS LOCATIONS TO PROVIDE BEST ARRANGEMENT AND TO FACILITATE PROPER MAINTENANCE AND SERVICING OF EQUIPMENT.
5	LISTING AND LABELING: ALL EQUIPMENT SHALL BE LABELED OR LISTED BY UL OR OTHER APPROVED TESTING AGENCY WHERE REQUIRED.

SZOSTAK DESIGN

FORT FISHER
AQUARIUM
RENOVATION
& EXPANSION:
PHASE 1

SCO #17-18042-02A
CODE: 42014-4G02
ITEM: 41414-4Y4A

900 LOGGERHEAD RD,
KURE BEACH, NC 28449

NORTH CAROLINA DEPT. OF
NATURAL & CULTURAL RESOURCES

SZOSTAK DESIGN, INC.

ARCHITECT
310 1/2 WEST FRANKLIN STREET
CHAPEL HILL, NORTH CAROLINA 27514
TEL: 919.929.5244
FAX: 919.960.7967
WWW.SZOSTAKDESIGN.COM
LICENSE # 31079

TJP ENGINEERING, INC.

LIFE SUPPORT SYSTEMS ENGINEER
5680 VENTURE LANE SUITE 205N
BEID, OR 97007
TEL: 414.433.0000
WWW.TJPEENGINEERING.COM
LICENSE # C-3505

ROTO GROUP, LLC.

EXHIBIT DESIGNER
7001 DISCOVERY BOULEVARD
DURHAM, NC 27707
TEL: 817.760.6895
WWW.ROTO.COM

BENNETT & PLESS

STRUCTURAL ENGINEER
5430 WADE PARK BOULEVARD SUITE 400
RALEIGH, NC 27607
TEL: 919.822.5587
WWW.BENNETT-PLESS.COM
LICENSE # F-1105

CBHF ENGINEERS, PLLC

MFP ENGINEER
3244 YAUPOIN DRIVE
WILMINGTON, NC 28401
TEL: 910.791.4000
FAX: 910.791.5544
WWW.CBHFENGINEERS.COM
LICENSE # P-6554

LIGHTSWITCH

LIGHTING DESIGNER
10665 INDIANA COURT
RANCHO CUCAMONGA, CA 91730
TEL: 909.360.7000
WWW.LIGHTSWITCH.NET

TUNSTALL CONSULTING ENGINEERS PLLC

CIVIL ENGINEER
2402 BROWN GATE DRIVE SUITE 102
WILMINGTON, NC 28412
TEL: 910.343.8433
FAX: 910.343.8404
WWW.TUNSTALL-ENGINEERS.COM
LICENSE # F-3132

SURFACE 678, PA

LANDSCAPE ARCHITECT
215 AGRIS STREET SUITE 150
DURHAM, NC 27701
TEL: 919.419.1199
FAX: 919.419.1689
WWW.SURFACE678.COM
LICENSE # C-1073

CHEATHAM & ASSOCIATES, PA

FIRE PROTECTION ENGINEER
3412 ENTERPRISE DRIVE
WILMINGTON, NC 28405
TEL: 910.452.4010
WWW.CHEATHAMPA.COM
LICENSE # C-1073

PALACIO COLLABORATIVE

COST ESTIMATOR
4811 ENTERPRISE BOULEVARD SUITE 400
DURHAM, NC 27703
TEL: 919.453.9700
WWW.PALACIOCOLLABORATIVE.COM

NOTE: IF THIS DRAWING IS NOT 30" X 42", IT IS A
REDUCED PRINT. REFER TO GRAPHIC SCALE.

NOT FOR
CONSTRUCTION

SEAL
23551
ENGINEER
DAVID M. HARRIS

NOT FOR
CONSTRUCTION

NO.	DATE	DESCRIPTION
1	9-8-25	BID SET

FIRST FLOOR PLAN -
TOUCH AND SHARK TANK -
DOMESTIC WATER

PW2.21 B

CBHF
Engineers, PLLC

2246 Yaupon Drive
Wilmington, NC 28401
Phone: 910.791.4000
Fax: 910.791.5266
www.cbhfindesign.com
© Copyright 2025 CBHF Engineers, PLLC. NCIP P-0356

8' 4' 0' 8'
SCALE: 1/8" = 1'-0"

1ST FLOOR - TOUCH AND SHARK TANK - DOMESTIC WATER
SCALE: 1/8" = 1'-0"

- 1

SZOSTAK DESIGN

FORT FISHER
AQUARIUM
RENOVATION
& EXPANSION:
PHASE 1

SCO #17-18042-02A
CODE: 42014-4G02
ITEM: 41414-4Y4A

900 LOGGERHEAD RD,
KURE BEACH, NC 28449

NORTH CAROLINA DEPT. OF
NATURAL & CULTURAL RESOURCES

SZOSTAK DESIGN, INC.

ARCHITECT
310 1/2 WEST FRANKLIN STREET
CHAPEL HILL, NORTH CAROLINA 27514
TEL: 919.929.5244
FAX: 919.960.7967
WWW.SZOSTAKDESIGN.COM
LICENSE # 31079

TJP ENGINEERING, INC.

LIFE SUPPORT SYSTEMS ENGINEER
5680 VENTURE LANE SUITE 205N
BEND, OR 97707
TEL: 503.433.0300
WWW.TJPEENGINEERING.COM
LICENSE # C-3595

ROTO GROUP, LLC.

EXHIBIT DESIGNER
7001 DISCOVERY BOULEVARD
DUBLIN, OHIO 43017
TEL: 617.760.6695
WWW.ROTO.COM

BENNETT & PLESS

STRUCTURAL ENGINEER
5430 WADE PARK BOULEVARD SUITE 400
RALEIGH, NC 27607
TEL: 919.832.5587
WWW.BENNETT-PLESS.COM
LICENSE # F-1105

CBHF ENGINEERS, PLLC

MFP ENGINEER
2246 YAUPOH DRIVE
WILMINGTON, NC 28401
TEL: 910.791.4000
FAX: 910.791.2546
WWW.CBHFENGINEERS.COM
LICENSE # P-6554

LIGHTSWITCH

LIGHTING DESIGNER
10365 INDIANA COURT
RANCHO CUCAMONGA, CA 91730
TEL: 909.360.0900
WWW.LIGHTSWITCH.NET

TUNSTALL CONSULTING ENGINEERS PLLC

CIVIL ENGINEER
2405 IRON GATE DRIVE SUITE 102
WILMINGTON, NC 28412
TEL: 910.343.9433
FAX: 910.343.9404
WWW.TUNSTALLENGINEERS.COM
LICENSE # P-3132

SURFACE 678, PA

LANDSCAPE ARCHITECT
215 A MORRIS STREET SUITE 150
DURHAM, NC 27701
TEL: 919.419.1199
FAX: 919.419.1689
WWW.SURFACE678.COM
LICENSE # C-098

CHEATHAM & ASSOCIATES, PA

FIRE PROTECTION ENGINEER
3412 ENTERPRISE DRIVE
WILMINGTON, NC 28405
TEL: 910.452.4510
WWW.CHEATHAMPA.COM
LICENSE # C-1073

PALACIO COLLABORATIVE

COST ESTIMATOR
4817 ENTERPRISE BOULEVARD SUITE 400
DURHAM, NC 27705
TEL: 919.403.9700
WWW.PALACIOCOLLABORATIVE.COM

NOTE: IF THIS DRAWING IS NOT 30" X 42", IT IS A
REDUCED PRINT. REFER TO GRAPHIC SCALE.

NOT FOR
CONSTRUCTION

SEAL
23551
ENGINEER
DAVID M. HARR

NOT FOR
CONSTRUCTION

NO.	DATE	DESCRIPTION
1	9-8-25	BID SET

FIRST FLOOR PLAN - MAIN
ENTRY & MECH BLDG -
DOMESTIC WATER


PW2.21 D

FLOOR PLAN LEGEND


- | | |
|--|-------------------|
| | EXISTING BUILDING |
| | RENOVATED AREA |
| | UPFIT BY OTHERS |
| | 1-HR RATED WALL |
| | 2-HR RATED WALL |
| | 3-HR RATED WALL |

FLOOR PLAN SHEET NOTES

1. PLUMBING CONTRACTOR TO COORDINATE WITH OTHER TRADES PRIOR TO BEGINNING WORK.
2. REFER TO ARCHITECTURAL DRAWINGS FOR RATED ASSEMBLY UL NUMBERS (WALLS, FLOOR / CEILING, ETC.).
3. DRAWINGS: DRAWINGS ARE DIAGRAMMATIC AND MAY NOT COMPLETELY DESCRIBE EVERY DETAIL OF THE INSTALLATION. HOWEVER, CONTRACTOR IS RESPONSIBLE FOR FURNISHING COMPLETE SYSTEMS INCLUDING ALL REQUIRED EQUIPMENT AND ACCESSORIES TO OBTAIN FULLY FUNCTIONING PLUMBING SYSTEMS.
4. EQUIPMENT LOCATIONS: DETERMINE EXACT EQUIPMENT AND MATERIALS LOCATIONS TO PROVIDE BEST ARRANGEMENT AND TO FACILITATE PROPER MAINTENANCE AND SERVICING OF EQUIPMENT.
5. LISTING AND LABELING: ALL EQUIPMENT SHALL BE LABELED OR LISTED BY UL OR OTHER APPROVED TESTING AGENCY WHERE REQUIRED.

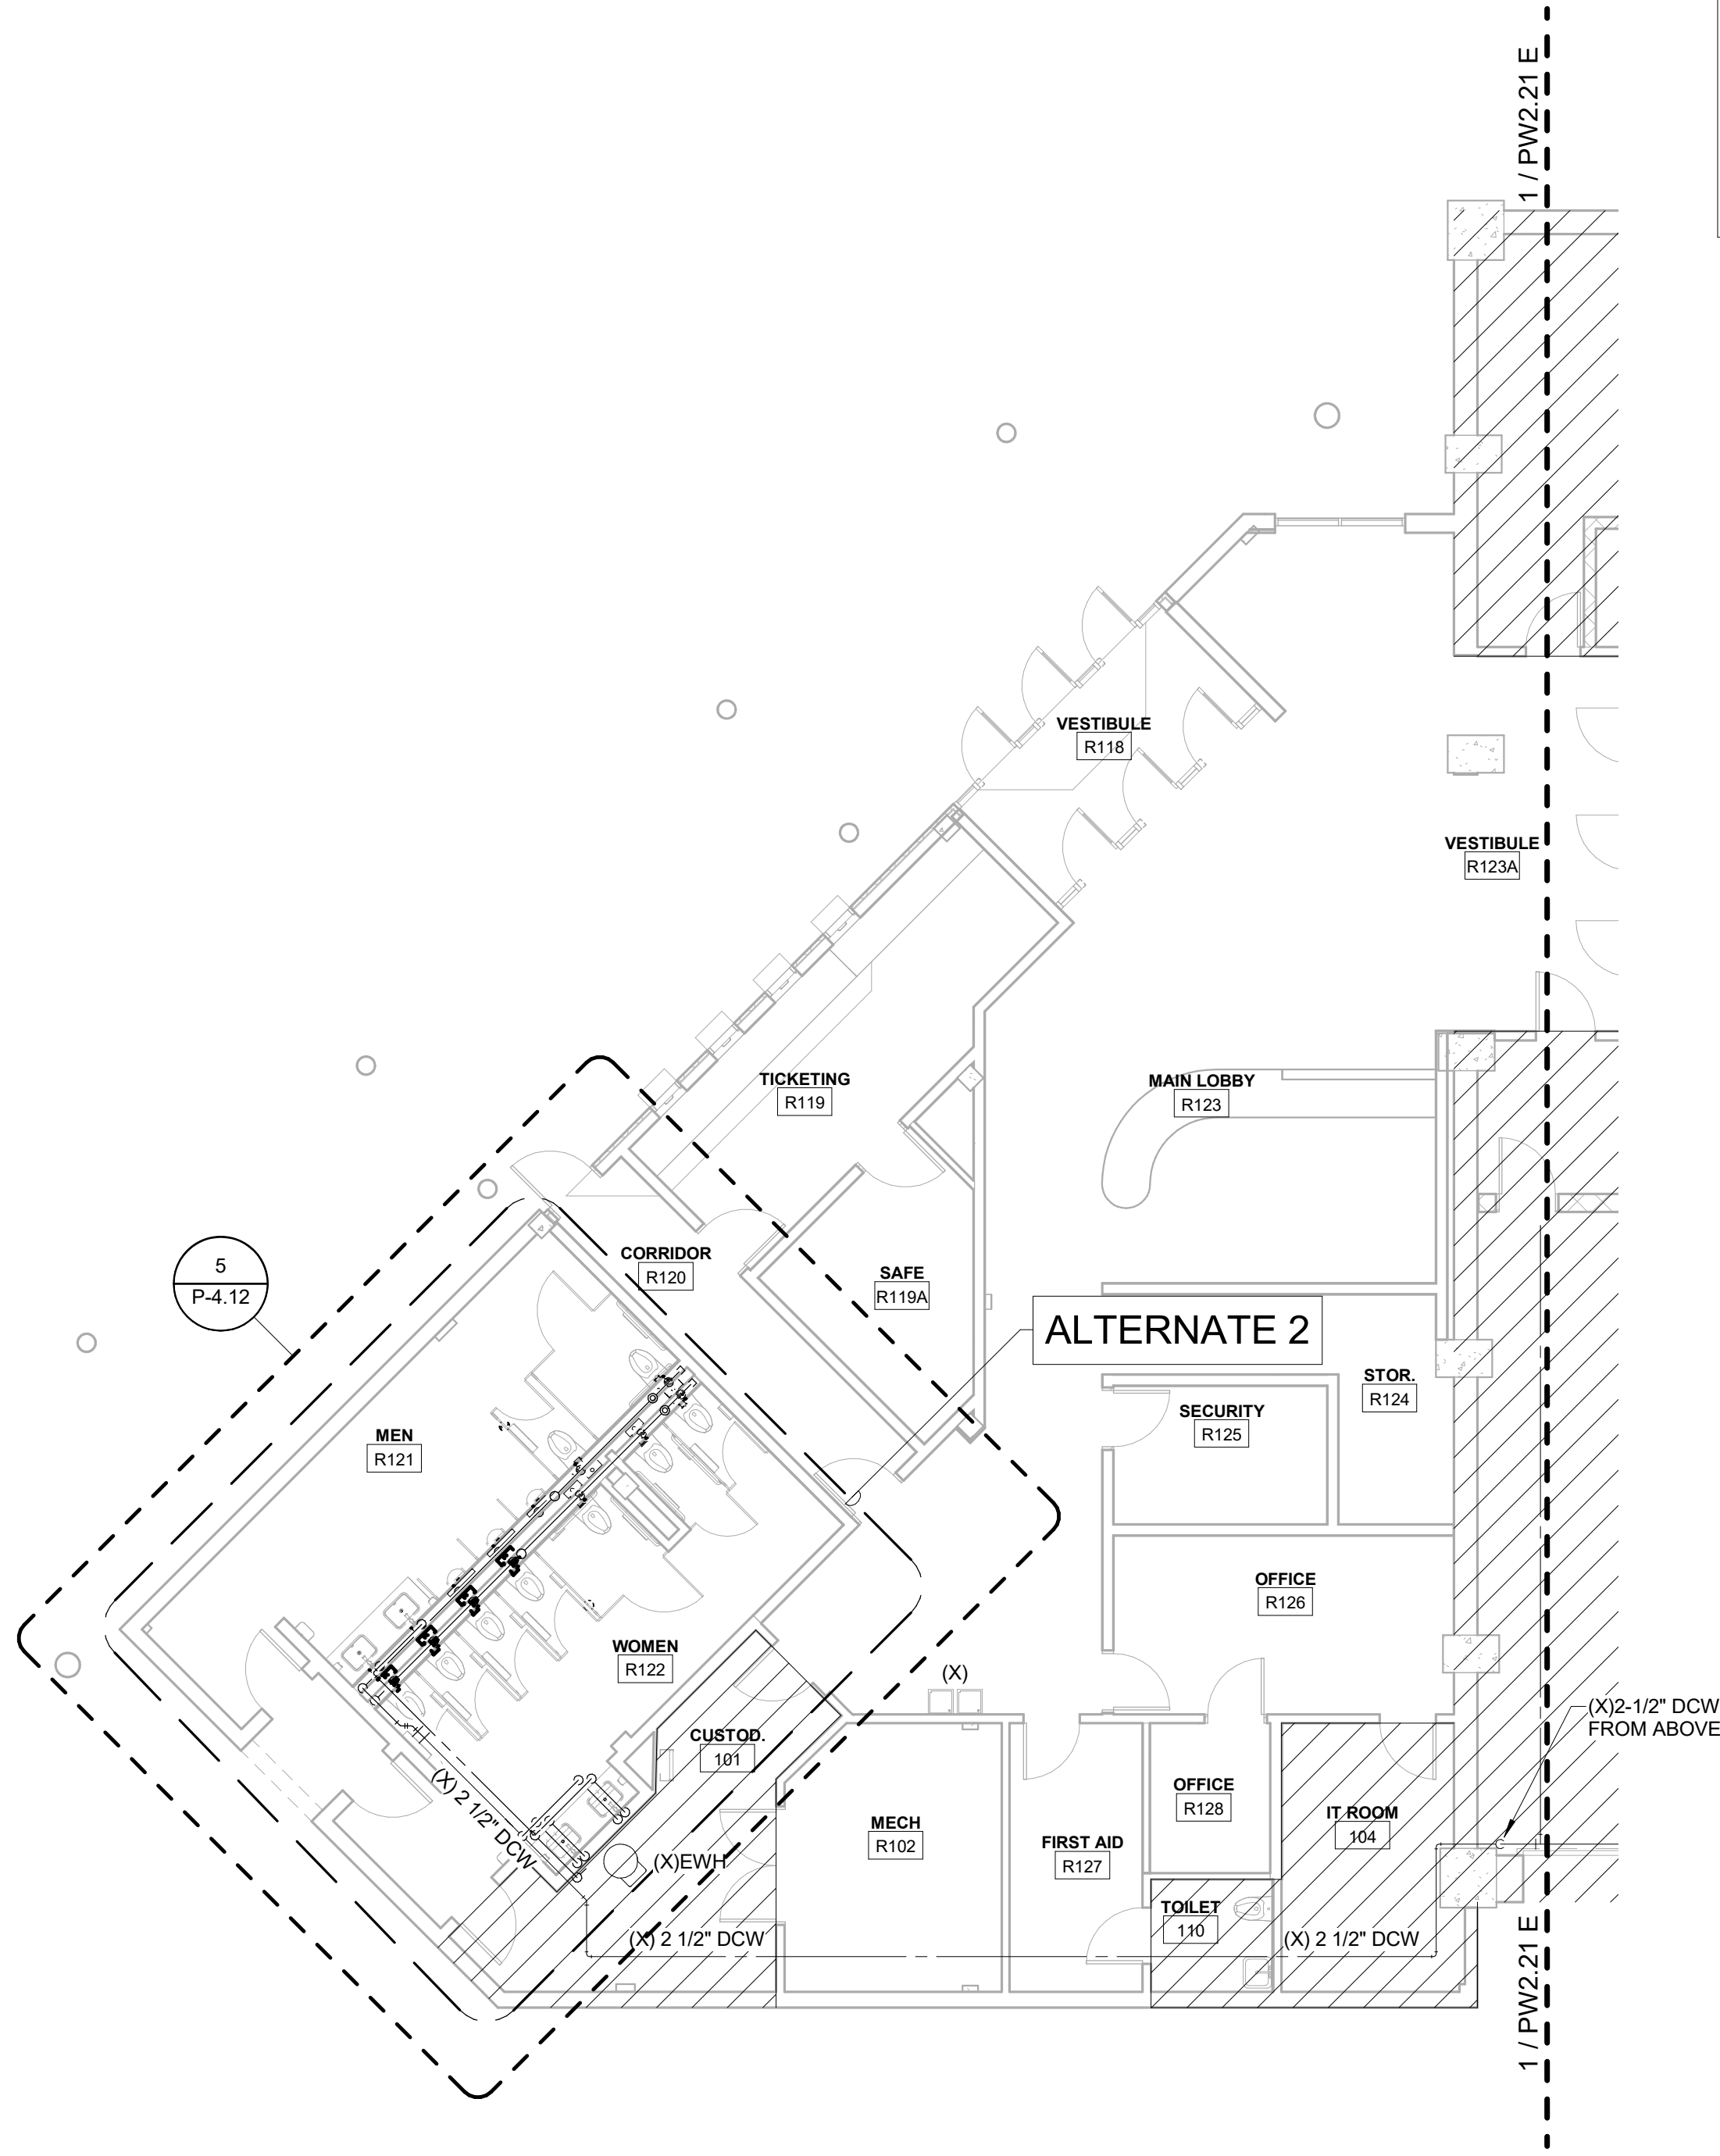

KEY PLAN

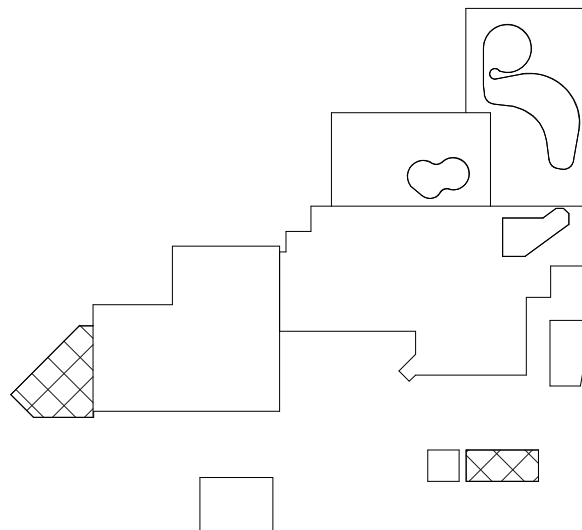

CBHF
Engineers, PLLC

2246 Yaupon Drive
Wilmington, NC 28401
Phone: 910.791.4000
Fax: 910.791.5266
www.cbhfenr.com
© Copyright 2025 CBHF Engineers, PLLC. NCIP # 0356

8' 4' 0' 8'
SCALE: 1/8" = 1'-0"

1ST FLOOR - MAIN ENTRY - DOMESTIC WATER
SCALE: 1/8" = 1'-0"

SZOSTAK DESIGN

FORT FISHER
AQUARIUM
RENOVATION
& EXPANSION:
PHASE 1

SCO #17-18042-02A
CODE: 42014-4G02
ITEM: 41414-4Y4A

900 LOGGERHEAD RD,
KURE BEACH, NC 28449

NORTH CAROLINA DEPT. OF
NATURAL & CULTURAL RESOURCES

SZOSTAK DESIGN, INC.

ARCHITECT
310 1/2 WEST FRANKLIN STREET
CHAPEL HILL, NORTH CAROLINA 27514
TEL: 919.929.5244
FAX: 919.960.7967
WWW.SZOSTAKDESIGN.COM
LICENSE # 31679

TJP ENGINEERING, INC.

LIFE SUPPORT SYSTEMS ENGINEER
5680 VENTURE LANE SUITE 205N
BEND, OR 97007
TEL: 503.433.0300
WWW.TJPEENGINEERING.COM
LICENSE # C-3505

ROTO GROUP, LLC.

EXHIBIT DESIGNER
7001 DISCOVERY BOULEVARD
DURHAM, NC 27707
TEL: 919.282.5587
WWW.ROTO.COM

BENNETT & PLESS

STRUCTURAL ENGINEER
5430 WADE PARK BOULEVARD SUITE 400
RALEIGH, NC 27607
TEL: 919.832.5587
WWW.BENNETT-PLESS.COM
LICENSE # F-1105

CBHF ENGINEERS, PLLC

MFP ENGINEER
2246 YAUPOIN DRIVE
WILMINGTON, NC 28401
TEL: 910.791.4000
FAX: 910.791.2546
WWW.CBHFENGINEERS.COM
LICENSE # P-6554

LIGHTSWITCH

LIGHTING DESIGNER
10365 INDIANA COURT
RANCHO CUCAMONGA, CA 91730
TEL: 909.360.7000
WWW.LIGHTSWITCH.NET

TUNSTALL CONSULTING ENGINEERS PLLC

CIVIL ENGINEER
2402 IRON GATE DRIVE SUITE 102
WILMINGTON, NC 28412
TEL: 910.343.9433
FAX: 910.343.9404
WWW.TUNSTALLENGINEERS.COM
LICENSE # P-3132

SURFACE 678, PA

LANDSCAPE ARCHITECT
215 AGRIS STREET SUITE 150
DURHAM, NC 27703
TEL: 919.419.1199
FAX: 919.419.1689
WWW.SURFACE678.COM
LICENSE # C-298

CHEATHAM & ASSOCIATES, PA

FIRE PROTECTION ENGINEER
3412 ENTERPRISE DRIVE
WILMINGTON, NC 28405
TEL: 910.452.4100
WWW.CHEATHAMPA.COM
LICENSE # C-1073

PALACIO COLLABORATIVE

COST ESTIMATOR
4817 ENTERPRISE BOULEVARD SUITE 400
DURHAM, NC 27703
TEL: 919.453.9100
WWW.PALACIOCOLLABORATIVE.COM

NOTE: IF THIS DRAWING IS NOT 36" X 42", IT IS A
REDUCED PRINT. REFER TO GRAPHIC SCALE.

NOT FOR
CONSTRUCTION

SEAL
23551
ENGINEER
DAVID M. HARR

NOT FOR
CONSTRUCTION

NO.	DATE	DESCRIPTION
1	9-8-25	BID SET

FIRST FLOOR PLAN -
FRESHWATER HABITAT -
DOMESTIC WATER


PW2.21 E

FLOOR PLAN LEGEND


- EXISTING BUILDING
- RENOVATED AREA
- UPFIT BY OTHERS
- 1-HR RATED WALL
- 2-HR RATED WALL
- 3-HR RATED WALL

FLOOR PLAN SHEET NOTES

- PLUMBING CONTRACTOR TO COORDINATE WITH OTHER TRADES PRIOR TO BEGINNING WORK.
- REFER TO ARCHITECTURAL DRAWINGS FOR RATED ASSEMBLY UL NUMBERS (WALLS, FLOOR / CEILING, ETC.)
- DRAWINGS: DRAWINGS ARE DIAGRAMMATIC AND MAY NOT COMPLETELY DESCRIBE EVERY DETAIL OF THE INSTALLATION. HOWEVER, CONTRACTOR IS RESPONSIBLE FOR FURNISHING COMPLETE SYSTEMS INCLUDING ALL REQUIRED EQUIPMENT AND ACCESSORIES TO OBTAIN FULLY FUNCTIONING PLUMBING SYSTEMS.
- EQUIPMENT LOCATIONS: DETERMINE EXACT EQUIPMENT AND MATERIALS LOCATIONS TO PROVIDE BEST ARRANGEMENT AND TO FACILITATE PROPER MAINTENANCE AND SERVICING OF EQUIPMENT.
- LISTING AND LABELING: ALL EQUIPMENT SHALL BE LABELED OR LISTED BY UL OR OTHER APPROVED TESTING AGENCY WHERE REQUIRED.

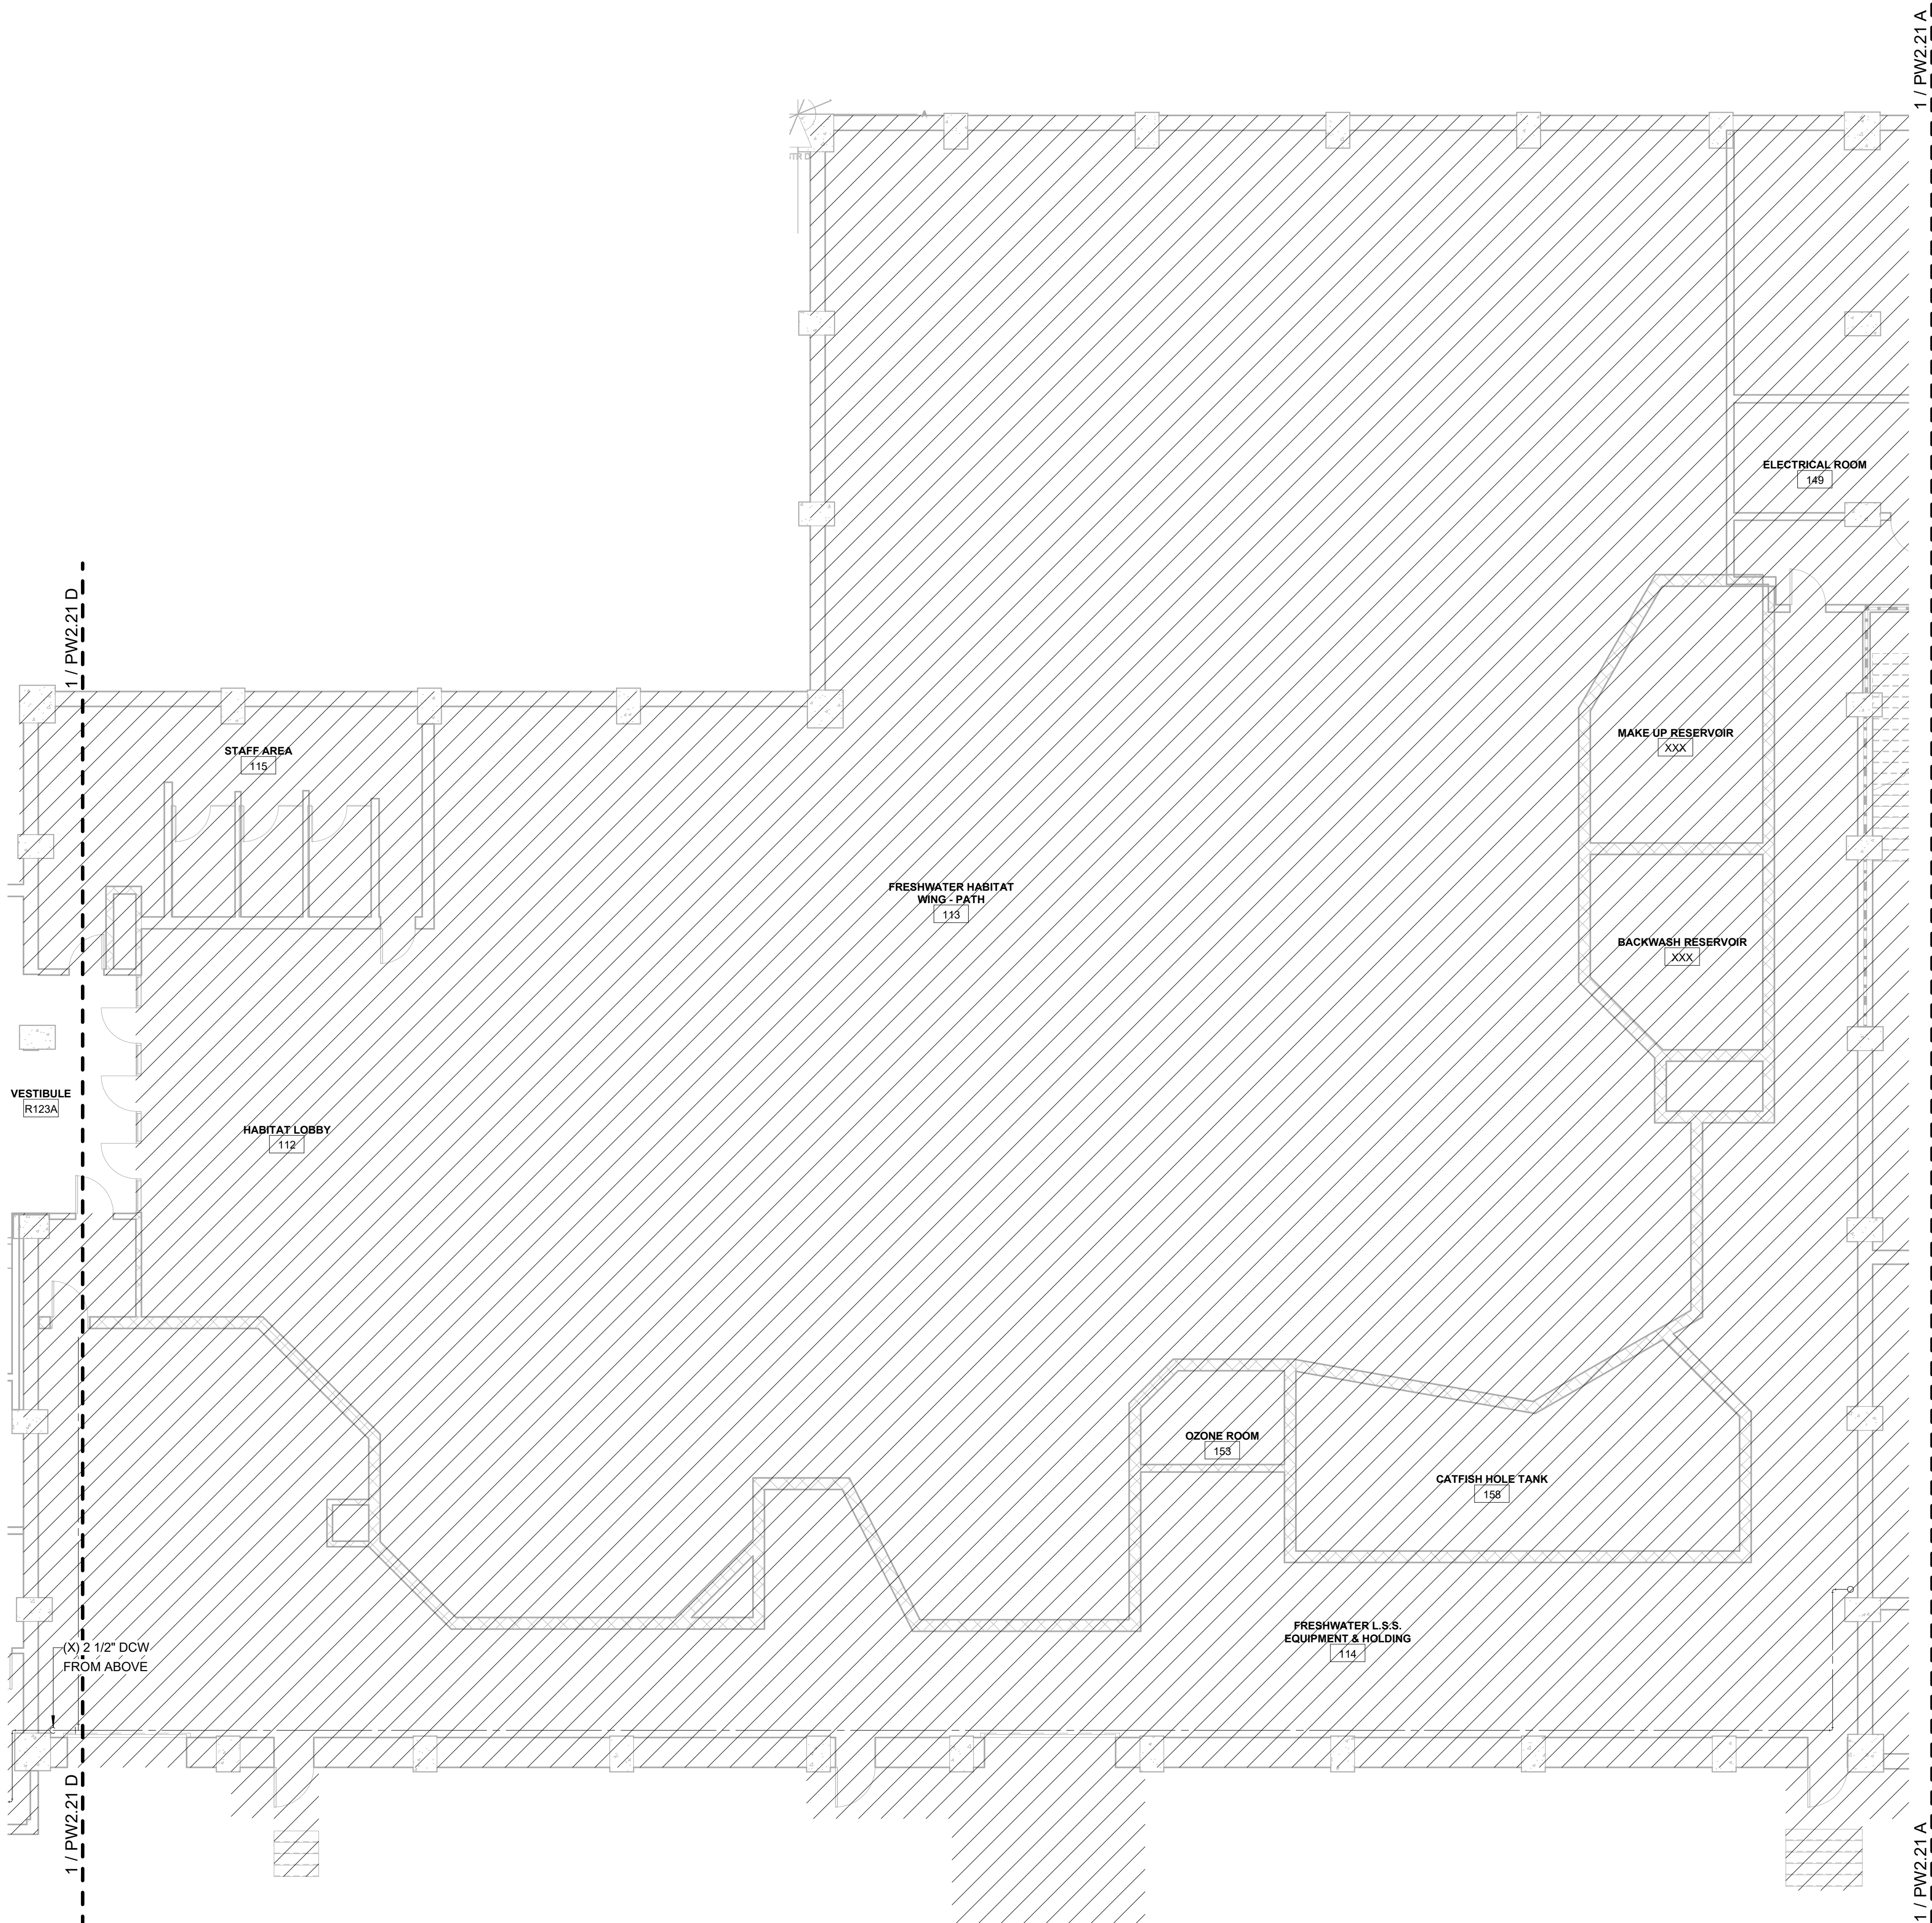

KEY PLAN

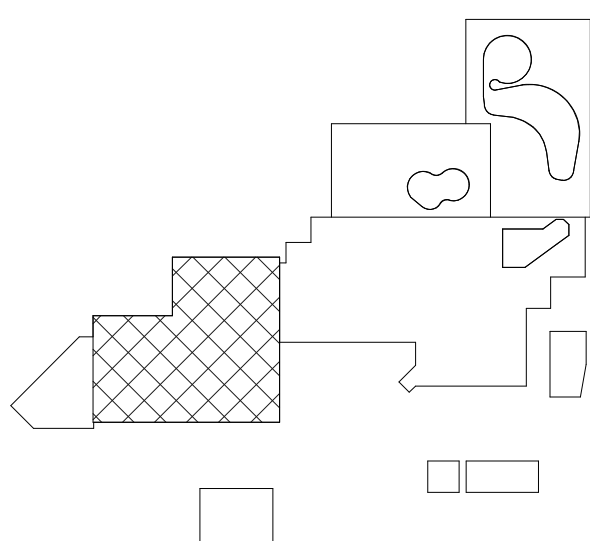

CBHF
Engineers, PLLC

2246 Yaupon Drive
Wilmington, NC 28401
Phone: 910.791.4000
Fax: 910.791.5266
www.cbhfenr.com
© Copyright 2025 CBHF Engineers, PLLC. NCIA P-0356

8' 4' 0' 8'
SCALE: 1/8" = 1'-0"

1ST FLOOR - FRESHWATER HABITAT - DOMESTIC WATER
SCALE: 1/8" = 1'-0"

SCO #17-18042-02A
CODE: 42014-4G02
ITEM: 41414-4Y4A

900 LOGGERHEAD RD,
KURE BEACH, NC 28449

NORTH CAROLINA DEPT. OF
NATURAL & CULTURAL RESOURCES

SZOSTAK DESIGN, INC.

ARCHITECT
310 1/2 WEST FRANKLIN STREET
CHAPEL HILL, NORTH CAROLINA 27516
TEL: 919.929.5244
FAX: 919.960.7967
WWW.S2OSTAKDESIGN.COM
LICENSE # 51679

TJP ENGINEERING, INC.

LIFE SUPPORT SYSTEMS ENGINEER
56880 VENTURE LANE SUITE 205N
BEND, OR 97707
TEL: 619.423.8700
WWW.TJENGINEERING.COM
LICENSE # C-3505

ROTO GROUP, LLC.

EXHIBIT DESIGNER
7001 DISCOVERY BOULEVARD
DUBLIN, OHIO 43017
TEL: 617.760.8690
WWW.ROFO.COM

BENNETT & PLESS

STRUCTURAL ENGINEER
5430 WADE PARK BOULEVARD SUITE 400
RALEIGH, NC 27607
TELE: 919.832.5587
WWW.BENNETT-PLESS.COM
LICENSE # F-1105

CBHF ENGINEERS, PLLC

MEP ENGINEER
2246 YALPON DRIVE
WILMINGTON, NC 28401
TELE: 910.791.4000
FAX: 910.791.5266
WWW.CBHFENGINEERS.COM

LIGHTSWITCH

LIGHTING DESIGNER
10265 INDIANA COURT
RANCHO CUCAMONGA, CA 91730
TEL: 909.360.2900
WWW.LIGHTSWITCH.NET

TUNSTALL CONSULTING ENGINEERS PLL

CIVIL ENGINEER
2602 IRON GATE DRIVE SUITE 102
WILMINGTON, NC 28412
TELE: 910.343.9653
FAX: 910.343.9604
WWW.NTENGINEERS.COM

SURFACE 678, PA

LANDSCAPE ARCHITECT
215 MORRIS STREET SUITE 150
DURHAM, NC 27701
TEL: 919.419.1199
FAX: 919.419.1669
WWW.SURFACE678.COM

CHEATHAM & ASSOCIATES, PA


FIRE PROTECTION ENGINEER
3412 ENTERPRISE DRIVE
WILMINGTON, NC 28405
TELE: 910.452.4210
WWW.CHEATHAMPA.COM
LICENSE # C-1073

PALACIO COLLABORATIVE

COST ESTIMATOR
4819 EMPEROR BOULEVARD SUITE 400
DURHAM, NC 27703
TELE: 919.605.8952
WWW.PALACIOCOLLABORATIVE.COM

NOTE: IF THIS DRAWING IS NOT 30" X 42", IT IS A REDUCED PRINT. REFER TO GRAPHIC SCALE.

NOT FOR
CONSTRUCTION

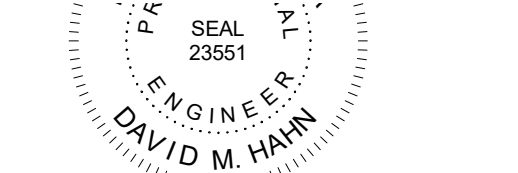

**NOT FOR
CONSTRUCTION**


NO.	DATE	DESCRIPTION
1	9-8-25	BID SET

SECOND FLOOR PLAN -
CAPE FEAR SHOALS -
DOMESTIC WATER


PW2.22 A

	EXISTING BUILDING
	RENOVATED AREA
	UPFIT BY OTHERS
	1-HR RATED WALL
	2-HR RATED WALL
	3-HR RATED WALL

1. PLUMBING CONTRACTOR TO COORDINATE WITH OTHER TRADES PRIOR TO BEGINNING WORK.
2. REFER TO ARCHITECTURAL DRAWINGS FOR RATED ASSEMBLY U/L NUMBERS (WALLS, FLOOR/CEILING, ETC.)
3. DRAWINGS: DRAWINGS ARE DIAGRAMMATIC AND MAY NOT COMPLETELY DESCRIBE EVERY DETAIL OF THE INSTALLATION. HOWEVER, CONTRACTOR IS RESPONSIBLE FOR THE PROPER INSTALLATION OF SYSTEMS INCLUDING ALL REQUIRED EQUIPMENT AND ACCESSORIES TO OBTAIN FULLY FUNCTIONING PLUMBING SYSTEMS.
4. EQUIPMENT LOCATIONS: DETERMINE EXISTING EQUIPMENT AND MATERIALS LOCATIONS TO PROVIDE BEST ARRANGEMENT AND TO FACILITATE PROPER MAINTENANCE AND SERVING OF EQUIPMENT.
5. LISTING AND LABELING: ALL EQUIPMENT SHALL BE LABELED OR LISTED BY UL OR OTHER APPROVED TESTING AGENCY WHERE REQUIRED.

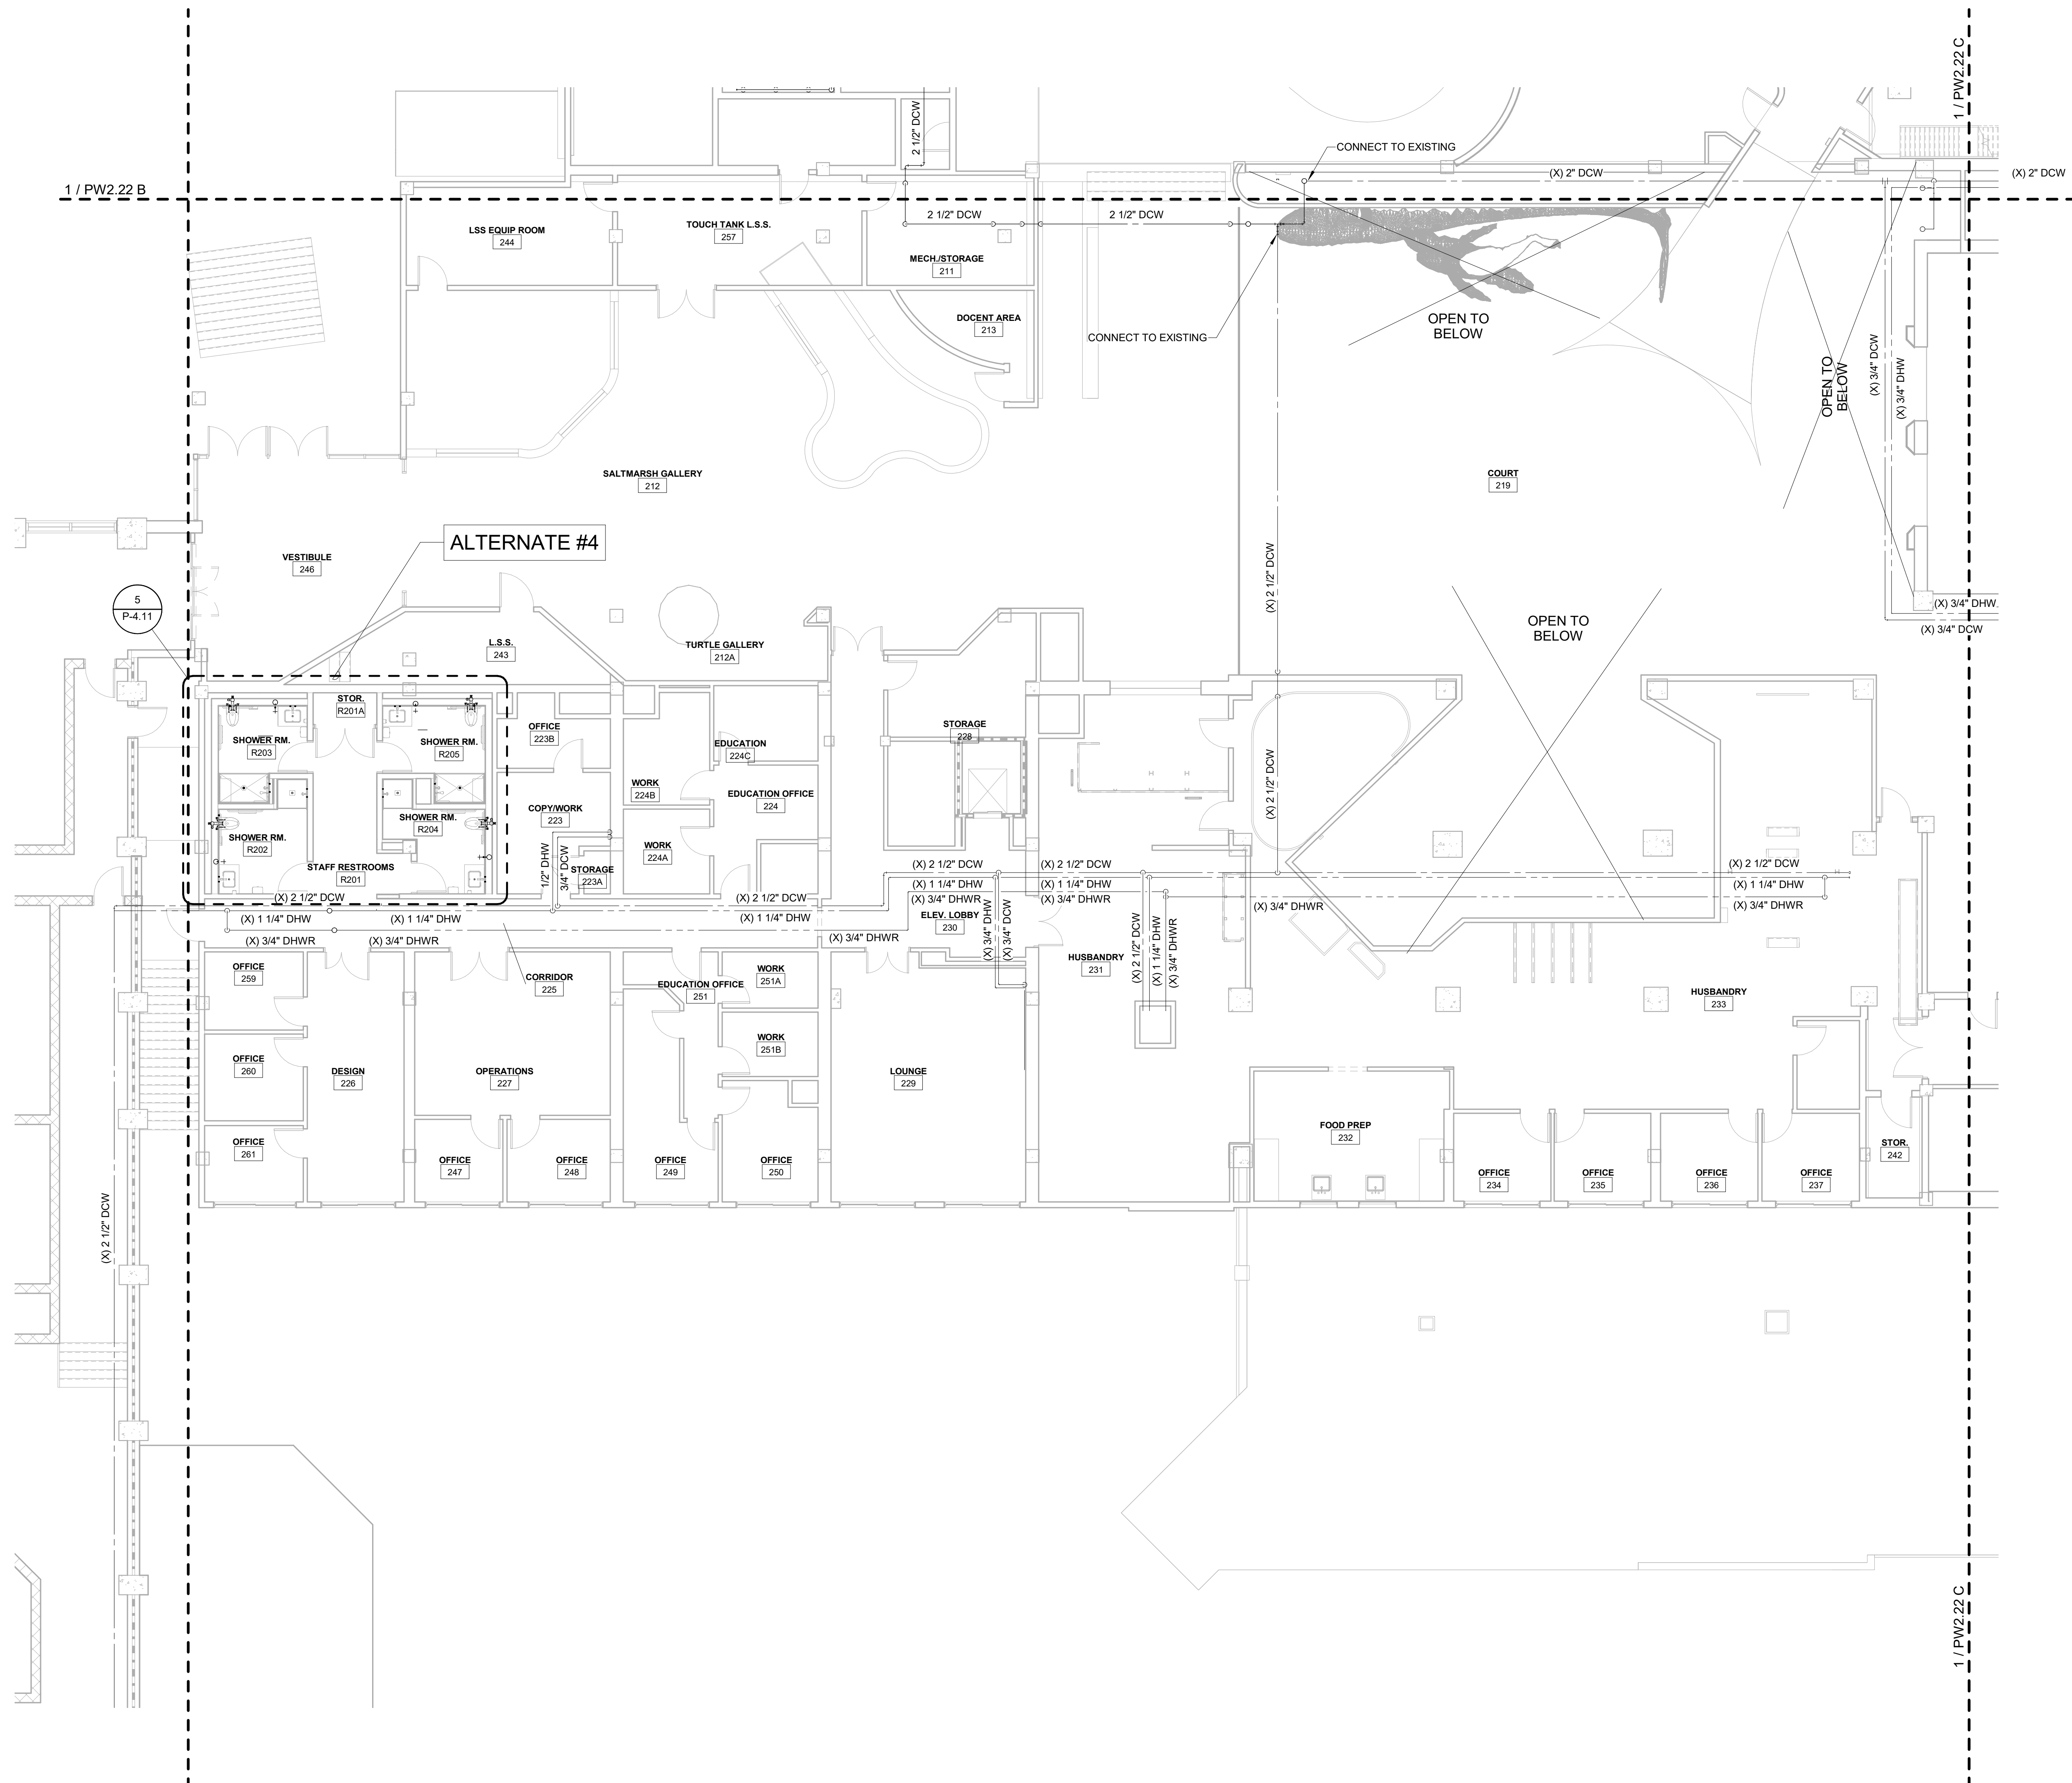

KEY PLAN

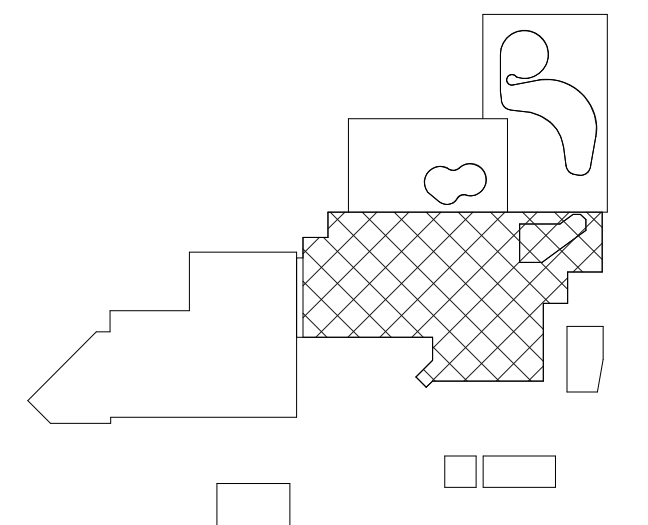

CBHF
Engineers, PLLC

2246 Yaupon Drive
Wilmington, NC 28401
Phone: 910.791.4000
Fax: 910.791.5266
www.cbhfengineers.com
Copyright 2025 CBHF Engineers, PLLC NC# P-0506

8' 4' 0' 8'



SCALE: 1/8" = 1'-0"

2ND FLOOR - CAPE FEAR SHOALS - DOMESTIC WATER
SCALE : 1/8" = 1'-0"

1

SZOSTAK DESIGN

FORT FISHER
AQUARIUM
RENOVATION
& EXPANSION:
PHASE 1

SCO #17-18042-02A
CODE: 42014-4G02
ITEM: 41414-4Y4A

900 LOGGERHEAD RD,
KURE BEACH, NC 28449

NORTH CAROLINA DEPT. OF
NATURAL & CULTURAL RESOURCES

SZOSTAK DESIGN, INC.

ARCHITECT
310 1/2 WEST FRANKLIN STREET
CHAPEL HILL, NORTH CAROLINA 27514
TEL: 919.929.5244
FAX: 919.960.7967
WWW.SZOSTAKDESIGN.COM
LICENSE # 31079

TJP ENGINEERING, INC.

LIFE SUPPORT SYSTEMS ENGINEER
5680 VENTURE LANE SUITE 205N
BEND, OR 97007
TEL: 503.433.0300
WWW.TJPEENGINEERING.COM
LICENSE # C-3505

ROTO GROUP, LLC.

EXHIBIT DESIGNER
7001 DISCOVERY BOULEVARD
DURHAM, NC 27707
TEL: 919.282.5587
WWW.ROTO.COM
LICENSE # C-3505

BENNETT & PLESS

STRUCTURAL ENGINEER
5430 WADE PARK BOULEVARD SUITE 400
RALEIGH, NC 27607
TEL: 919.822.5587
WWW.BENNETT-PLESS.COM
LICENSE # F-1105

CBHF ENGINEERS, PLLC

MFP ENGINEER
2246 YAUPON DRIVE
WILMINGTON, NC 28401
TEL: 910.791.4000
FAX: 910.791.5266
WWW.CBHFENGINEERS.COM
LICENSE # P-6564

LIGHTSWITCH

LIGHTING DESIGNER
10665 INDIANA COURT
RANCHO CUCAMONGA, CA 91730
TEL: 909.360.7000
WWW.LIGHTSWITCH.NET

TUNSTALL CONSULTING ENGINEERS PLLC

CIVIL ENGINEER
2405 BROWN GATE DRIVE SUITE 102
WILMINGTON, NC 28412
TEL: 910.343.9433
FAX: 910.343.9404
WWW.TUNSTALLENGINEERS.COM
LICENSE # F-3132

SURFACE 678, PA

LANDSCAPE ARCHITECT
215 MORRIS STREET SUITE 150
DURHAM, NC 27701
TEL: 919.419.1199
FAX: 919.419.1688
WWW.SURFACE678.COM
LICENSE # C-3086

CHEATHAM & ASSOCIATES, PA

FIRE PROTECTION ENGINEER
3412 ENDRISPE DRIVE
WILMINGTON, NC 28405
TEL: 910.452.6110
WWW.CHEATHAMP&A.COM
LICENSE # C-1073

PALACIO COLLABORATIVE

COST ESTIMATOR
4817 EXETER BOULEVARD SUITE 400
DURHAM, NC 27705
TEL: 919.453.9100
WWW.PALACIOCOLLABORATIVE.COM

NOTE: IF THIS DRAWING IS NOT 36" X 42", IT IS A
REDUCED PRINT. REFER TO GRAPHIC SCALE.

NOT FOR
CONSTRUCTION

SEAL
23551
ENGINEER
DAVID M. HARRIS

NOT FOR
CONSTRUCTION


NO.	DATE	DESCRIPTION
1	9-8-25	BID SET

SECOND FLOOR PLAN -
TOUCH AND SHARK TANK -
DOMESTIC WATER

PW2.22 B

KEYNOTES THIS SHEET

1	2-1/2" DCW FROM BELOW. SEE SHEET PW2.21B FOR CONTINUATION
2	2-1/2" DCW UP TO LEVEL ABOVE. SEE PW2.23B FOR CONTINUATION
3	2-1/2" DCW DOWN. SEE SHEET PW2.21B FOR CONTINUATION
4	3/4" DCW UP AND DOWN. SEE SHEETS PW2.21B AND PW2.23B FOR CONTINUATION
5	3/4" DCW FROM ABOVE. SEE SHEET PW2.23B FOR CONTINUATION
6	3/4" DCW DOWN. SEE SHEET PW2.21B FOR CONTINUATION

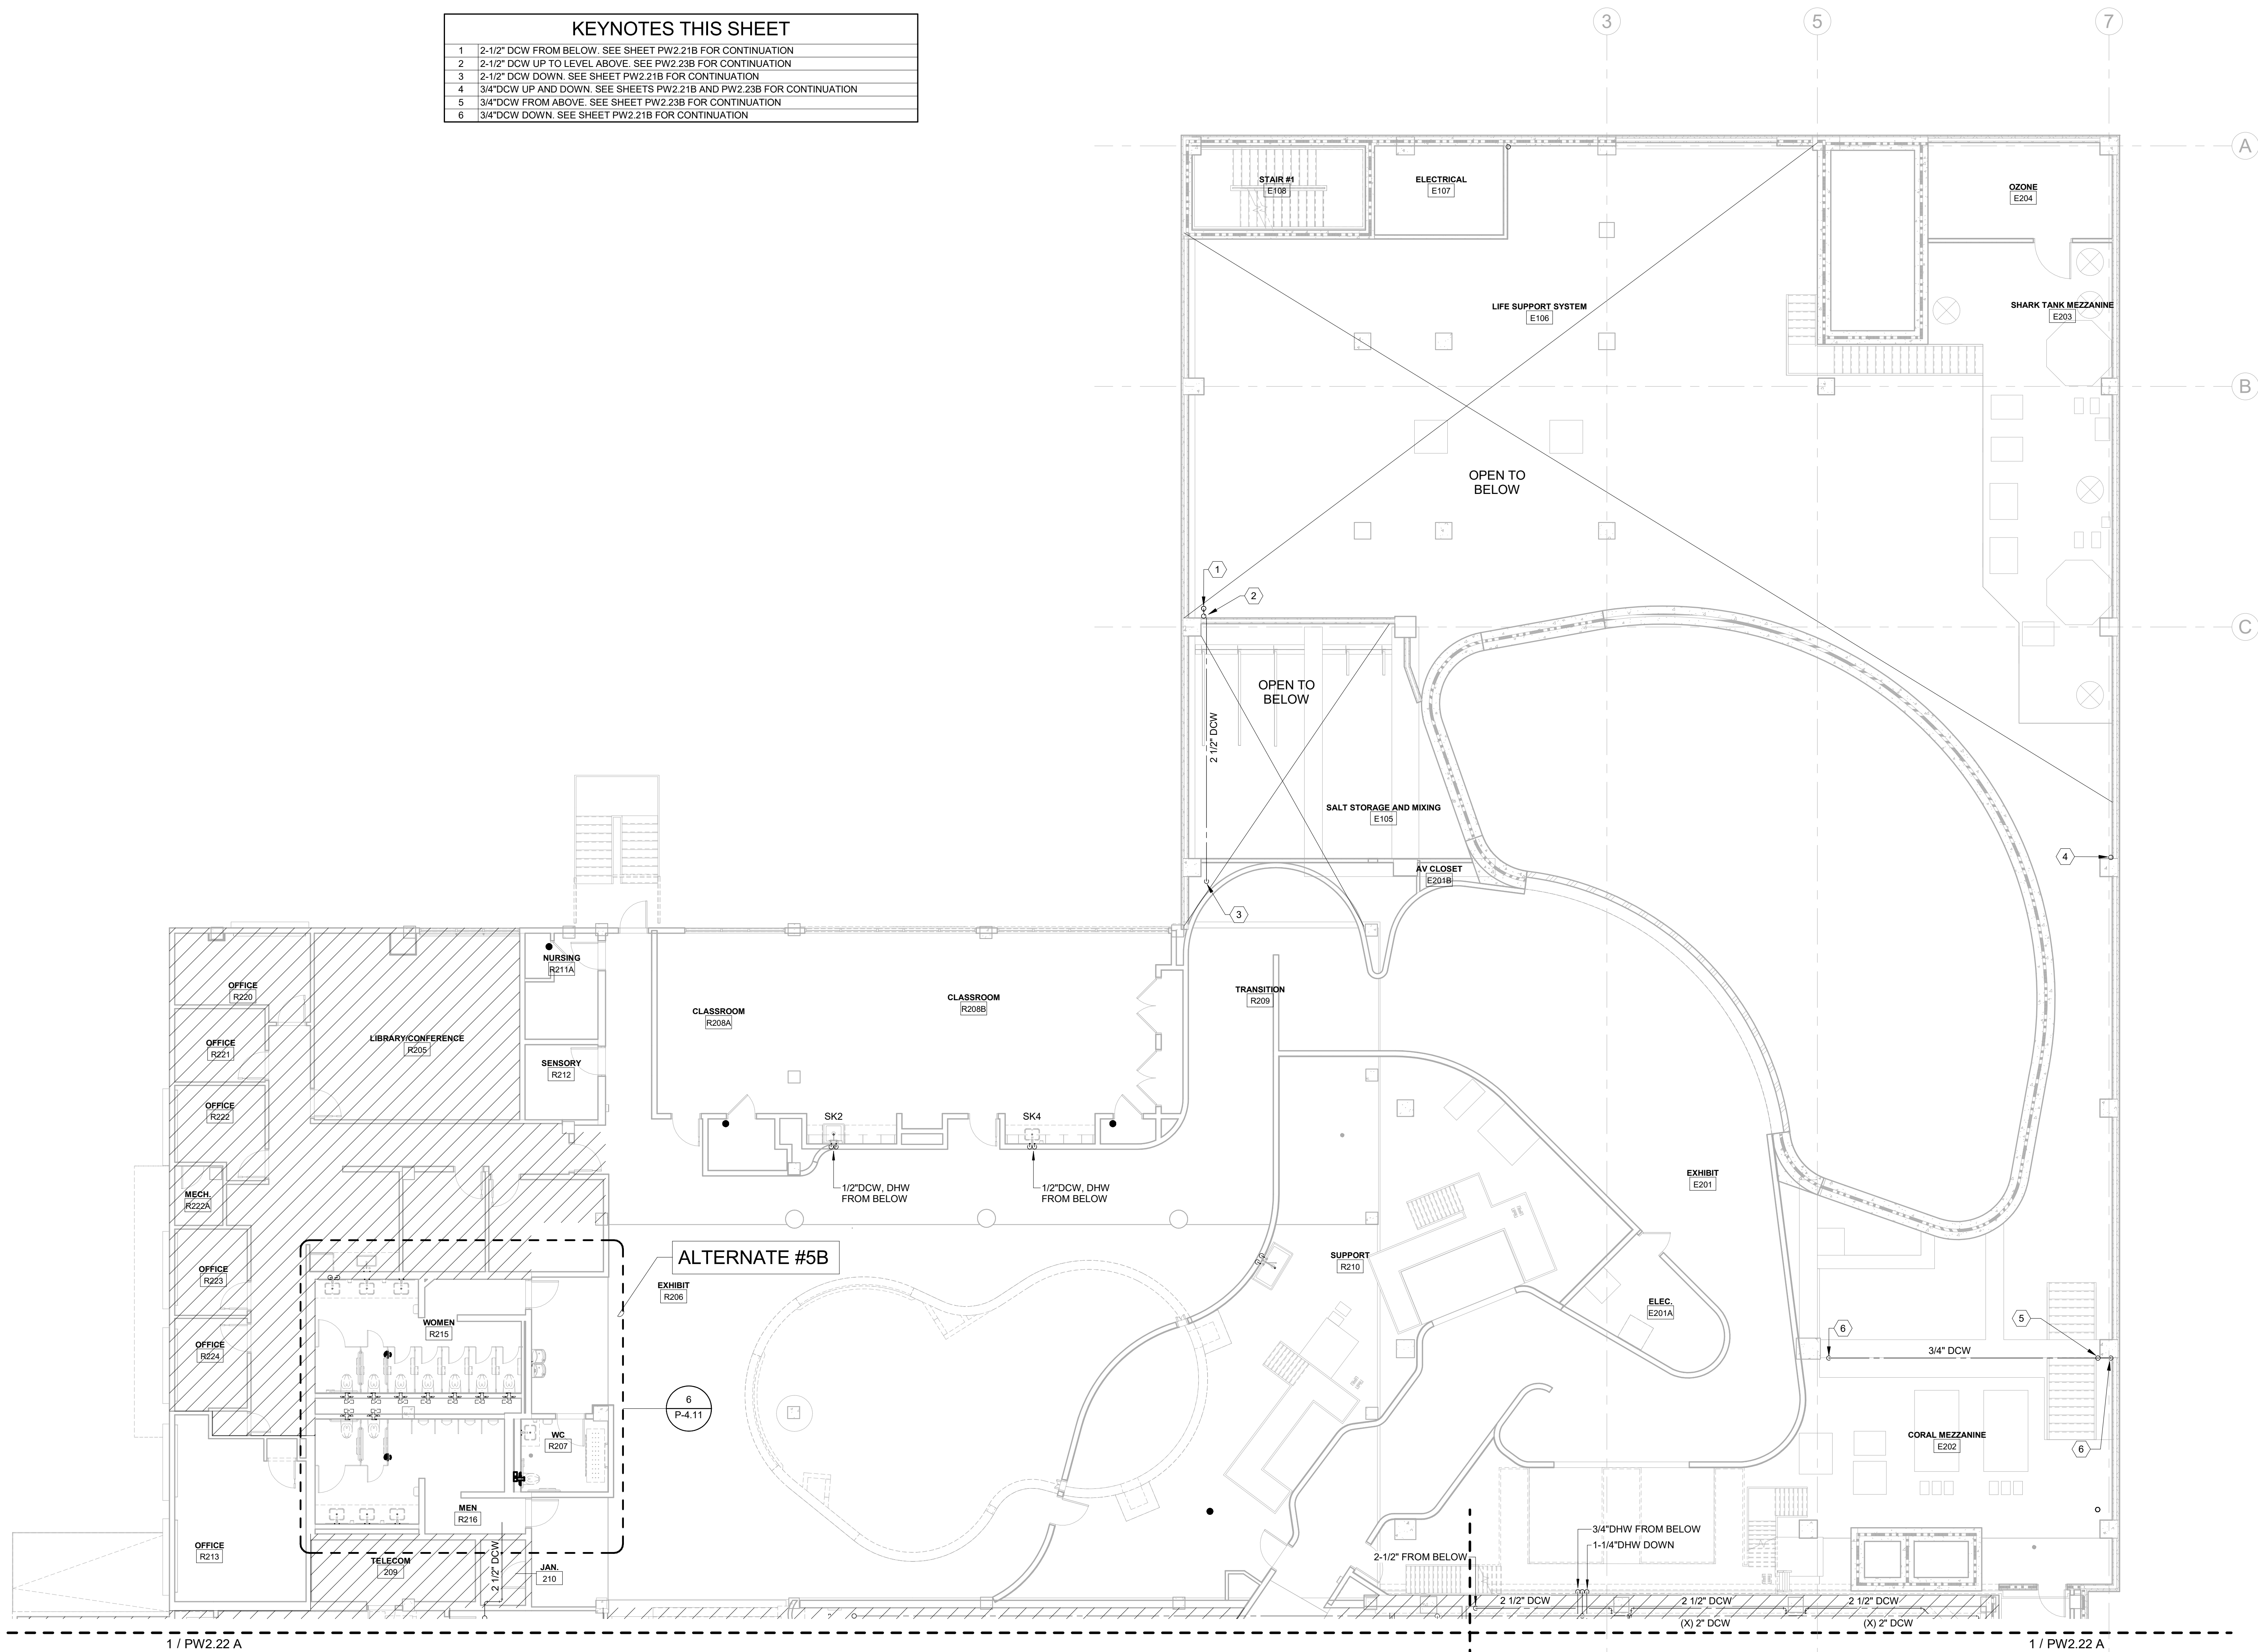


KEY PLAN

CBHF
Engineers, PLLC

2246 Yaupon Drive
Wilmington, NC 28401
Phone: 910.791.4000
Fax: 910.791.5266
www.cbhfindesign.com
© Copyright 2025 CBHF Engineers, PLLC. NCIA P-0306

8' 4' 0' 8'
SCALE: 1/8" = 1'-0"

2ND FLOOR - TOUCH AND SHARK TANK - DOMESTIC WATER
SCALE: 1/8" = 1'-0"

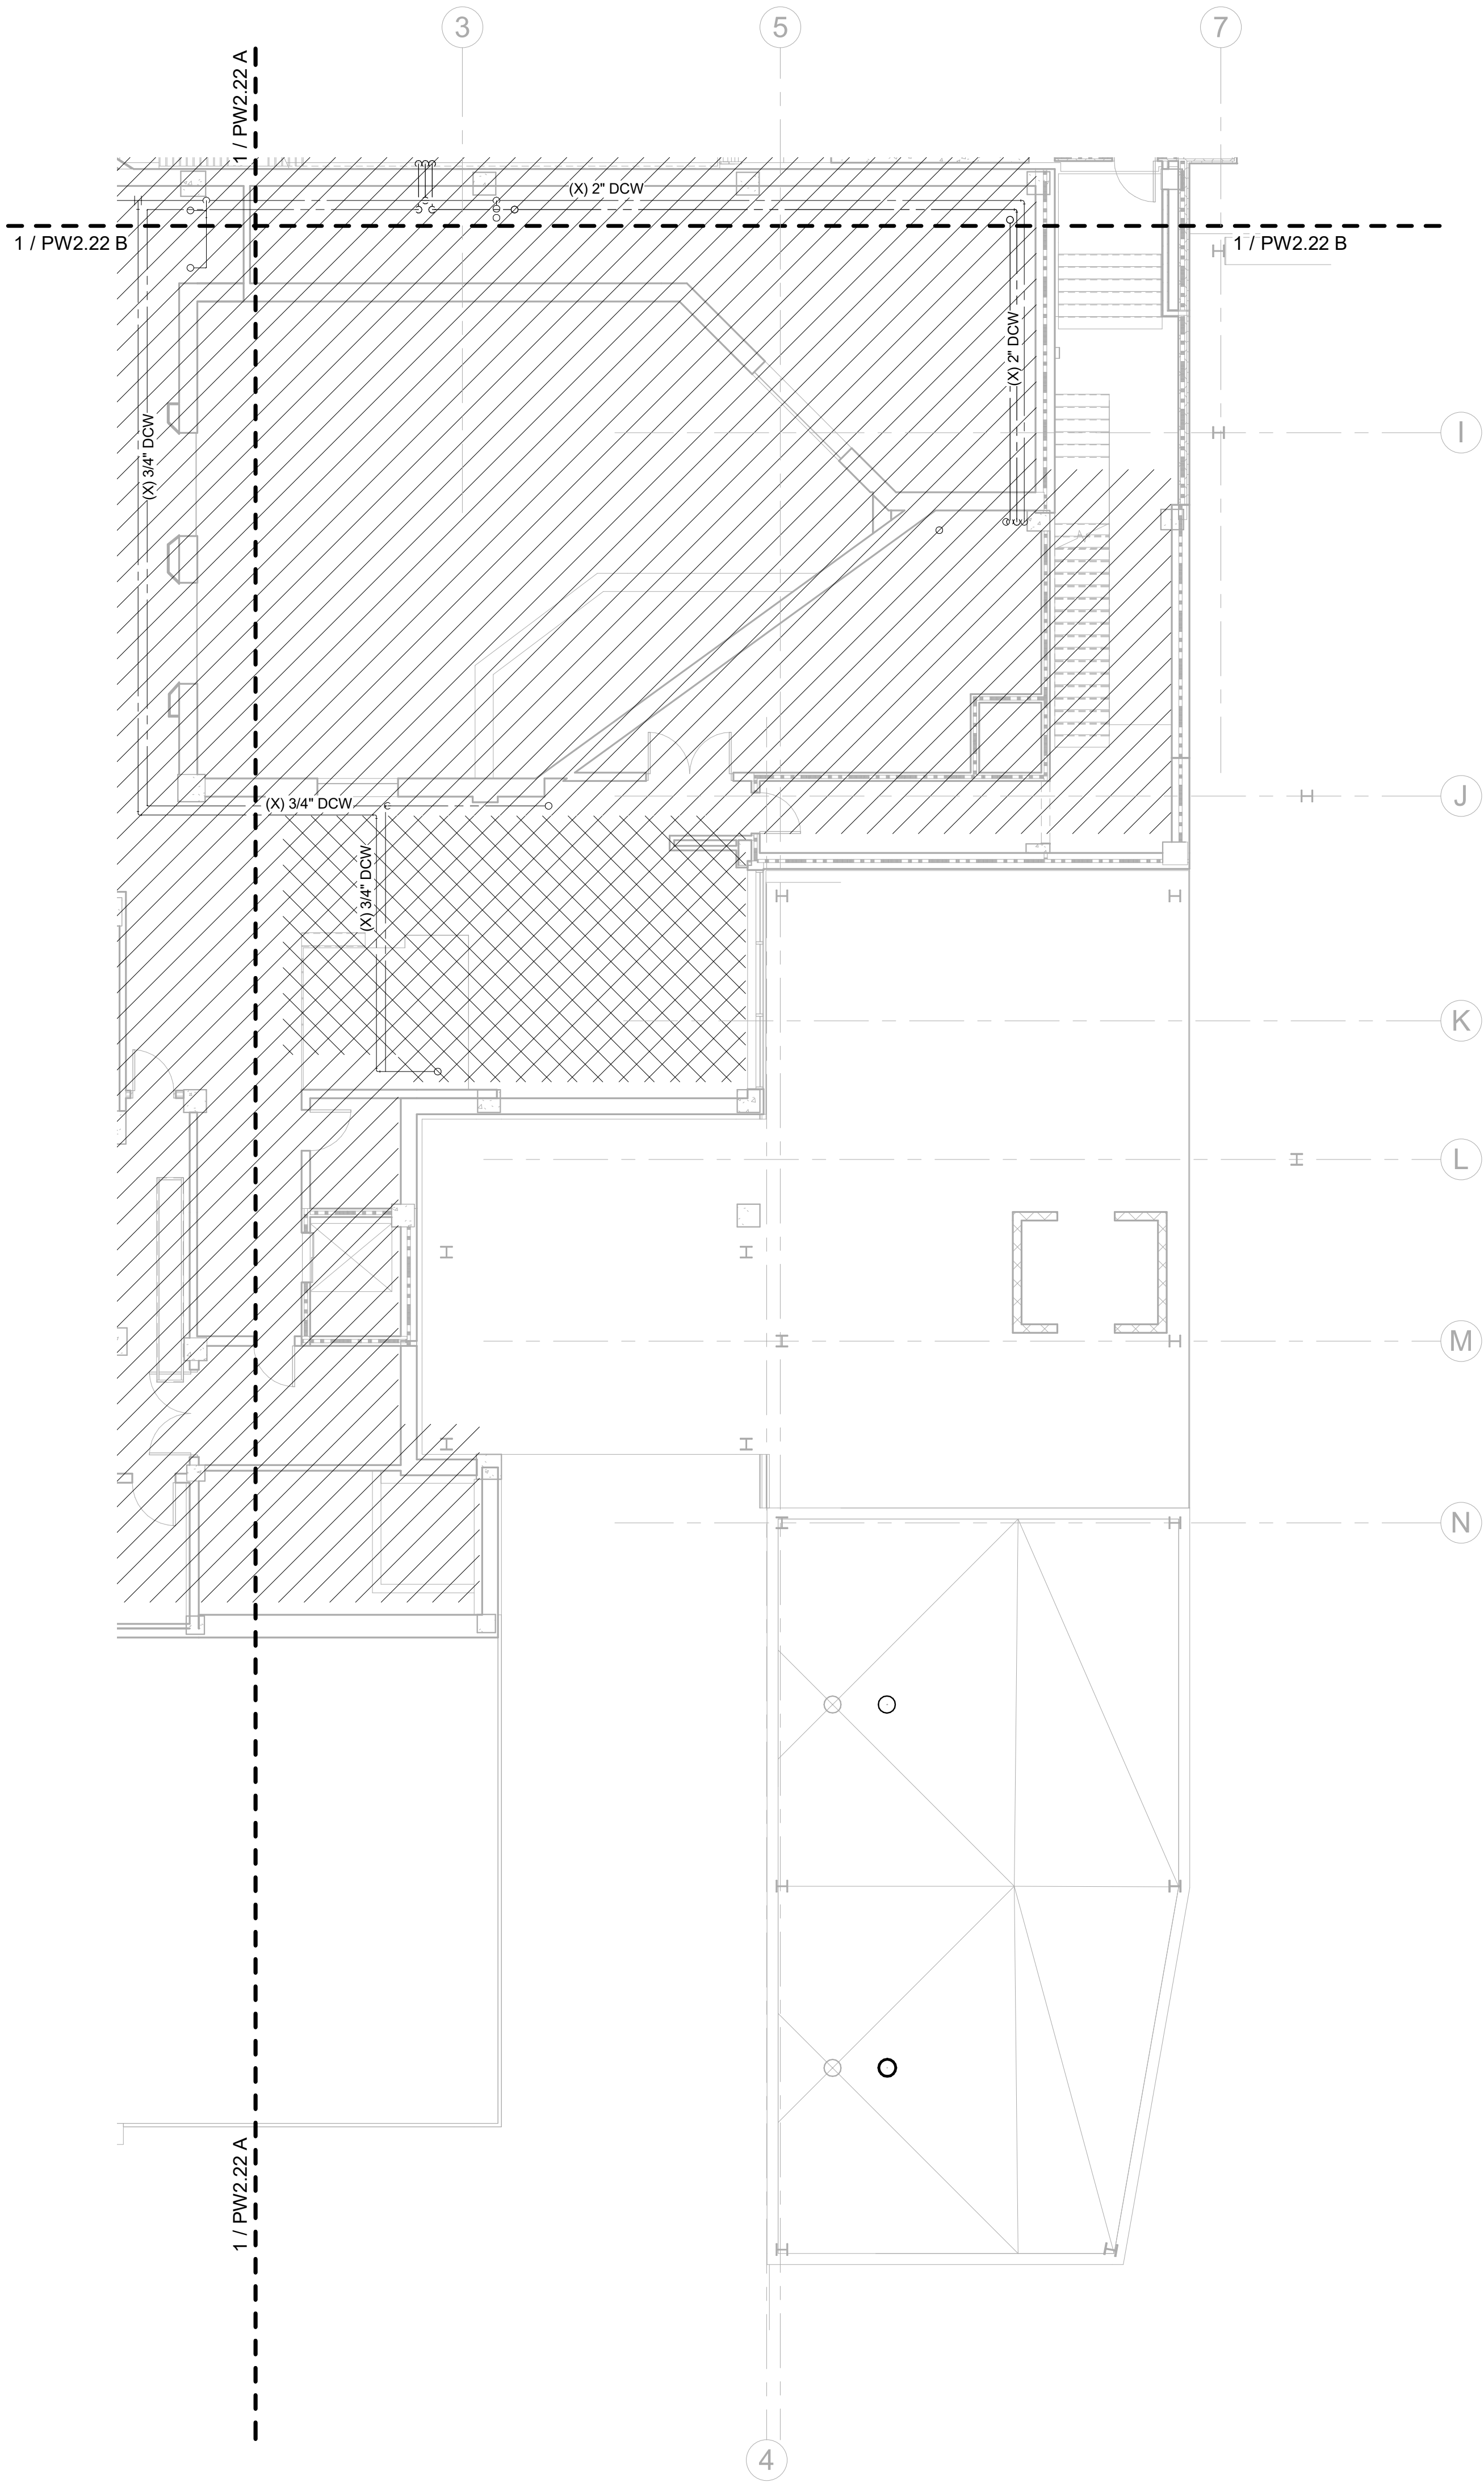

FLOOR PLAN LEGEND	
	EXISTING BUILDING
	RENOVATED AREA
	UPFIT BY OTHERS
	1-HR RATED WALL
	2-HR RATED WALL
	3-HR RATED WALL

- FLOOR PLAN SHEET NOTES**
1. PLUMBING CONTRACTOR TO COORDINATE WITH OTHER TRADES PRIOR TO BEGINNING WORK.
 2. REFER TO ARCHITECTURAL DRAWINGS FOR RATED ASSEMBLY UL NUMBERS (WALLS, FLOOR / CEILING, ETC.)
 3. DRAWINGS: DRAWINGS ARE DIAGRAMMATIC AND MAY NOT COMPLETELY DESCRIBE EVERY DETAIL OF THE INSTALLATION. HOWEVER, CONTRACTOR IS RESPONSIBLE FOR FURNISHING COMPLETE SYSTEMS INCLUDING ALL REQUIRED EQUIPMENT AND ACCESSORIES TO OBTAIN FULLY FUNCTIONING PLUMBING SYSTEMS.
 4. EQUIPMENT LOCATIONS: DETERMINE EXACT EQUIPMENT AND MATERIALS LOCATIONS TO PROVIDE BEST ARRANGEMENT AND TO FACILITATE PROPER MAINTENANCE AND SERVICING OF EQUIPMENT.
 5. LISTING AND LABELING: ALL EQUIPMENT SHALL BE LABELED OR LISTED BY UL OR OTHER APPROVED TESTING AGENCY WHERE REQUIRED.

SZOSTAK DESIGN

FORT FISHER AQUARIUM RENOVATION & EXPANSION: PHASE 1

SCO #17-18042-02A
CODE: 42014-4G02
ITEM: 41414-4Y4A

900 LOGGERHEAD RD,
KURE BEACH, NC 28449

NORTH CAROLINA DEPT. OF
NATURAL & CULTURAL RESOURCES

SZOSTAK DESIGN, INC.

ARCHITECT
310 1/2 WEST FRANKLIN STREET
CHAPEL HILL, NORTH CAROLINA 27514
TEL: 919.929.5244
FAX: 919.960.7967
WWW.SZOSTAKDESIGN.COM
LICENSE # 31079

TJP ENGINEERING, INC.

LIFE SUPPORT SYSTEMS ENGINEER
5680 VENTURE LANE SUITE 205N
BEND, OR 97707
TEL: 419.433.0000
WWW.TJPEENGINEERING.COM
LICENSE # C-3505

ROTO GROUP, LLC.

EXHIBIT DESIGNER
7001 DISCOVERY BOULEVARD
DUBLIN, OHIO 43017
TEL: 617.760.6895
WWW.ROTO.COM

BENNETT & PLESS

STRUCTURAL ENGINEER
5430 WADE PARK BOULEVARD SUITE 400
RALEIGH, NC 27607
TEL: 919.832.5587
WWW.BENNETT-PLESS.COM
LICENSE # F-1105

CBHF ENGINEERS, PLLC

MFP ENGINEER
2246 YAUPOH DRIVE
WILMINGTON, NC 28401
TEL: 910.791.4000
FAX: 910.791.5566
WWW.CBHFENGINEERS.COM
LICENSE # P-6564

LIGHTSWITCH

LIGHTING DESIGNER
10565 INDIANA COURT
RANCHO CUCAMONGA, CA 91730
TEL: 909.360.0000
WWW.LIGHTSWITCH.NET

TUNSTALL CONSULTING ENGINEERS PLLC

CIVIL ENGINEER
2405 IRON GATE DRIVE SUITE 102
WILMINGTON, NC 28412
TEL: 910.343.9433
FAX: 910.343.9404
WWW.TUNSTALLENGINEERS.COM
LICENSE # F-3132

SURFACE 678, PA

LANDSCAPE ARCHITECT
215 AGRIS STREET SUITE 150
DURHAM, NC 27705
TEL: 919.419.1199
FAX: 919.419.1689
WWW.SURFACE678.COM
LICENSE # C-096

CHEATHAM & ASSOCIATES, PA

FIRE PROTECTION ENGINEER
3412 ENTERPRISE DRIVE
WILMINGTON, NC 28405
TEL: 910.452.4510
WWW.CHEATHAMPA.COM
LICENSE # C-1073

PALACIO COLLABORATIVE

COST ESTIMATOR
4817 ENTERPRISE BOULEVARD SUITE 400
DURHAM, NC 27705
TEL: 919.403.9910
WWW.PALACIOCOLLABORATIVE.COM

NOTE: IF THIS DRAWING IS NOT 30" X 42", IT IS A
REDUCED PRINT. REFER TO GRAPHIC SCALE.

NOT FOR
CONSTRUCTION

SEAL
23551
ENGINEER
DAVID M. HARR

NOT FOR
CONSTRUCTION

NO.	DATE	DESCRIPTION
1	9-8-25	BID SET


SECOND FLOOR PLAN -
SOUTHEAST WING -
DOMESTIC WATER

PW2.22 C

CBHF
Engineers, PLLC
2246 Yaupon Drive
Wilmington, NC 28401
Phone: 910.791.4000
Fax: 910.791.5566
www.cbhfengineers.com
© Copyright 2025 CBHF Engineers, PLLC. NCCE # 0356

8' 4' 0' 8'
SCALE: 1/8" = 1'-0"

2ND FLOOR - SOUTHEAST WING - DOMESTIC WATER
SCALE: 1/8" = 1'-0"

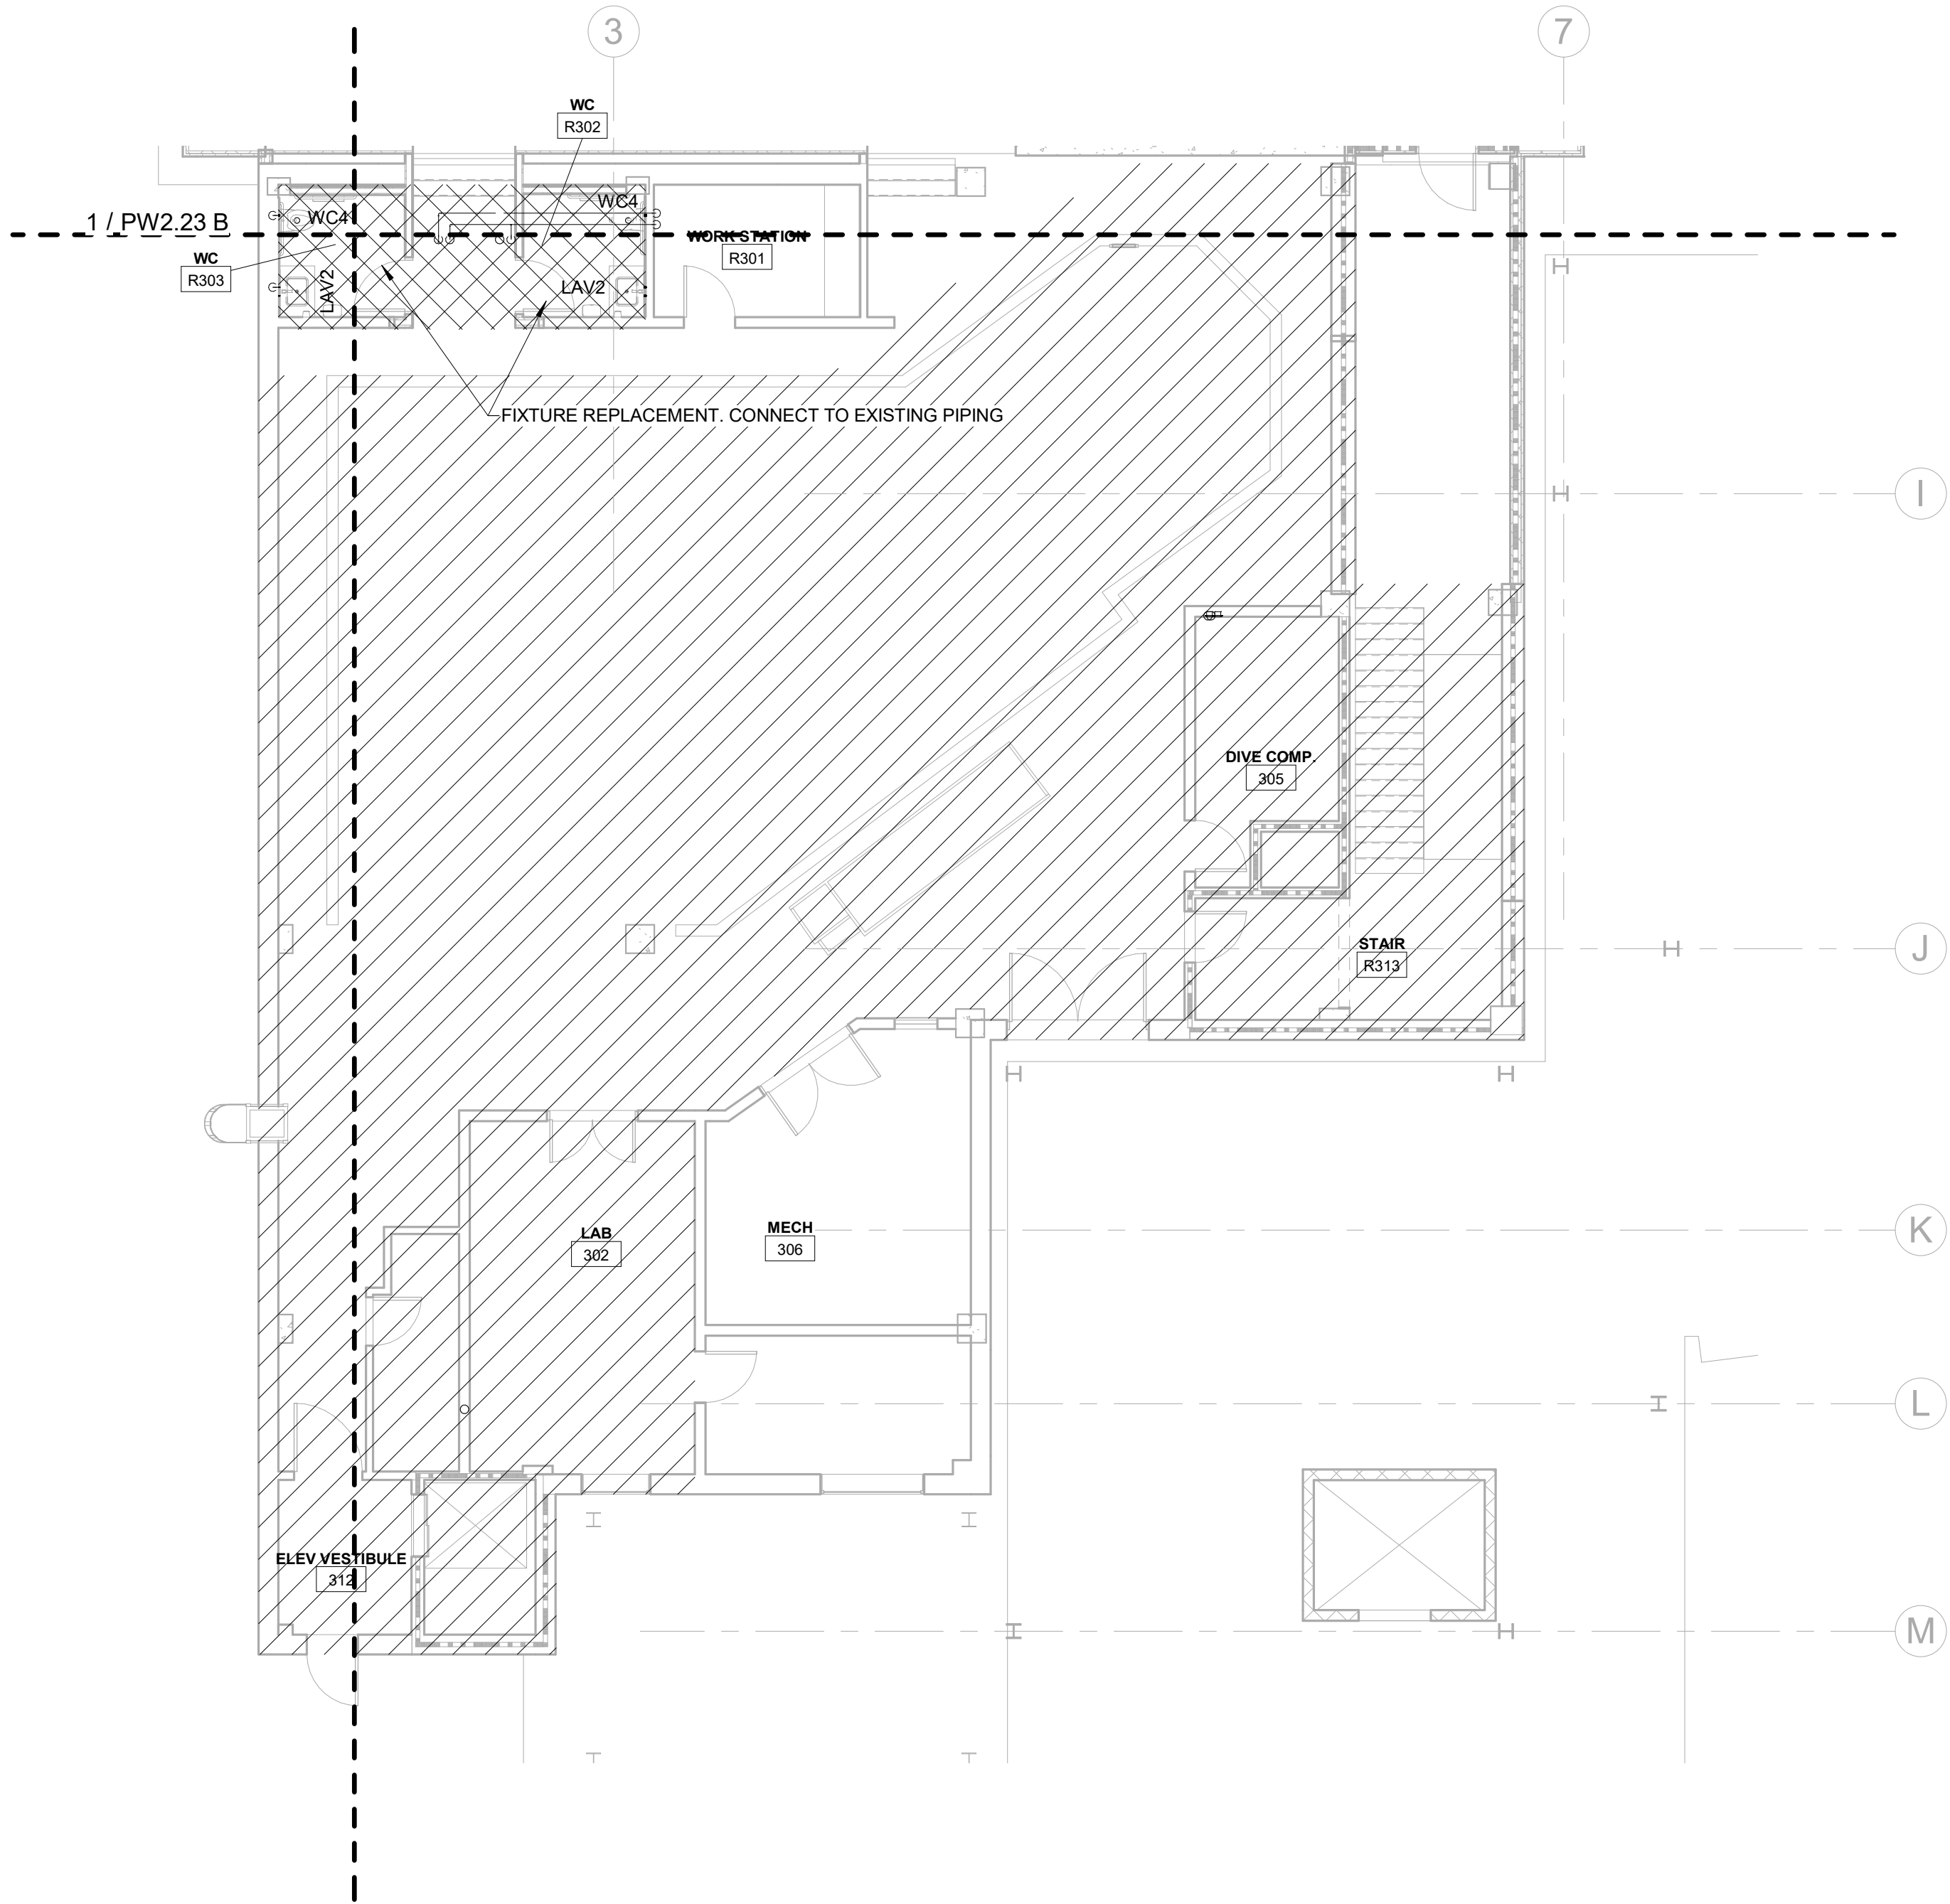

FLOOR PLAN LEGEND	
	EXISTING BUILDING
	RENOVATED AREA
	UPFIT BY OTHERS
	1-HR RATED WALL
	2-HR RATED WALL
	3-HR RATED WALL

- FLOOR PLAN SHEET NOTES**
1. PLUMBING CONTRACTOR TO COORDINATE WITH OTHER TRADES PRIOR TO BEGINNING WORK.
 2. REFER TO ARCHITECTURAL DRAWINGS FOR RATED ASSEMBLY UL NUMBERS (WALLS, FLOOR / CEILING, ETC.)
 3. DRAWINGS: DRAWINGS ARE DIAGRAMMATIC AND MAY NOT COMPLETELY DESCRIBE EVERY DETAIL OF THE INSTALLATION. HOWEVER, CONTRACTOR IS RESPONSIBLE FOR FURNISHING COMPLETE SYSTEMS INCLUDING ALL REQUIRED EQUIPMENT AND ACCESSORIES TO OBTAIN FULLY FUNCTIONING PLUMBING SYSTEMS.
 4. EQUIPMENT LOCATIONS: DETERMINE EXACT EQUIPMENT AND MATERIALS LOCATIONS TO PROVIDE BEST ARRANGEMENT AND TO FACILITATE PROPER MAINTENANCE AND SERVICING OF EQUIPMENT.
 5. LISTING AND LABELING: ALL EQUIPMENT SHALL BE LABELED OR LISTED BY UL OR OTHER APPROVED TESTING AGENCY WHERE REQUIRED.

- SZOSTAK DESIGN, INC.**
ARCHITECT
310 1/2 WEST FRANKLIN STREET
CHAPEL HILL, NORTH CAROLINA 27514
TEL: 919.929.5244
FAX: 919.960.7967
WWW.SZOSTAKDESIGN.COM
LICENSE # 31079
- TJP ENGINEERING, INC.**
LIFE SUPPORT SYSTEMS ENGINEER
5680 VENTURE LANE SUITE 205N
BEND, OR 97007
TEL: 503.433.0000
WWW.TJPEENGINEERING.COM
LICENSE # C-3505
- ROTO GROUP, LLC.**
EXHIBIT DESIGNER
7001 DISCOVERY BOULEVARD
DURHAM, NC 27707
TEL: 919.760.6690
WWW.ROTO.COM
- BENNETT & PLESS**
STRUCTURAL ENGINEER
5430 WADE PARK BOULEVARD SUITE 400
RALEIGH, NC 27607
TEL: 919.832.5587
WWW.BENNETTPLESS.COM
LICENSE # F-1105
- CBHF ENGINEERS, PLLC**
MEP ENGINEER
2244 YAUPOH DRIVE
WILMINGTON, NC 28401
TEL: 910.791.4000
FAX: 910.791.2546
WWW.CBHFENGINEERS.COM
LICENSE # F-0554
- LIGHTSWITCH**
LIGHTING DESIGNER
10365 INDIANA COURT
RANCHO CUCAMONGA, CA 91730
TEL: 909.360.0900
WWW.LIGHTSWITCH.NET
- TUNSTALL CONSULTING ENGINEERS PLLC**
CIVIL ENGINEER
2405 IRON GATE DRIVE SUITE 102
WILMINGTON, NC 28412
TEL: 910.343.9433
FAX: 910.343.9404
WWW.TUNSTALLENGINEERS.COM
LICENSE # F-3132
- SURFACE 678, PA**
LANDSCAPE ARCHITECT
215 AGRIS STREET SUITE 150
DURHAM, NC 27701
TEL: 919.419.1199
FAX: 919.419.1689
WWW.SURFACE678.COM
LICENSE # C-096
- CHEATHAM & ASSOCIATES, PA**
FIRE PROTECTION ENGINEER
3412 ENTERPRISE DRIVE
WILMINGTON, NC 28405
TEL: 910.452.4510
WWW.CHEATHAMPA.COM
LICENSE # C-1073
- PALACIO COLLABORATIVE**
COST ESTIMATOR
4815 ENTERPRISE BOULEVARD SUITE 400
DURHAM, NC 27705
TEL: 919.403.9700
WWW.PALACIOCOLLABORATIVE.COM

NOTE: IF THIS DRAWING IS NOT 30" X 42", IT IS A REDUCED PRINT. REFER TO GRAPHIC SCALE.

NOT FOR
CONSTRUCTION




NOT FOR
CONSTRUCTION

NO.	DATE	DESCRIPTION
1	9-8-25	BID SET

THIRD FLOOR PLAN -
SOUTHEAST WING -
DOMESTIC WATER

PW2.23 A

CBHF
Engineers, PLLC
2246 Yaupon Drive
Wilmington, NC 28401
Phone: 910.791.4000
Fax: 910.791.5266
www.cbhfindesign.com
© Copyright 2025 CBHF Engineers, PLLC. NCIA # 0356

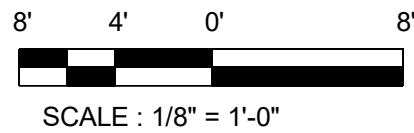

FORT FISHER
AQUARIUM
RENOVATION
& EXPANSION:
PHASE 1

900 LOGGERHEAD RD,
JURE BEACH, NC 28449

NORTH CAROLINA DEPT. OF
NATURAL & CULTURAL RESOURCES

IP ENGINEERING, INC.
 E SUPPORT SYSTEMS ENGINEER
 180 VENTURE LANE SUITE 205N
 ND, OR 97707
 E: 619.423.8700
 WWW.IPENGINEERING.COM
 ENSE # C-3505

BENNETT & PLESS
STRUCTURAL ENGINEER
10 WADE PARK BOULEVARD SUITE 400
LEIGH, NC 27607
TE: 919.832.5587
WWW.BENNETT-PLESS.COM
ENSE # F-1105

LIGHTSWITCH
LIGHTING DESIGNER
1845 INDIANA COURT
SAN JOSE CUCAMONGA, CA 91730
PHONE: 909.360.2900
WWW.LIGHTSWITCH.NET

INSTALL CONSULTING ENGINEERS F
IL ENGINEER
2 IRON GATE DRIVE SUITE 102
AMINGTON, NC 28412
E: 910.343.9653
X: 910.343.9604
WWW.TENGINEERS.COM
ENR # P-3152

SURFACE 678, PA
LANDSCAPE ARCHITECT
101 MORRIS STREET SUITE 150
RHAM, NC 27701
E: 919.419.1199
C: 919.419.1669
WWW.SURFACE678.COM
FNSF.# C-098

HEATHAM & ASSOCIATES, PA
PROTECTION ENGINEER
2 ENTERPRISE DRIVE
WINSTON, NC 28405
E: 910.452.4210
WWW.HEATHAMP.A.COM
ENSE # C-1073

PALACIO COLLABORATIVE
 COST ESTIMATOR
 19 EMPEROR BOULEVARD SUITE 400
 RICHAM, NC 27703
 P: 919.605.8952
 WWW.PALACIOCOLLABORATIVE.COM

NOTE: IF THIS DRAWING IS NOT 30" X 42", IT IS A
REDUCED PRINT. REFER TO GRAPHIC SCALE.

NOT FOR
CONSTRUCTION

**NOT FOR
CONSTRUCTION**


NO.	DATE	DESCRIPTION
1	9-8-25	BID SET

THIRD FLOOR PLAN -
SHARK TANK - DOMESTIC
WATER


PW2.23 B

FLOOR PLAN SHEET NOTES

1. PLUMBING CONTRACTOR TO COORDINATE WITH OTHER TRADES PRIOR TO BEGINNING WORK.
2. REFER TO ARCHITECTURAL DRAWINGS FOR RATED ASSEMBLY UL NUMBERS (WALLS, FLOOR / CEILING, ETC.)
3. DRAWINGS: DRAWINGS ARE DIAGRAMMATIC AND MAY NOT COMPLETELY DESCRIBE EVERY DETAIL OF THE INSTALLATION. HOWEVER, CONTRACTOR IS RESPONSIBLE FOR THE PROTECTION OF ALL SYSTEMS INCLUDING ALL REQUIRED EQUIPMENT AND ACCESSORIES TO OBTAIN FULLY FUNCTIONING PLUMBING SYSTEMS.
4. EQUIPMENT LOCATIONS: DETERMINE EXACT EQUIPMENT AND MATERIALS LOCATIONS TO PROVIDE BEST ARRANGEMENT AND TO FACILITATE PROPER MAINTENANCE AND SERVICING OF EQUIPMENT.
5. LISTING AND LABELING: ALL EQUIPMENT SHALL BE LABELED OR LISTED BY UL OR OTHER APPROVED TESTING AGENCY WHERE REQUIRED.

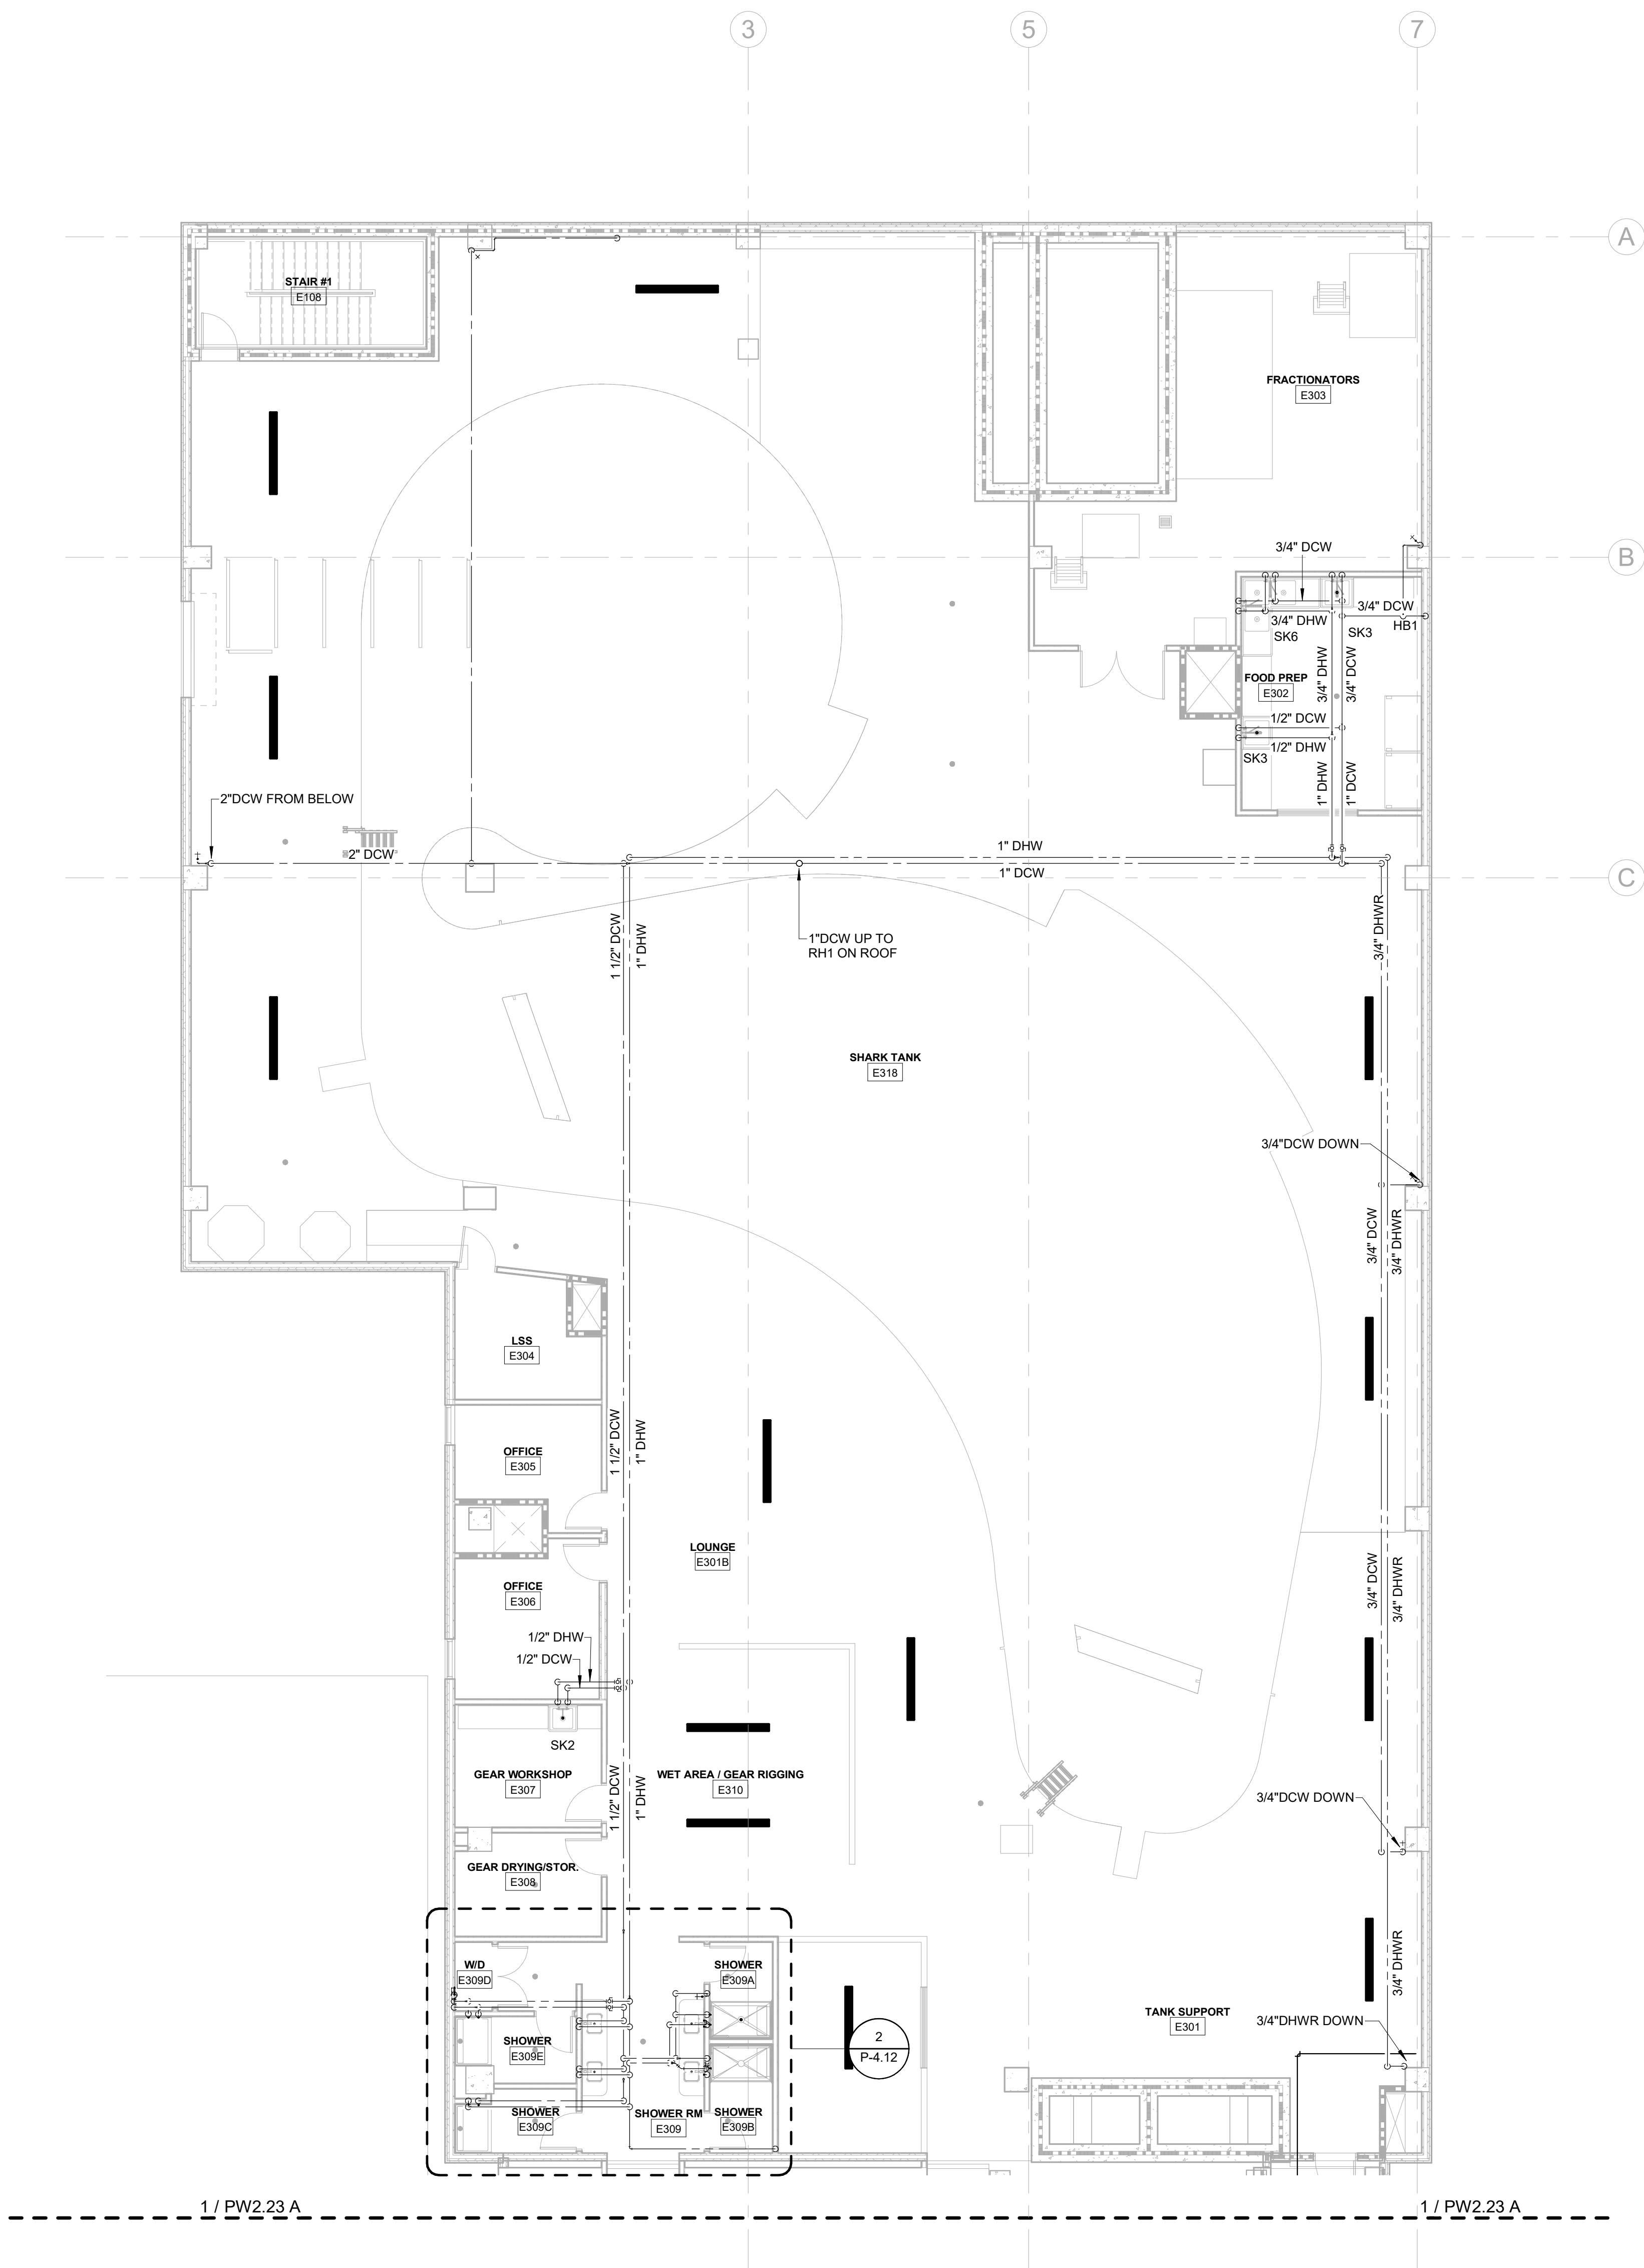


KEY PLAIN

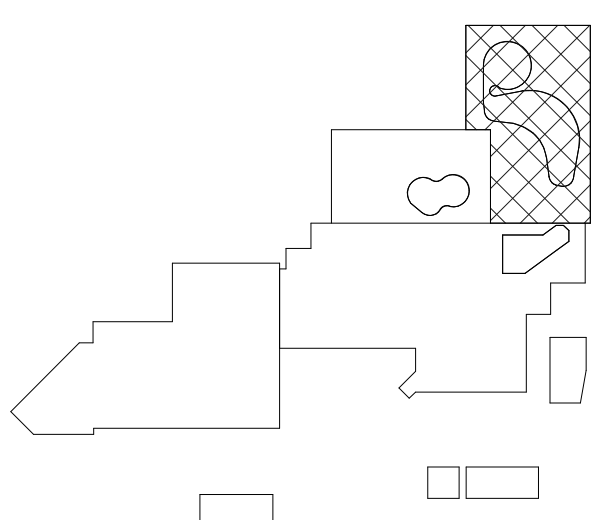

CBHF
Engineers, PLLC

2246 Yaupon Drive
Wilmington, NC 28401
Phone: 910.791.4000
Fax: 910.791.5266
www.cbhfengineers.com
Copyright 2025 CBHF Engineers, PLLC NC# P-0506

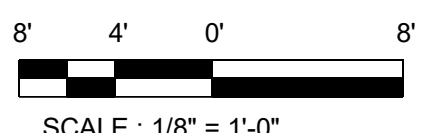

TANK - DOMESTIC WATER

1

KEYNOTES THIS SHEET	
1	INSTALL SHUTOFF VALVE IN WALL WITH WALL MOUNTED ACCESS HATCH
2	HAMMER ARRESTOR, P.D.1, SIZE "D"
3	<varies>
4	2-1/2" DCW FROM BELOW
5	HAMMER ARRESTOR, P.D.1, SIZE "B"
6	INSTALL BRANCH VALVE ABOVE CEILING
7	TRAP PRIMER VALVE

SZOSTAK DESIGN

FORT FISHER
AQUARIUM
RENOVATION
& EXPANSION:
PHASE 1

SCO #17-18042-02A
CODE: 42014-4G02
ITEM: 41414-4Y4A

900 LOGGERHEAD RD,
KURE BEACH, NC 28449

NORTH CAROLINA DEPT. OF
NATURAL & CULTURAL RESOURCES

SZOSTAK DESIGN, INC.

ARCHITECT
310 1/2 WEST FRANKLIN STREET
CHAPEL HILL, NORTH CAROLINA 27514
TEL: 919.929.3244
FAX: 919.960.7967
WWW.SZOSTAKDESIGN.COM
LICENSE # 31079

TJP ENGINEERING, INC.

LIFE SUPPORT SYSTEMS ENGINEER
5680 VENTURE LANE SUITE 205N
BEND, OR 97001
TEL: 414.423.0300
WWW.TJPEENGINEERING.COM
LICENSE # C-3505

ROTO GROUP, LLC.

EXHIBIT DESIGNER
7001 DISCOVERY BOULEVARD
DURHAM, NC 27705
TEL: 817.760.6895
WWW.ROTO.COM

BENNETT & PLESS

STRUCTURAL ENGINEER
5430 WADE PARK BOULEVARD SUITE 400
RALEIGH, NC 27607
TEL: 919.832.5587
WWW.BENNETT-PLESS.COM
LICENSE # F-1105

CBHF ENGINEERS, PLLC

MFP ENGINEER
2246 YAUPON DRIVE
WILMINGTON, NC 28401
TEL: 910.791.4000
FAX: 910.791.5266
WWW.CBHFENGINEERS.COM
LICENSE # F-6564

LIGHTSWITCH

LIGHTING DESIGNER
10665 INDIANA COURT
RANCHO CUCAMONGA, CA 91730
TEL: 909.360.7000
WWW.LIGHTSWITCH.NET

TUNSTALL CONSULTING ENGINEERS PLLC

CIVIL ENGINEER
2402 BROWN GATE DRIVE SUITE 102
WILMINGTON, NC 28412
TEL: 910.343.4523
FAX: 910.343.5904
WWW.TUNSTALLENGINEERS.COM
LICENSE # F-3132

SURFACE 678, PA

LANDSCAPE ARCHITECT
215 MOORE STREET SUITE 150
DURHAM, NC 27701
TEL: 919.419.1199
FAX: 919.419.1689
WWW.SURFACE678.COM
LICENSE # C-108

CHEATHAM & ASSOCIATES, PA

RRE PROTECTION ENGINEER
3412 EMBERSIDE DRIVE
WILMINGTON, NC 28405
TEL: 910.452.8110
WWW.CHEATHAMP.A.COM
LICENSE # C-1073

PALACIO COLLABORATIVE

COST ESTIMATOR
4817 EMBERSIDE BOULEVARD SUITE 400
DURHAM, NC 27705
TEL: 919.452.8110
WWW.PALACIOCOLLABORATIVE.COM

NOTE: IF THIS DRAWING IS NOT 30" X 42", IT IS A
REDUCED PRINT. REFER TO GRAPHIC SCALE.

NOT FOR
CONSTRUCTION

SEAL
23551
ENGINEER
DAVID M. HARRIS

NOT FOR
CONSTRUCTION

NO.	DATE	DESCRIPTION
1	9-8-25	BID SET


ENLARGED PLANS

P-4.11

CBHF
Engineers, PLLC


2246 Yaupon Drive
Wilmington, NC 28401
Phone: 910.791.4000
Fax: 910.791.5266
www.cbhfindesign.com

© Copyright 2025 CBHF Engineers, PLLC. NCIA P-0306

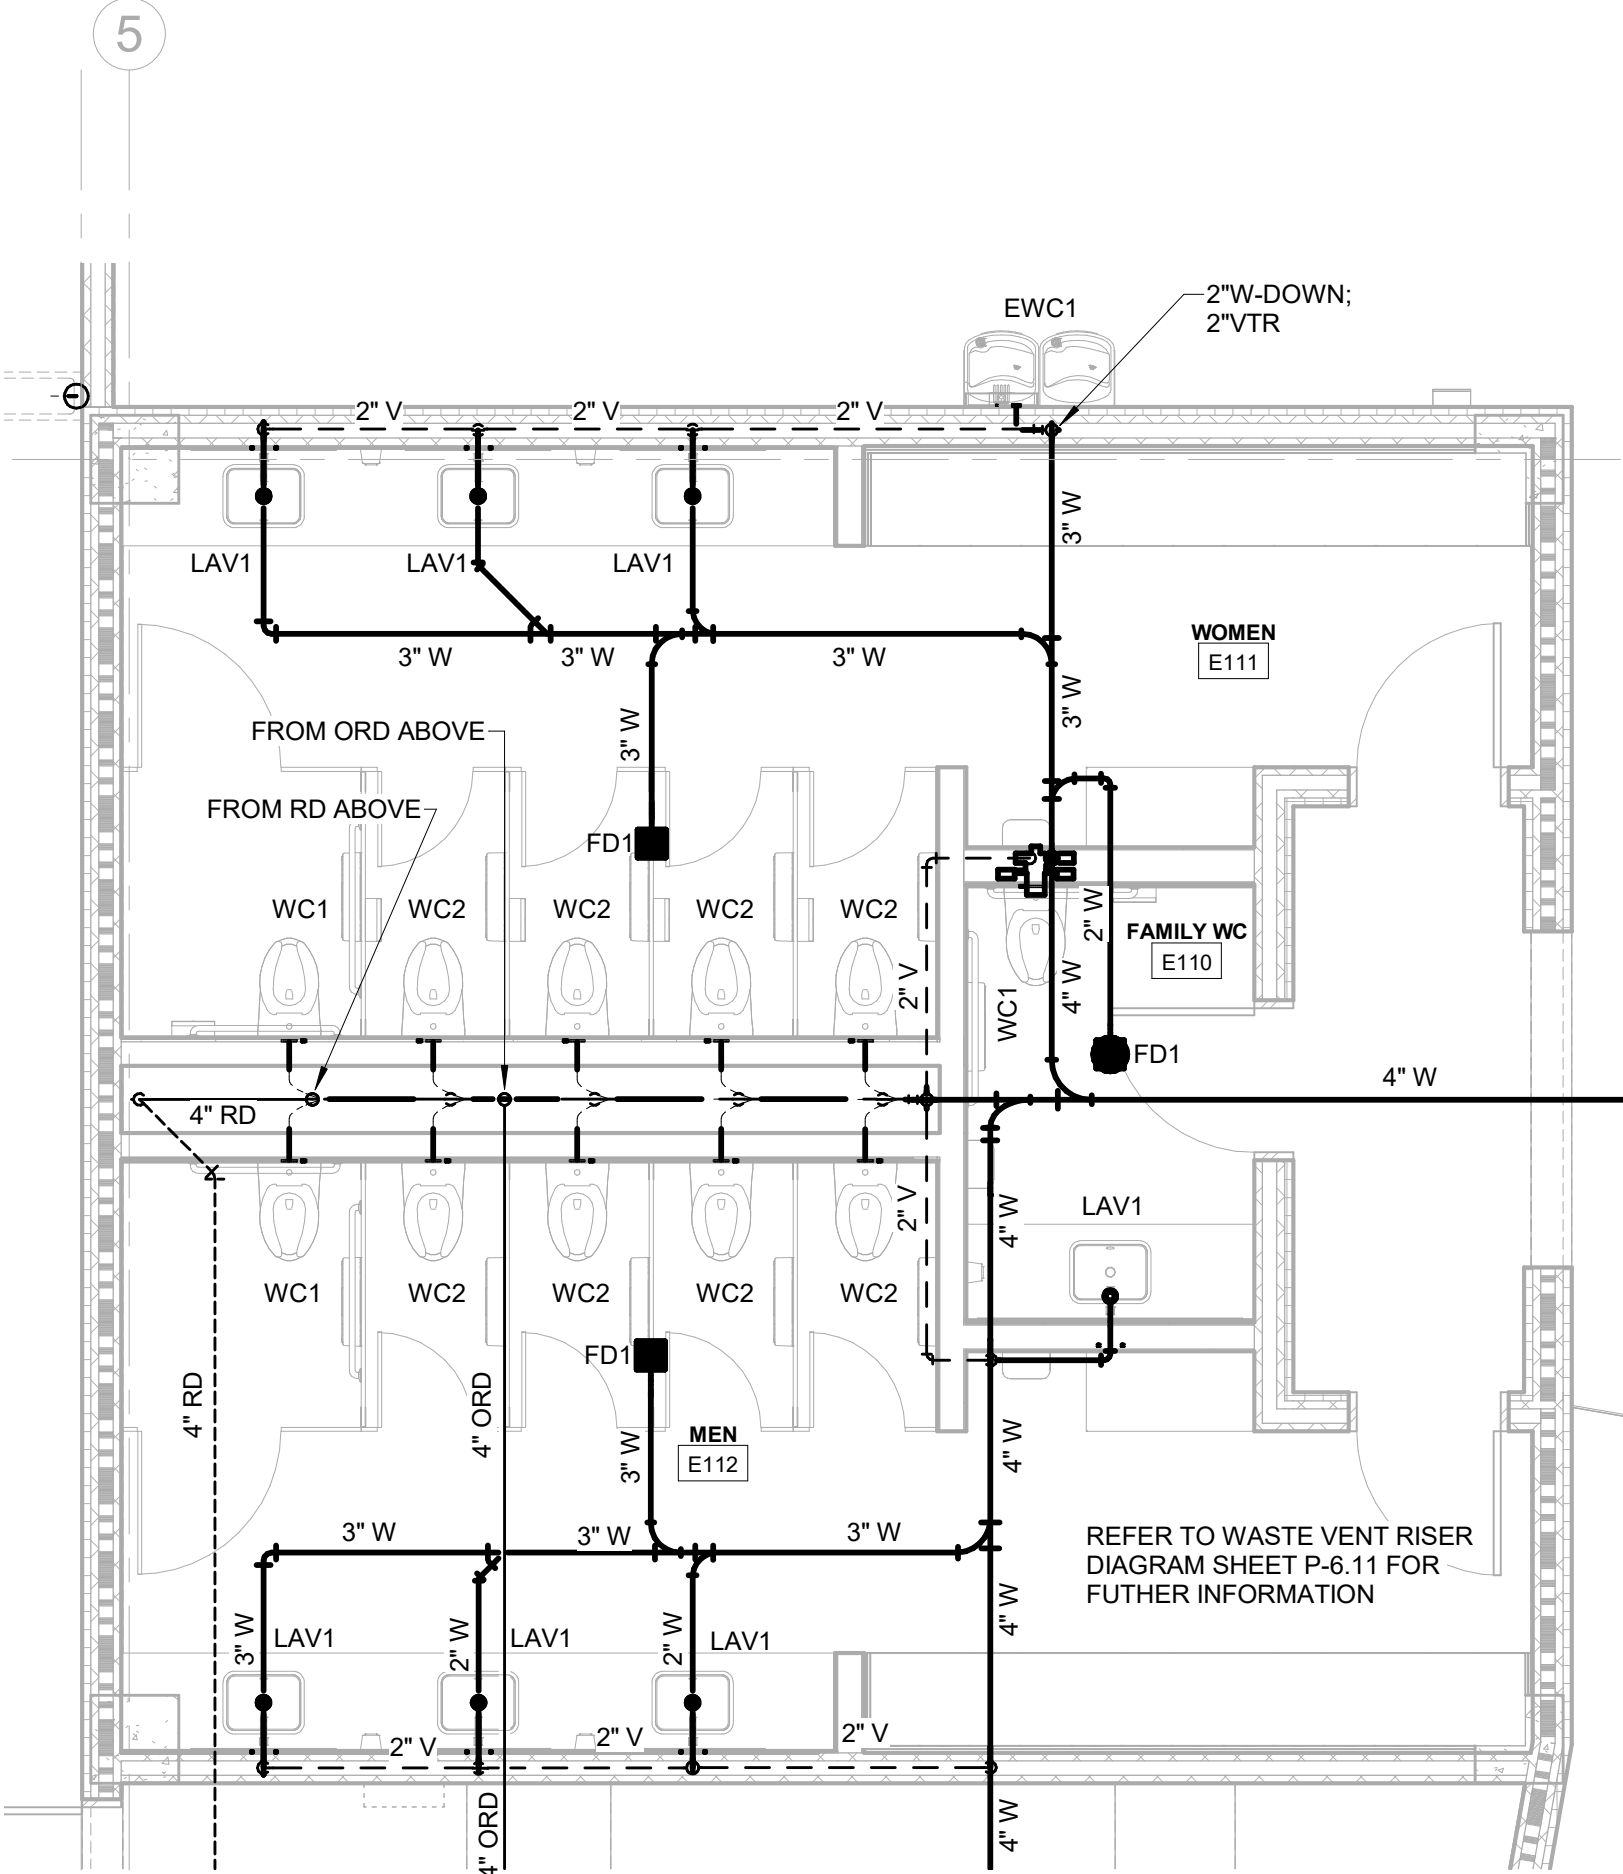


TOILETS E111/E112 ENLARGED WASTE-VENT PLAN
SCALE: 1/4" = 1'-0"

1

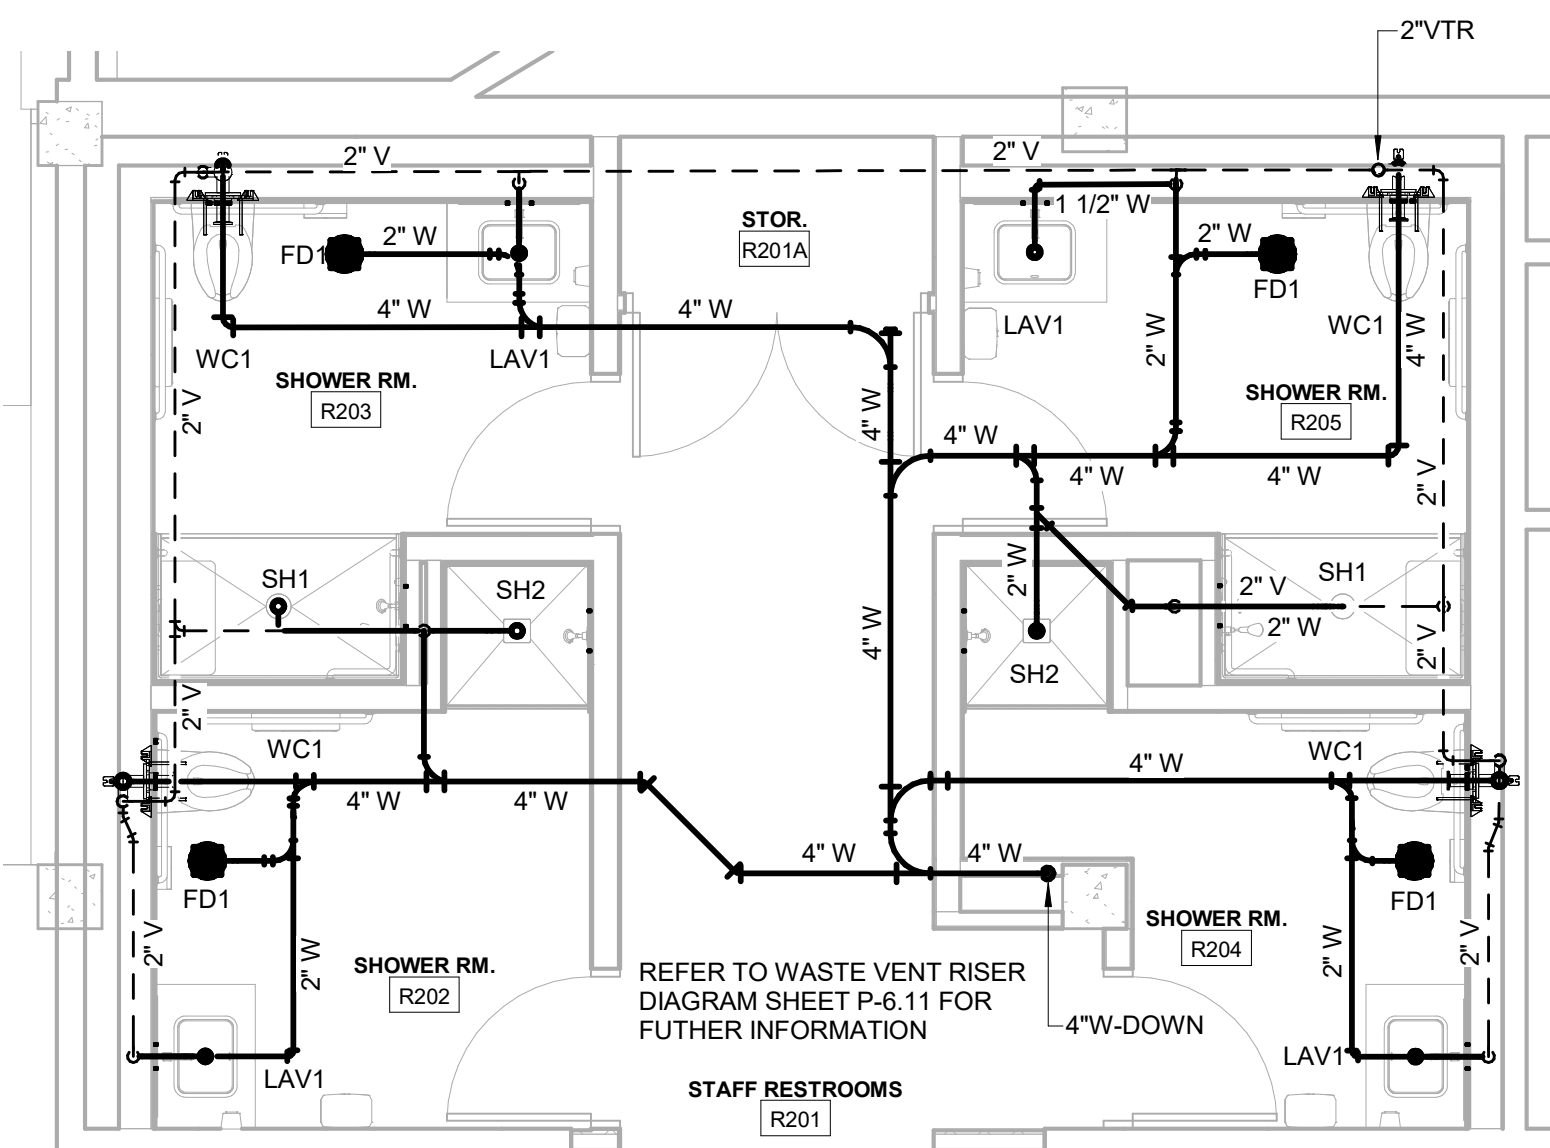


TOILETS R201 ENLARGED WASTE-VENT PLAN
SCALE: 1/4" = 1'-0"

2

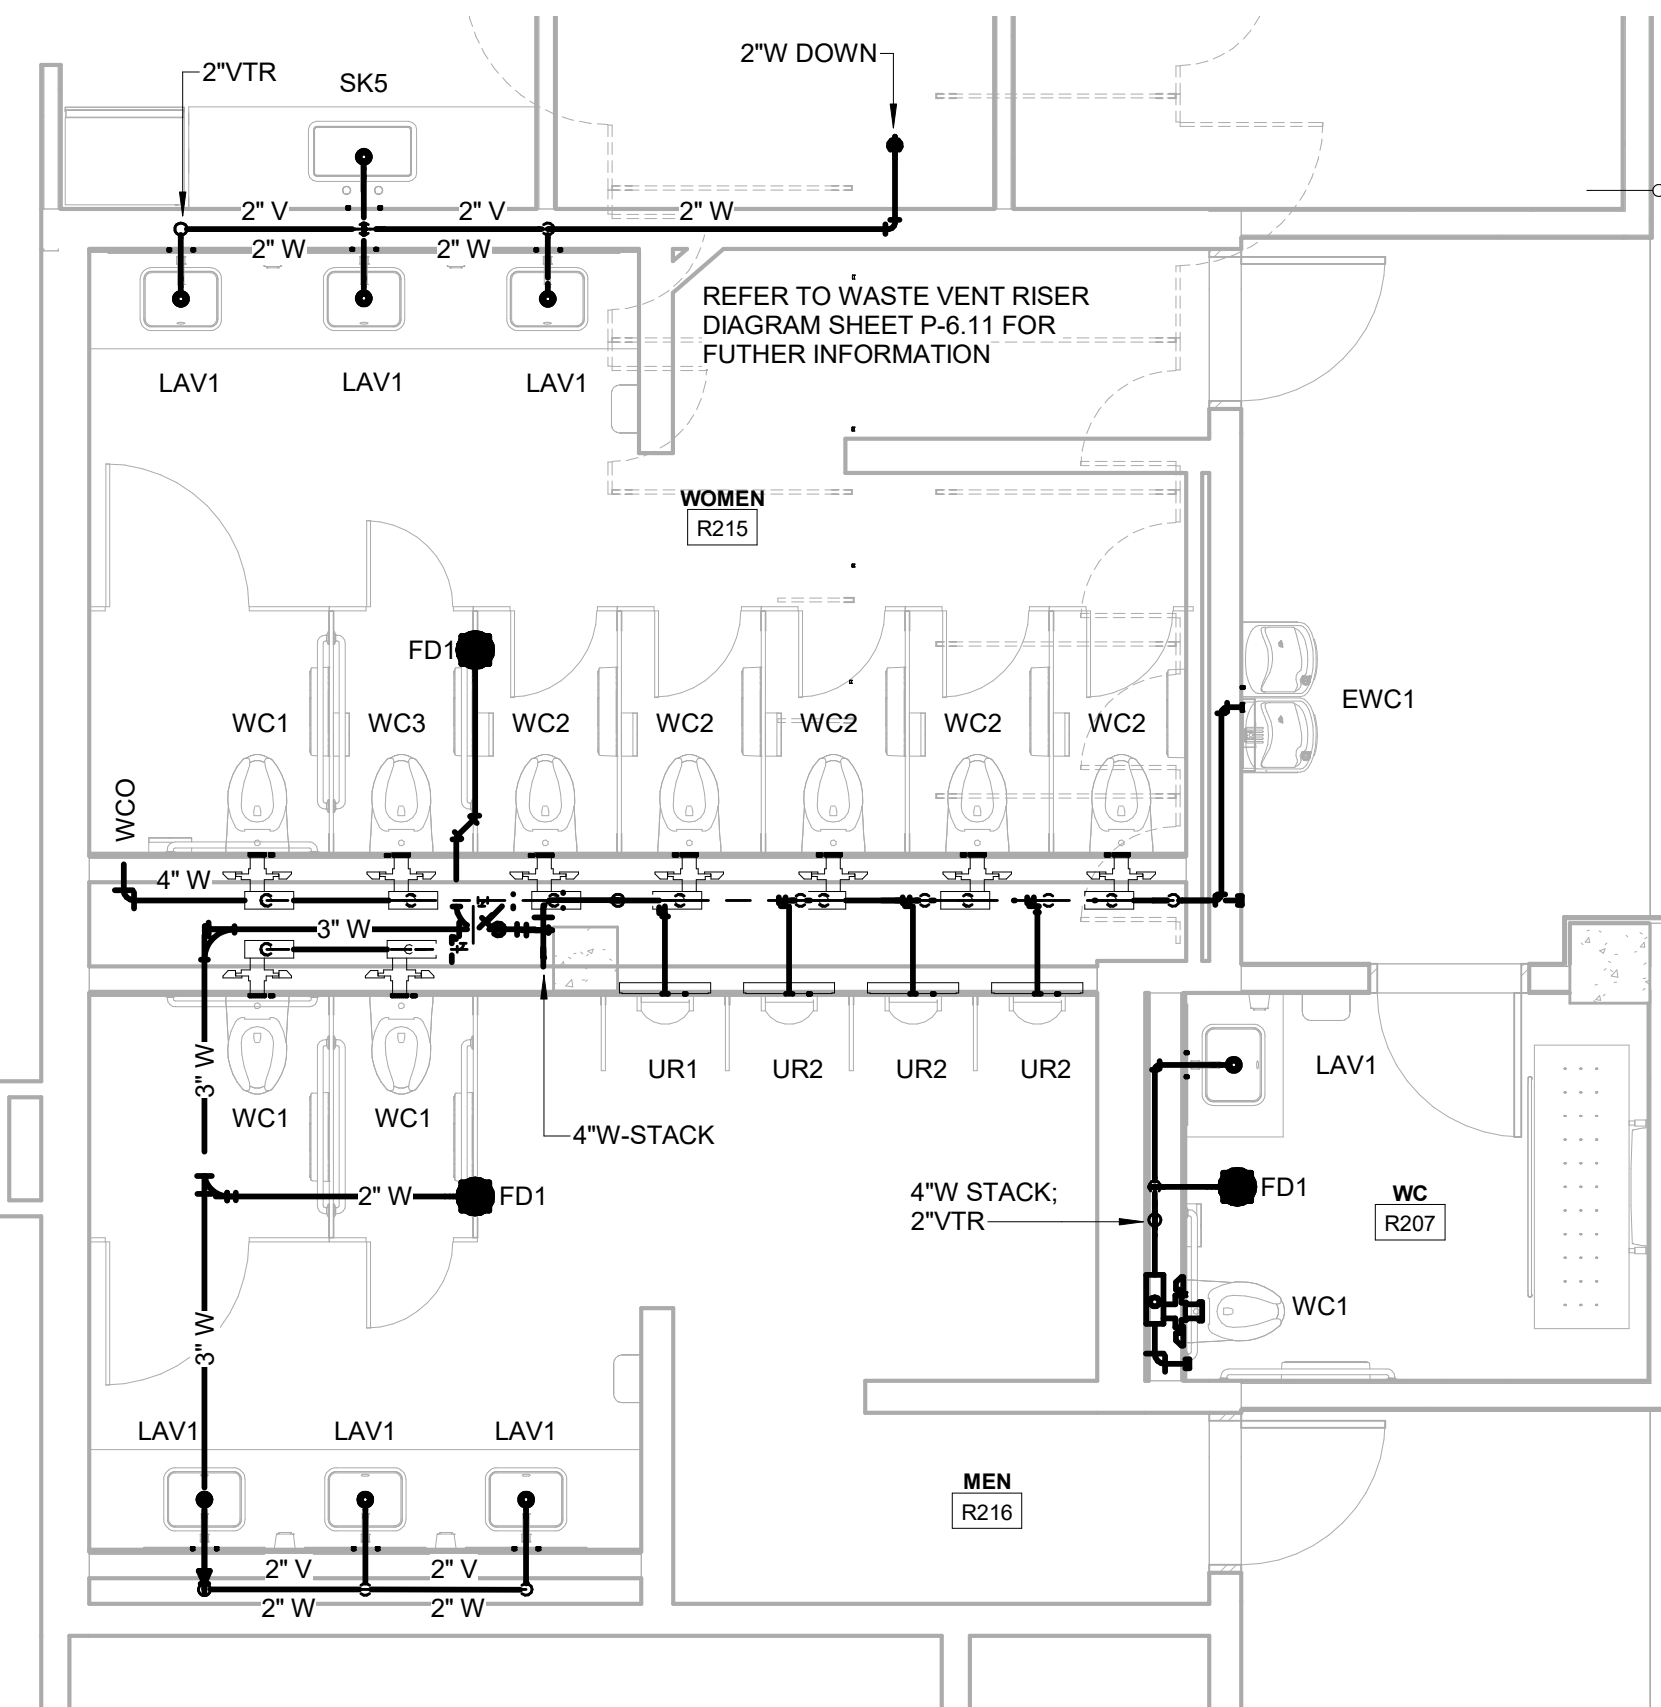


TOILETS R215-R216 ENLARGED WASTE-VENT PLAN
SCALE: 1/4" = 1'-0"

3

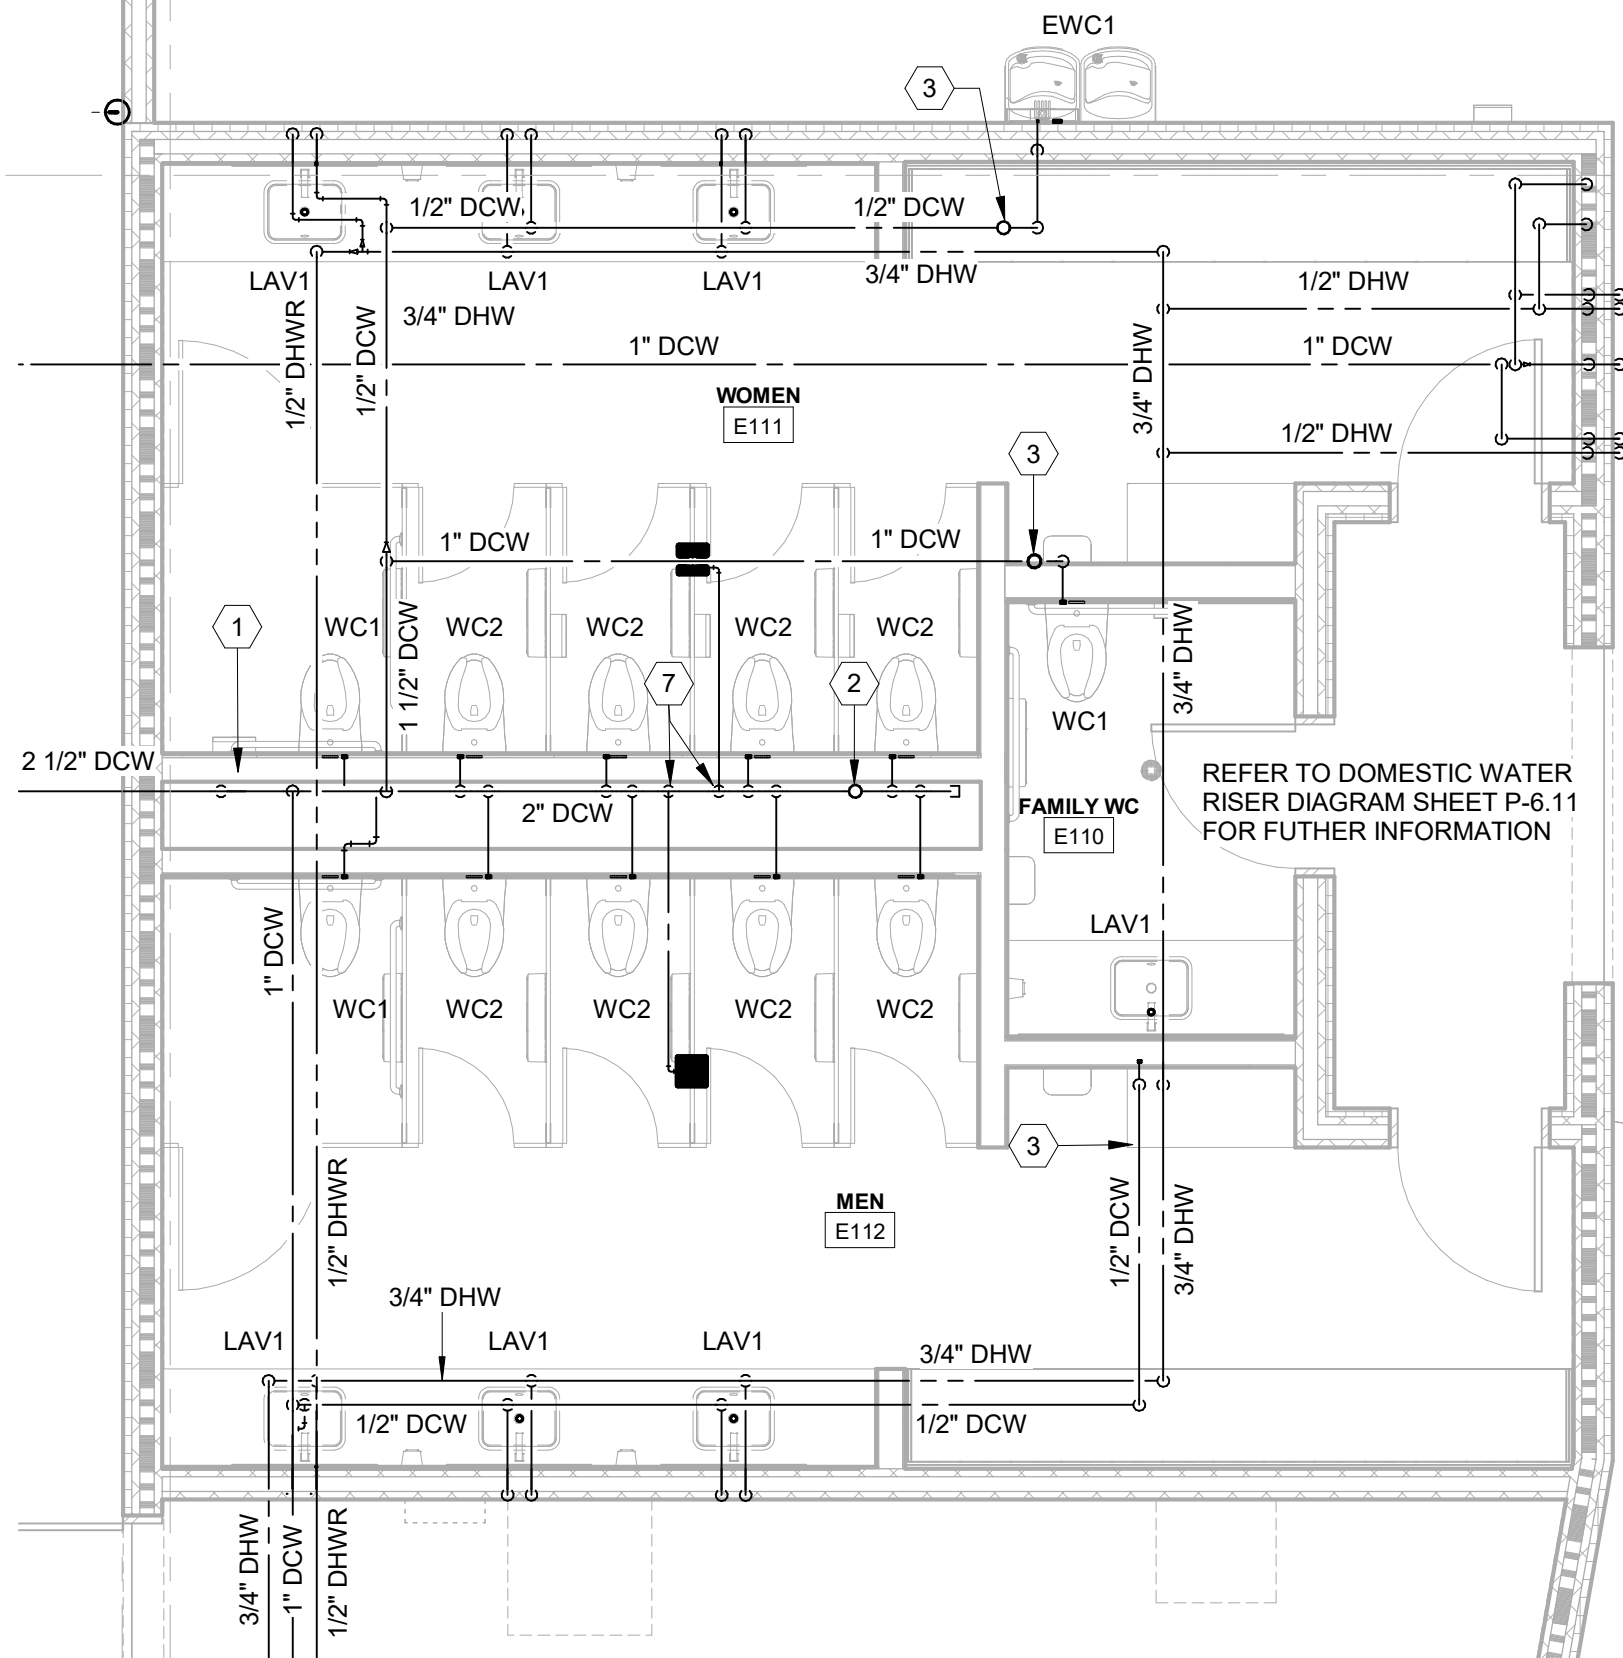


TOILETS E111/E112 ENLARGED DOMESTIC WATER PLAN
SCALE: 1/4" = 1'-0"

4

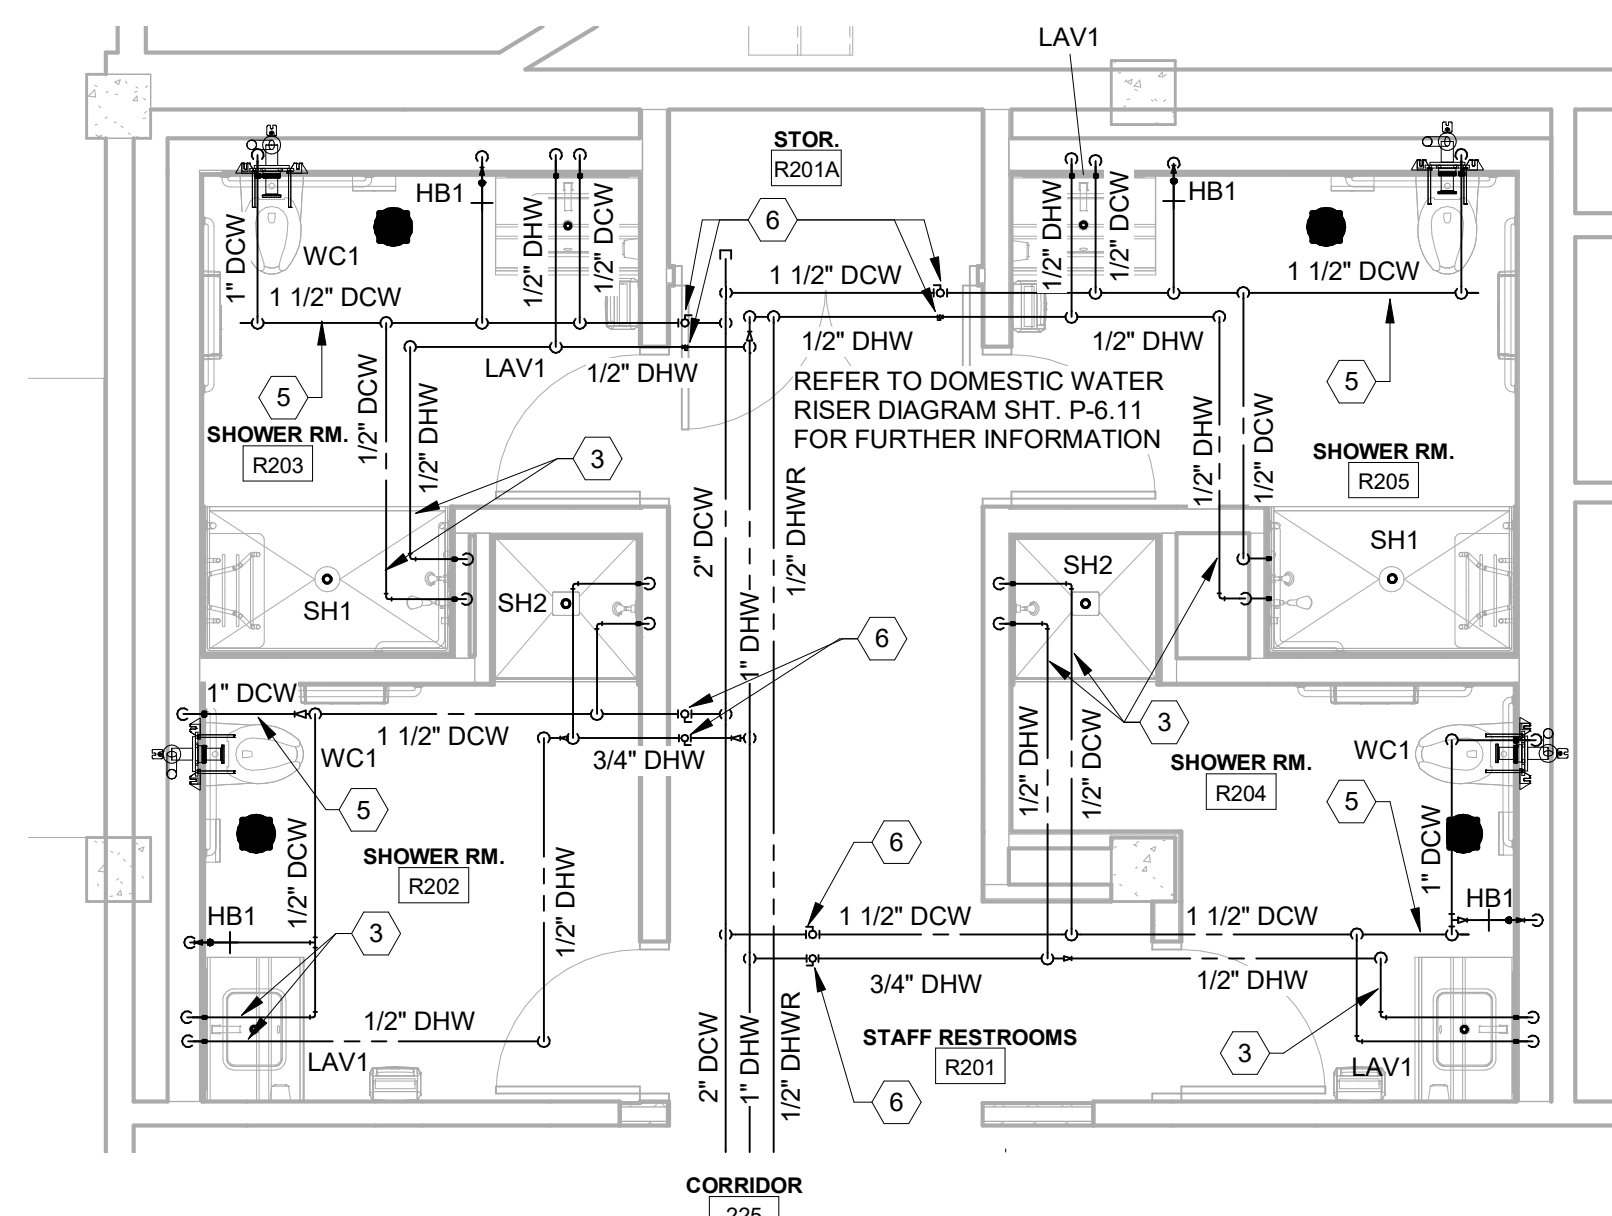


STAFF TOILETS R201 ENLARGED DOMESTIC WATER PLAN
SCALE: 1/4" = 1'-0"

5

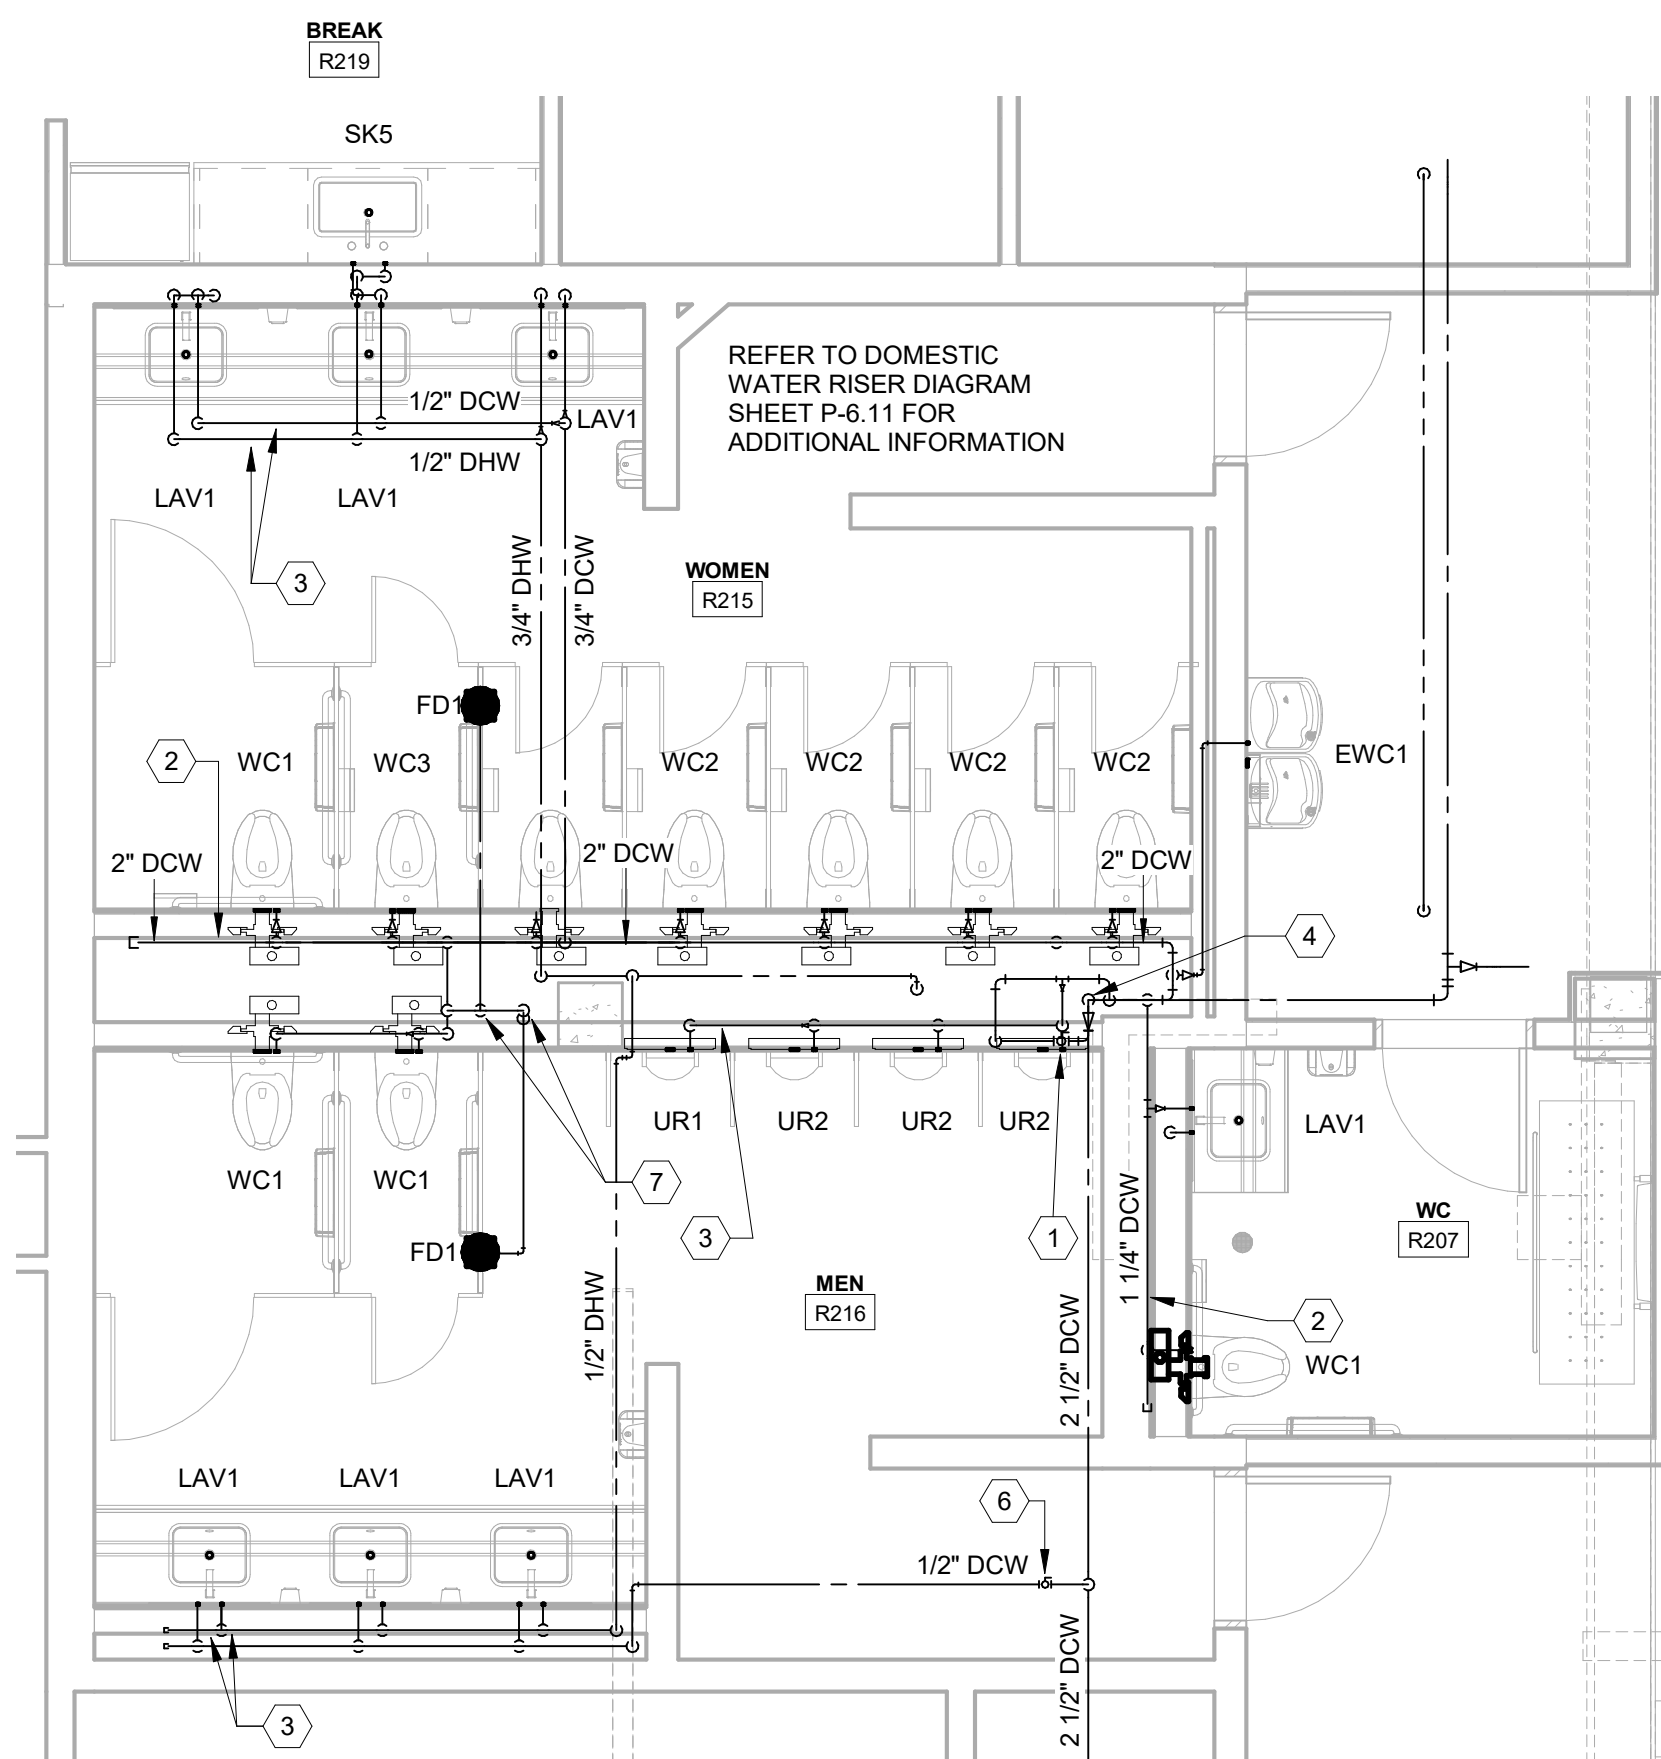

TOILETS R215-216 ENLARGED DOMESTIC WATER PLAN
SCALE: 1/4" = 1'-0"


6

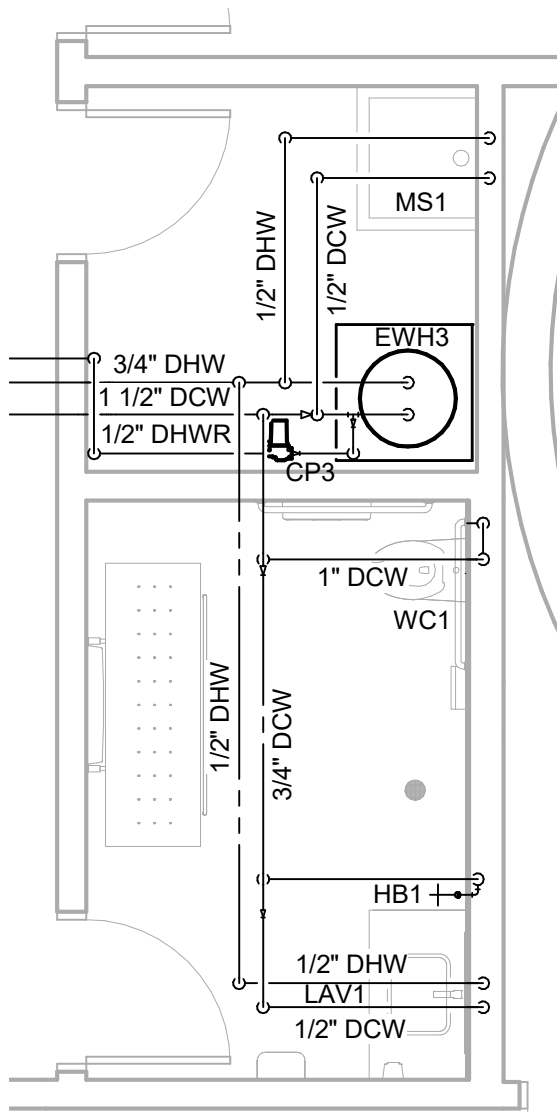


TOILET R112 ENLARGED DOMESTIC WATER PLAN
SCALE: 1/4" = 1'-0"

7

 P-5.11



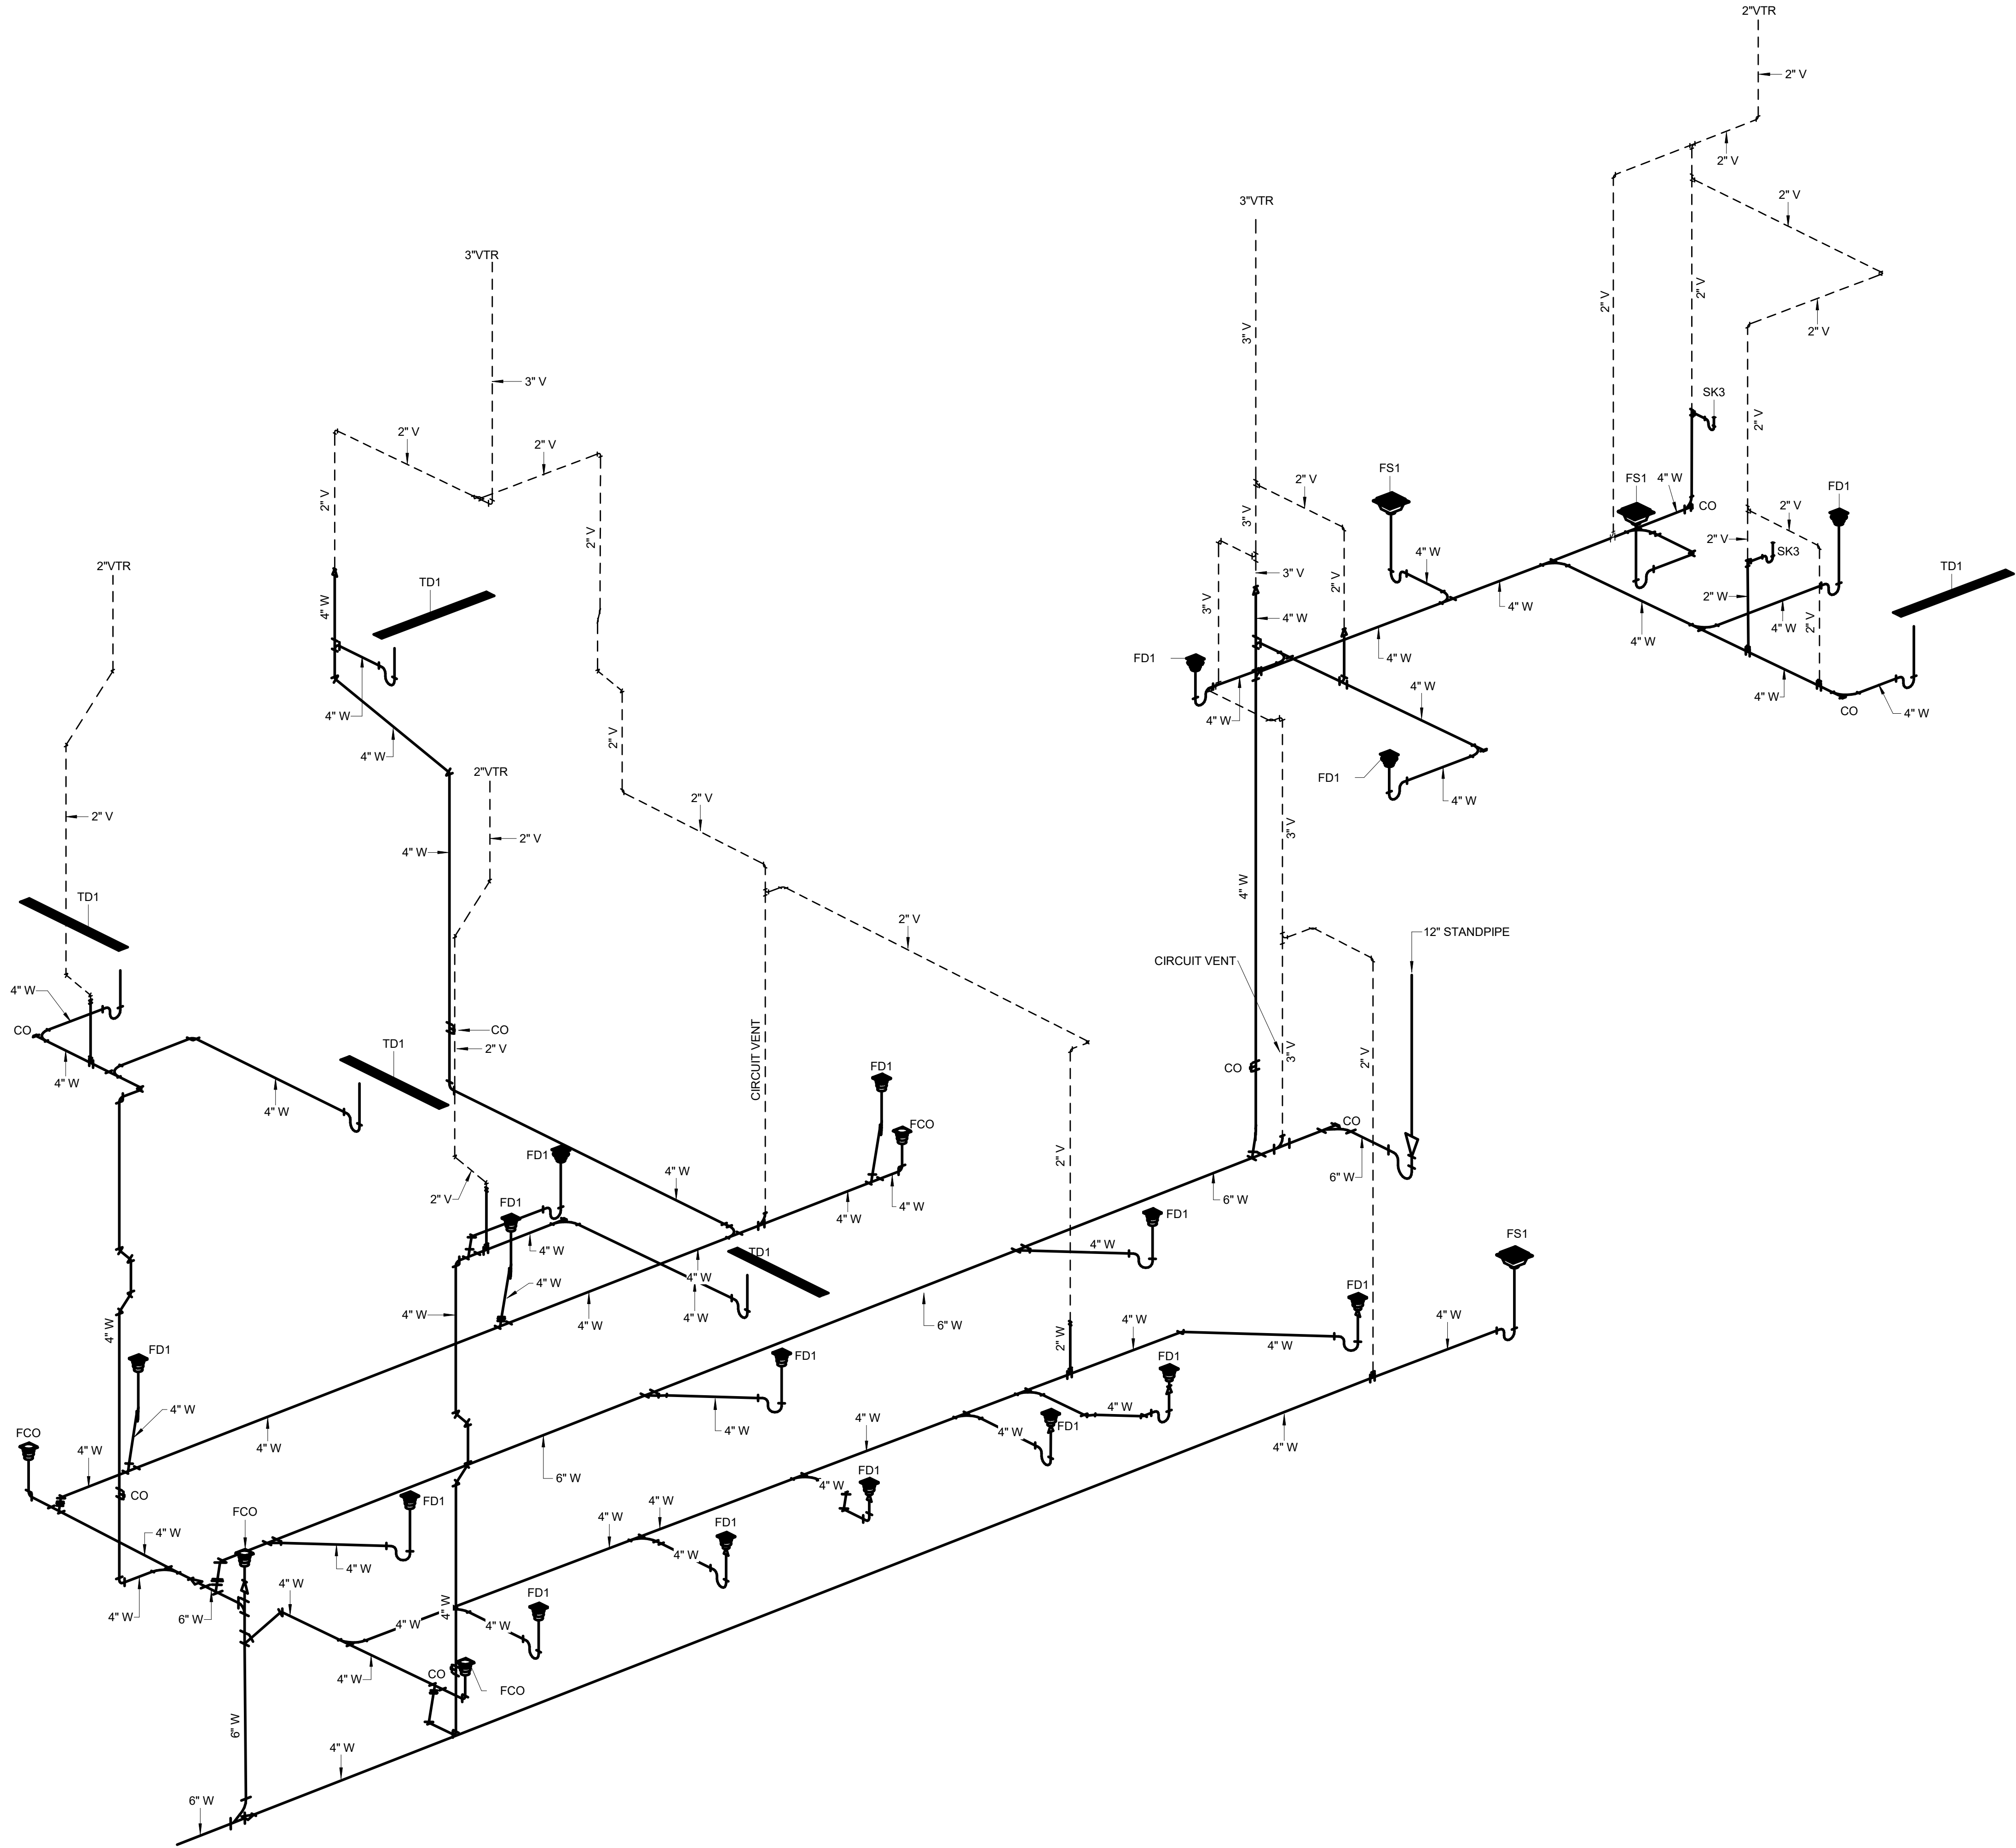


SHARK TANK WASTE-VENT RISER DIAGRAM
SCALE : NO SCALE

1

TOILET R112 WASTE-VENT RISER DIAGRAM
SCALE : NO SCALE

2

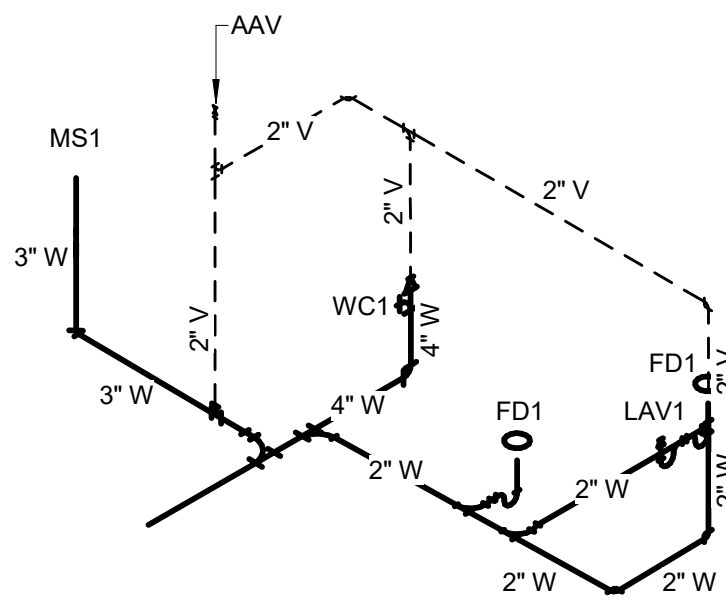

SZOSTAK DESIGN

FORT FISHER
AQUARIUM
RENOVATION
& EXPANSION:
PHASE I

SCO #17-18042-02A
CODE: 42014-4G02
ITEM: 41414-4Y4A

900 LOGGERHEAD RD,
KURE BEACH, NC 28449

NORTH CAROLINA DEPT. OF
NATURAL & CULTURAL RESOURCES

SZOSTAK DESIGN, INC.

ARCHITECT
310 1/2 WEST FRANKLIN STREET
CHAPEL HILL, NORTH CAROLINA 27514
TEL: 919.929.5244
FAX: 919.960.7967
WWW.SZOSTAKDESIGN.COM
LICENSE # 31079

TJP ENGINEERING, INC.

LIFE SUPPORT SYSTEMS ENGINEER
5680 VENTURE LAKE SUITE 205H
BEND, OR 97707
TEL: 414.423.0300
WWW.TJPEENGINEERING.COM
LICENSE # C-3505

ROTO GROUP, LLC.

EXHIBIT DESIGNER
7001 DISCOVERY BOULEVARD
DUBLIN, OHIO 43017
TEL: 617.760.6895
WWW.ROTO.COM

BENNETT & PLESS

STRUCTURAL ENGINEER
5430 WADE PARK BOULEVARD SUITE 400
RALEIGH, NC 27607
TEL: 919.832.5587
WWW.BENNETT-PLESS.COM
LICENSE # F-1105

CBHF ENGINEERS, PLLC

MFP ENGINEER
2246 YAUPOIN DRIVE
WILMINGTON, NC 28401
TEL: 910.791.4000
FAX: 910.791.5266
WWW.CBHFENGINEERS.COM
LICENSE # F-6554

LIGHTSWITCH

LIGHTING DESIGNER
10365 INDIANA COURT
RANCHO CUCAMONGA, CA 91730
TEL: 909.360.0000
WWW.LIGHTSWITCH.NET

TUNSTALL CONSULTING ENGINEERS PLLC

CIVIL ENGINEER
2402 IRON GATE DRIVE SUITE 102
WILMINGTON, NC 28412
TEL: 910.343.9423
FAX: 910.343.9404
WWW.TUNSTALLENGINEERS.COM
LICENSE # F-3132

SURFACE 678, PA

LANDSCAPE ARCHITECT
215 AGERS STREET SUITE 150
DURHAM, NC 27703
TEL: 919.419.1199
FAX: 919.419.1689
WWW.SURFACE678.COM
LICENSE # C-096

CHEATHAM & ASSOCIATES, PA

FIRE PROTECTION ENGINEER
3412 ENTERPRISE DRIVE
WILMINGTON, NC 28405
TEL: 910.452.6110
WWW.CHEATHAMPA.COM
LICENSE # C-1073

PALACIO COLLABORATIVE

COST ESTIMATOR
4817 ENTERPRISE BOULEVARD SUITE 400
DURHAM, NC 27703
TEL: 919.453.9100
WWW.PALACIOCOLLABORATIVE.COM

NOTE: IF THIS DRAWING IS NOT 30" X 42", IT IS A
REDUCED PRINT. REFER TO GRAPHIC SCALE.

NOT FOR
CONSTRUCTION

SEAL
23551
ENGINEER
DAVID M. HARR

NOT FOR
CONSTRUCTION

NO. DATE DESCRIPTION

1 9-8-25 BID SET

PLUMBING RISER
DIAGRAMS

P-6.12

FORT FISHER
AQUARIUM
RENOVATION
& EXPANSION:
PHASE 1

CO #17-18042-02A
CODE: 42014-4G02
ITEM: 41414-4Y4A

900 LOGGERHEAD RD.
JURE BEACH, NC 28449

NORTH CAROLINA DEPT. OF
NATURAL & CULTURAL RESOURCES

SZOSTAK DESIGN, INC.

ARCHITECT
310 1/2 WEST FRANKLIN STREET
CHAPEL HILL, NORTH CAROLINA 27516
TEL: 919.929.5244
FAX: 919.960.7967
WWW.SZOSTAKDESIGN.COM
LICENSE # 51679

TJP ENGINEERING, INC.

LIFE SUPPORT SYSTEMS ENGINEER
56880 VENTURE LANE SUITE 205N
BEND, OR 97707
TELE: 619.423.8700
WWW.TJENGINEERING.COM
LICENSE # C-3505

ROTO GROUP, LLC

EXHIBIT DESIGNER
7001 DISCOVERY BOULEVARD
DUBLIN, OHIO 43017
TELE: 617.760.8690
WWW.ROTO.COM

BENNETT & PLESS

STRUCTURAL ENGINEER
5430 WADE PARK BOULEVARD SUITE 400
RALEIGH, NC 27607
TELE: 919.832.5587
WWW.BENNETT-FLESS.COM
LICENSE # F-1105

CBHF ENGINEERS, PLLC

MEP ENGINEER
2246 YALPON DRIVE
WILMINGTON, NC 28401
TELE: 910.791.4000
FAX: 910.791.5266
WWW.CBHIENGINEERS.COM

LIGHTSWITCH

LIGHTING DESIGNER
10265 INDIANA COURT
RANCHO CUCAMONGA, CA 91730
TELE: 909.360.2900
WWW.LIGHTSWITCH.NET

TUNSTALL CONSULTING ENGINEERS PLLC

CIVIL ENGINEER
2602 IRON GATE DRIVE SUITE 102
WILMINGTON, NC 28412
TELE: 910.343.9653
FAX: 910.343.9604
WWW.JTENGINEERS.COM
LICENSE # P-3152

SURFACE 678, PA

LANDSCAPE ARCHITECT
215 MORRIS STREET SUITE 1
DURHAM, NC 27701
TELE: 919.419.1199
FAX: 919.419.1669
WWW.SURFACE678.COM
LICENSE # C-098

CHEATHAM & ASSOCIATES, P.A.

FIRE PROTECTION ENGINEER
3412 ENTERPRISE DRIVE
WILMINGTON, NC 28405
TELE: 910.452.4210
WWW.CHEATHAMPA.COM
LICENSE # C-1073

PALACIO COLLABORATIVE

COST ESTIMATOR
4819 EMPEROR BOULEVARD SUITE 400
DURHAM, NC 27703
TELE: 919.605.8952
WWW.PALACIOCOLLABORATIVE.COM

NOTE: IF THIS DRAWING IS NOT 30" X 42", IT IS A REDUCED PRINT. REFER TO GRAPHIC SCALE.

NOT FOR
CONSTRUCTION


SEAL
23551
ENGINEER
DAVID M. HAHN

**NOT FOR
CONSTRUCTION**

NO.	DATE	DESCRIPTION
1	9-8-25	BID SET

PLUMBING RISER DIAGRAMS

P-6.13

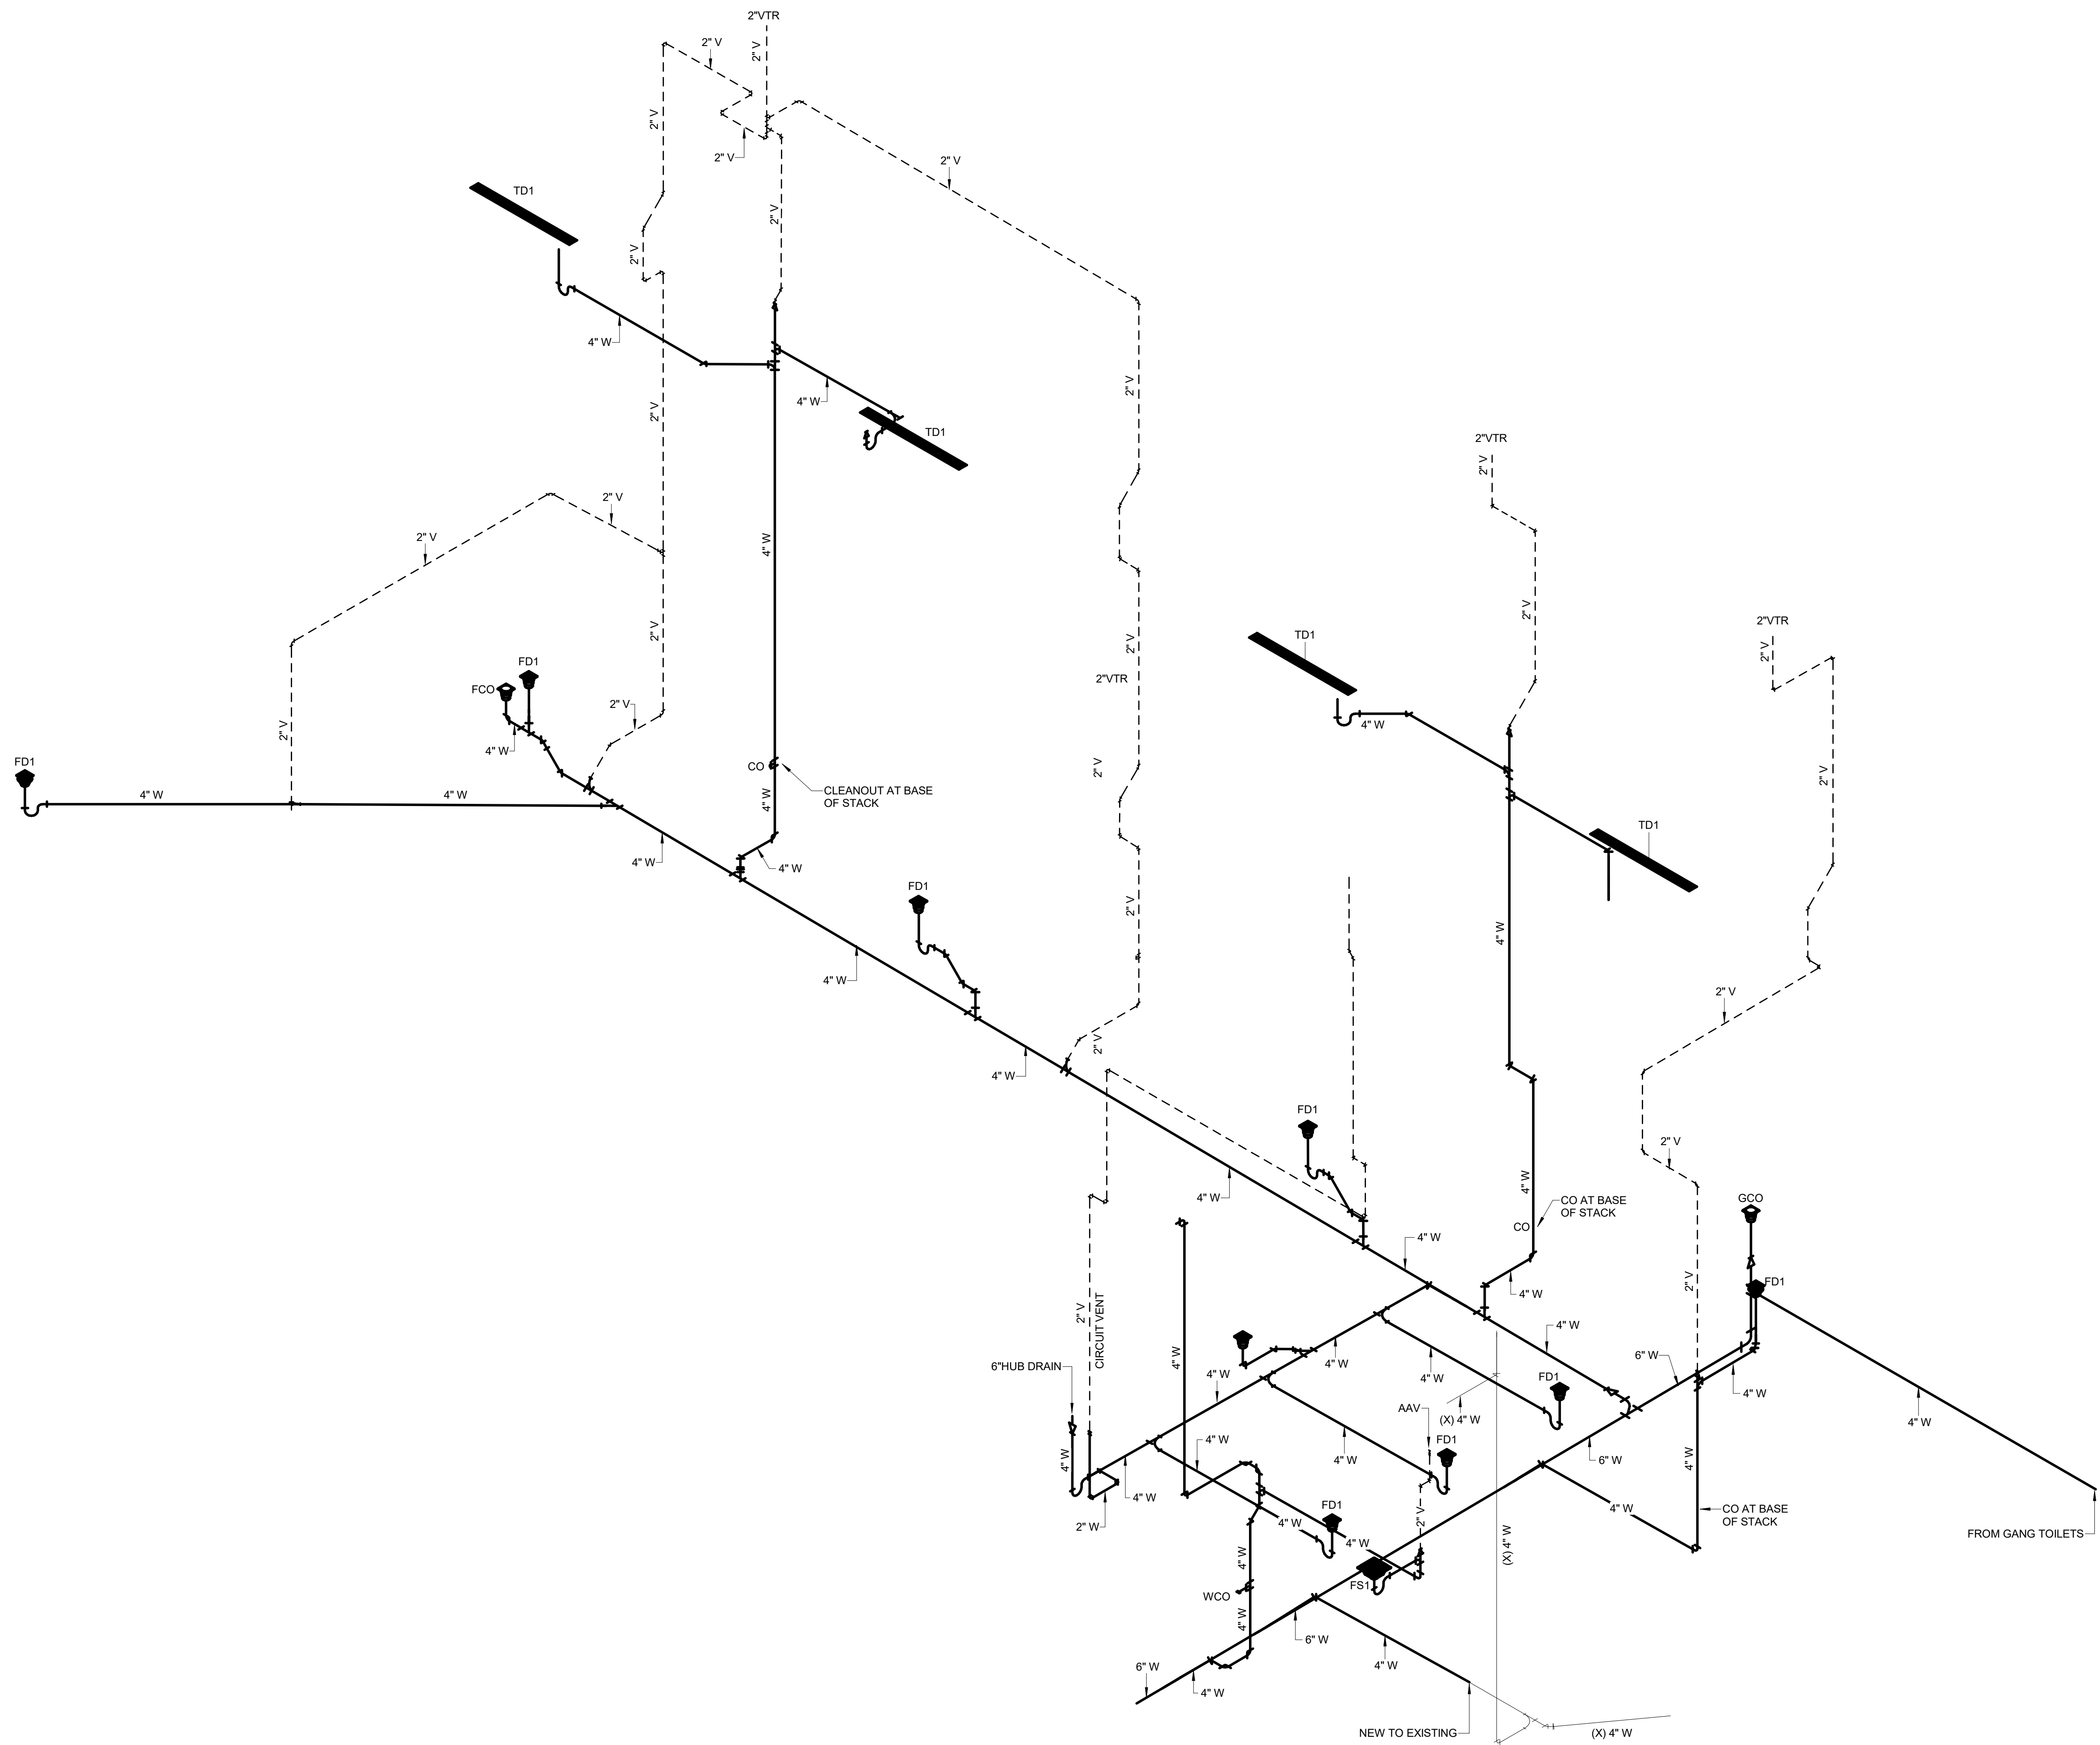

CBHF
Engineers, PLLC

2246 Yaupon Drive
Wilmington, NC 28401
Phone: 910.791.4000
Fax: 910.791.5266
www.cbhfengineers.com
Copyright 2025 CBHF Engineers, PLLC NC# P-05

© Copyright 2025 CBHF Engineers, PLLC NC# P-0506

EAST SHARK TANK WASTE VENT RISER DIAGRAM

SCALE : NO SCALE

FORT FISHER
AQUARIUM
RENOVATION
& EXPANSION:
PHASE 1

CO #17-18042-02A
CODE: 42014-4G02
ITEM: 41414-4Y4A

900 LOGGERHEAD RD.
JURE BEACH, NC 28449

NORTH CAROLINA DEPT. OF
NATURAL & CULTURAL RESOURCES

SZOSTAK DESIGN, INC.

ARCHITECT
310 1/2 WEST FRANKLIN STREET
CHAPEL HILL, NORTH CAROLINA 27516
TEL: 919.929.5244
FAX: 919.960.7967
WWW.S2CSTAKDESIGN.COM
LICENSE # 51679

TJP ENGINEERING, INC

LIFE SUPPORT SYSTEMS ENGINEER
56880 VENTURE LANE SUITE 205N
BEND, OR 97707
TELE: 619.423.8700
WWW.TJENGINEERING.COM
LICENSE # C-3505

ROTO GROUP, LLC.

EXHIBIT DESIGNER
7001 DISCOVERY BOULEVARD
DUBLIN, OHIO 43017
TELE: 617.760.8690
WWW.ROFO.COM

BENNETT & PLESS

STRUCTURAL ENGINEER
5430 WADE PARK BOULEVARD SUITE 400
RALEIGH, NC 27607
TELE: 919.832.5587
WWW.BENNETT-PLESS.COM
LICENSE # F-1105

CBHF ENGINEERS, PLLC

MEP ENGINEER
2246 YALPON DRIVE
WILMINGTON, NC 28401
TELE: 910.791.4000
FAX: 910.791.5266
WWW.CMHENGINEERS.COM
LCRUSE@CMH.ENG

LIGHTSWITCH

LIGHTING DESIGNER
10265 INDIANA COURT
RANCHO CUCAMONGA, CA 91730
TELE: 909.360.2900
WWW.LIGHTSWITCH.NET

TUNSTALL CONSULTING ENGINEERS PLLC

CIVIL ENGINEER
2602 IRON GATE DRIVE SUITE 102
WILMINGTON, NC 28412
TELE: 910.343.9653
FAX: 910.343.9604
WWW.NTEENGINEERS.COM
LIC#E064409160

SURFACE 678, PA

LANDSCAPE ARCHITECT
215 MORRIS STREET SUITE 150
DURHAM, NC 27701
TELE: 919.419.1199
FAX: 919.419.1669
WWW.SURFACE678.COM
LICENSE # C-098

CHEATHAM & ASSOCIATES, PA

FIRE PROTECTION ENGINEER
3412 ENTERPRISE DRIVE
WILMINGTON, NC 28405
TELE: 910.452.4210
WWW.CHEATHAMPA.COM
LICENSE # C-1073

PALACIO COLLABORA

COST ESTIMATOR
4819 EMPEROR BOULEVARD SUITE 400
DURHAM, NC 27703
TELE: 919.605.8952
WWW.PALACIOCOLLABORATIVE.COM

NOTE: IF THIS DRAWING IS NOT 30" X 42", IT
REDUCED PRINT. REFER TO GRAPHIC SCALE

NOT FOR
CONSTRUCTION




**NOT FOR
CONSTRUCTION**

NO.	DATE	DESCRIPTION
1	9-8-25	BID SET

PLUMBING RISER DIAGRAMS

P-6.14

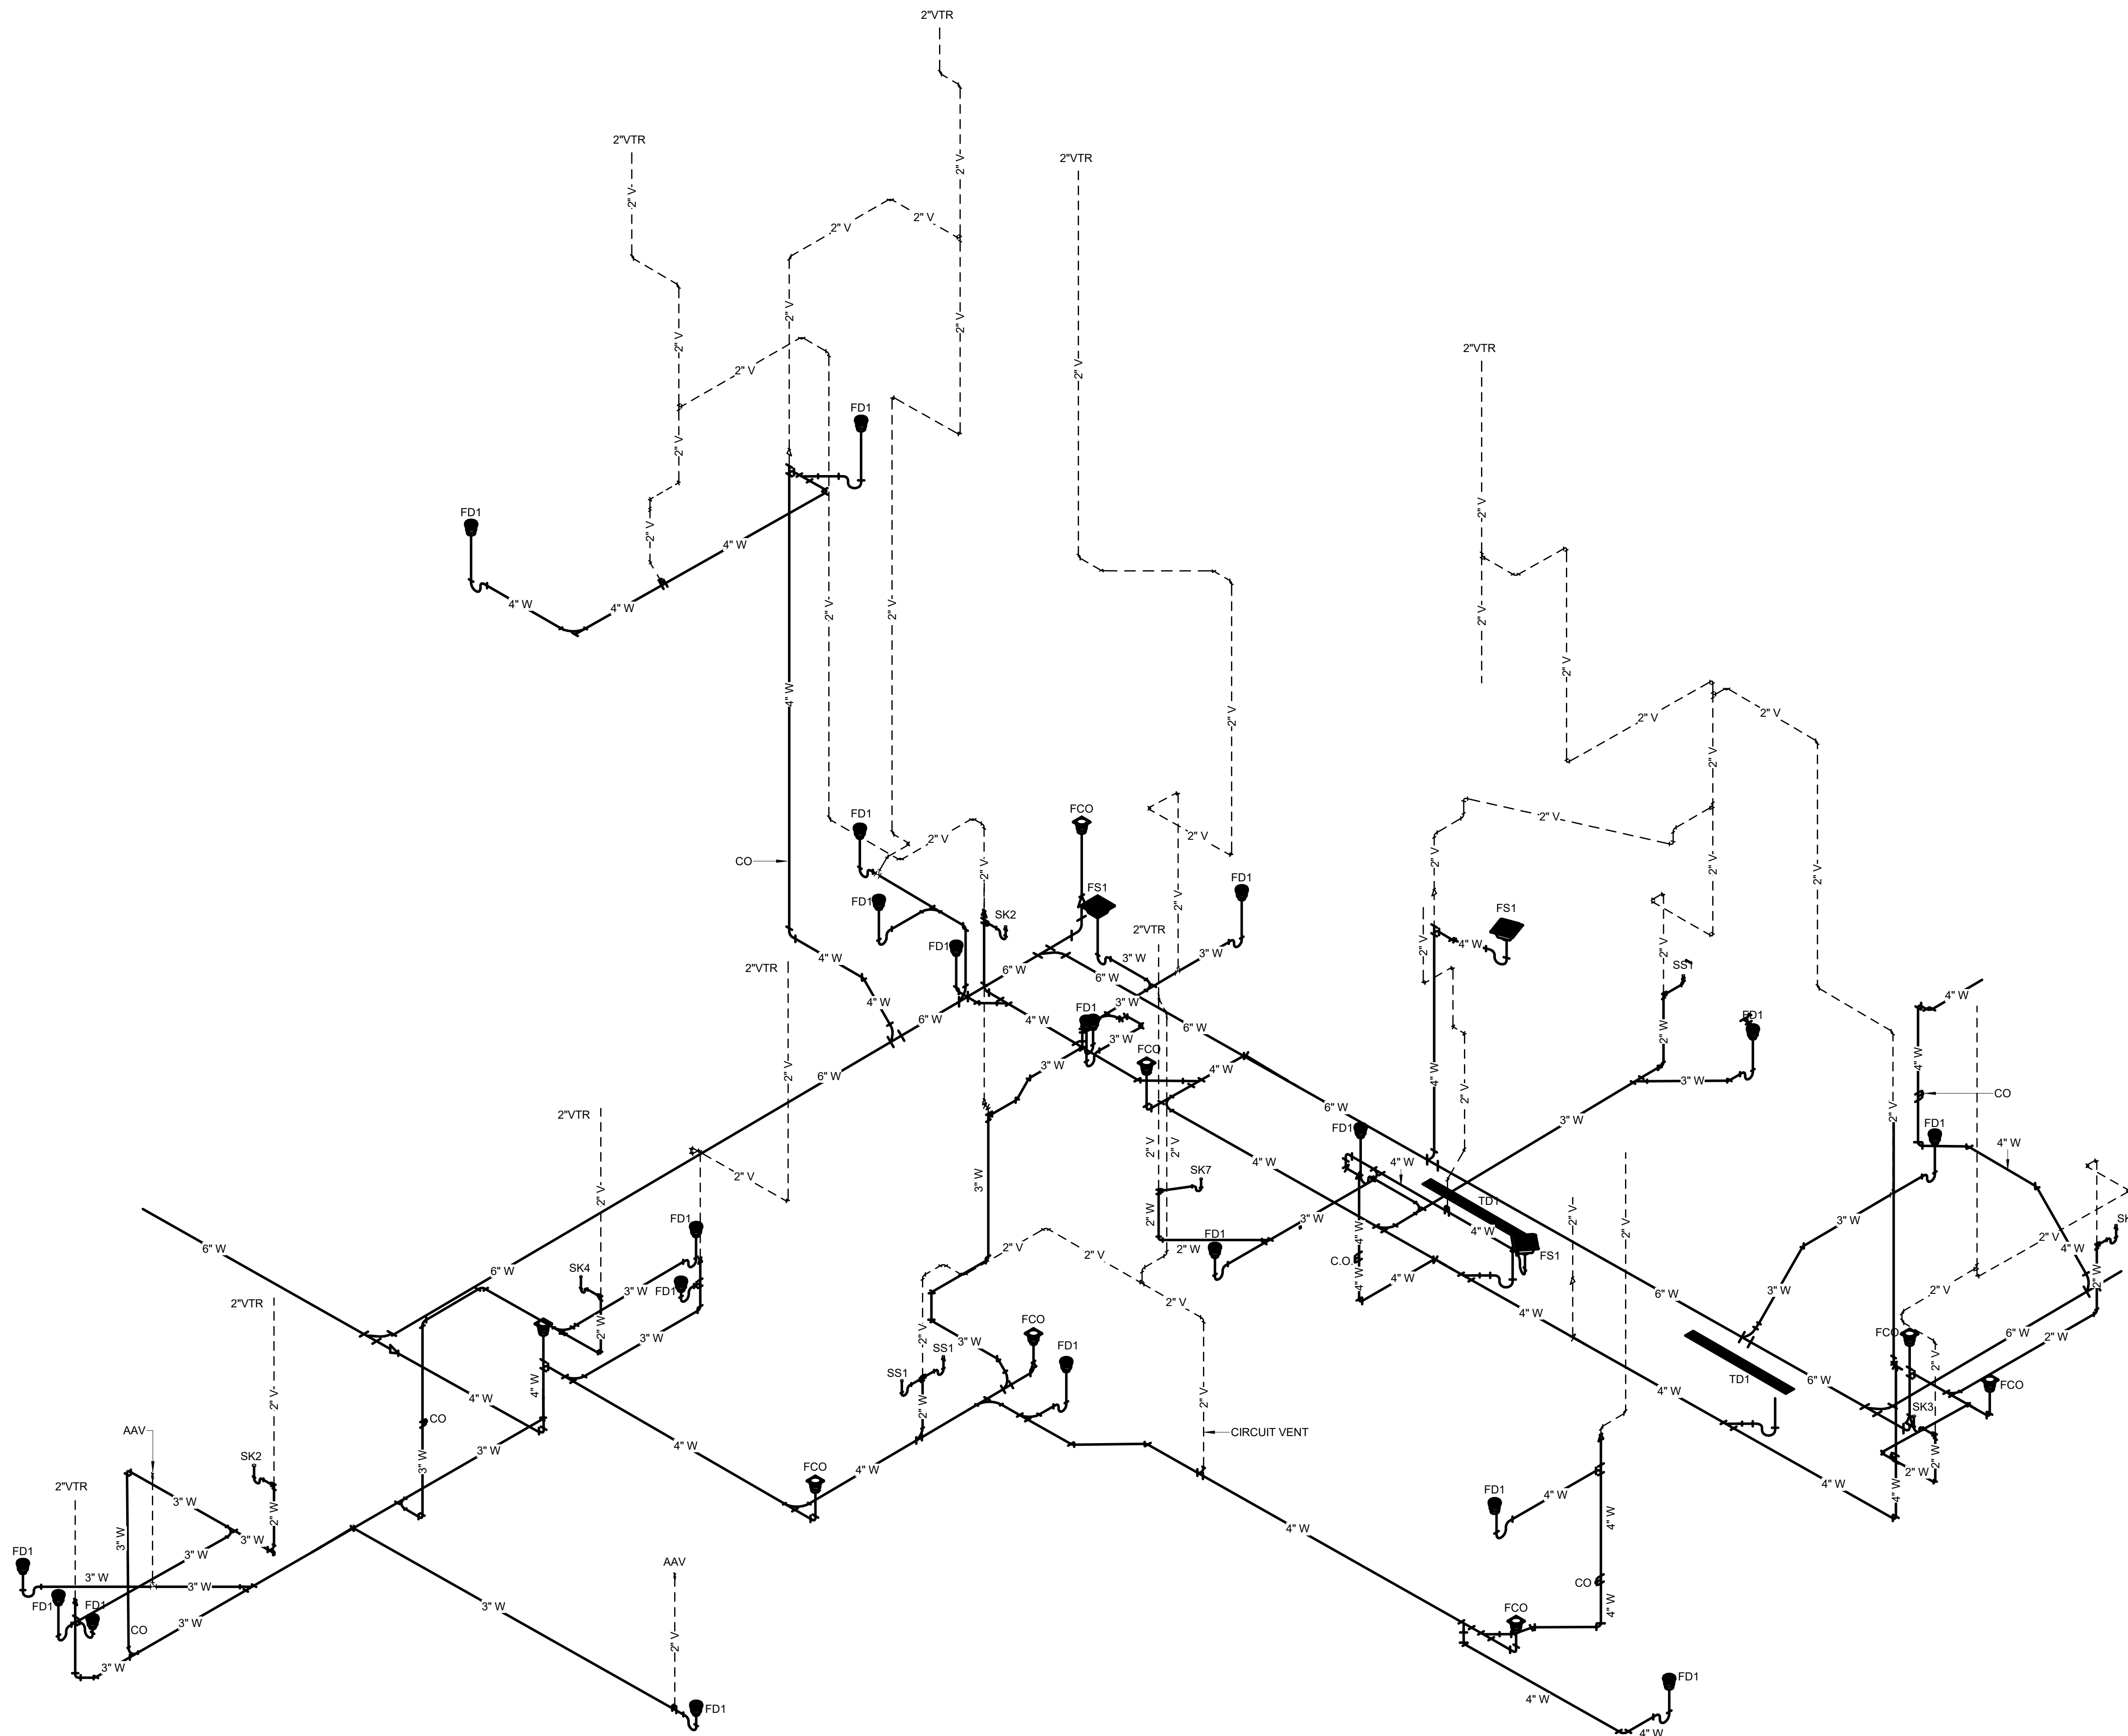


2246 Yaupon Drive
Wilmington, NC 28401
Phone: 910.791.4000
Fax: 910.791.5266

© Copyright 2025 CBHF Engineers, PLLC NC# P-0506

Ambassador Animals Waste Vent Riser Diagram

SCALE :

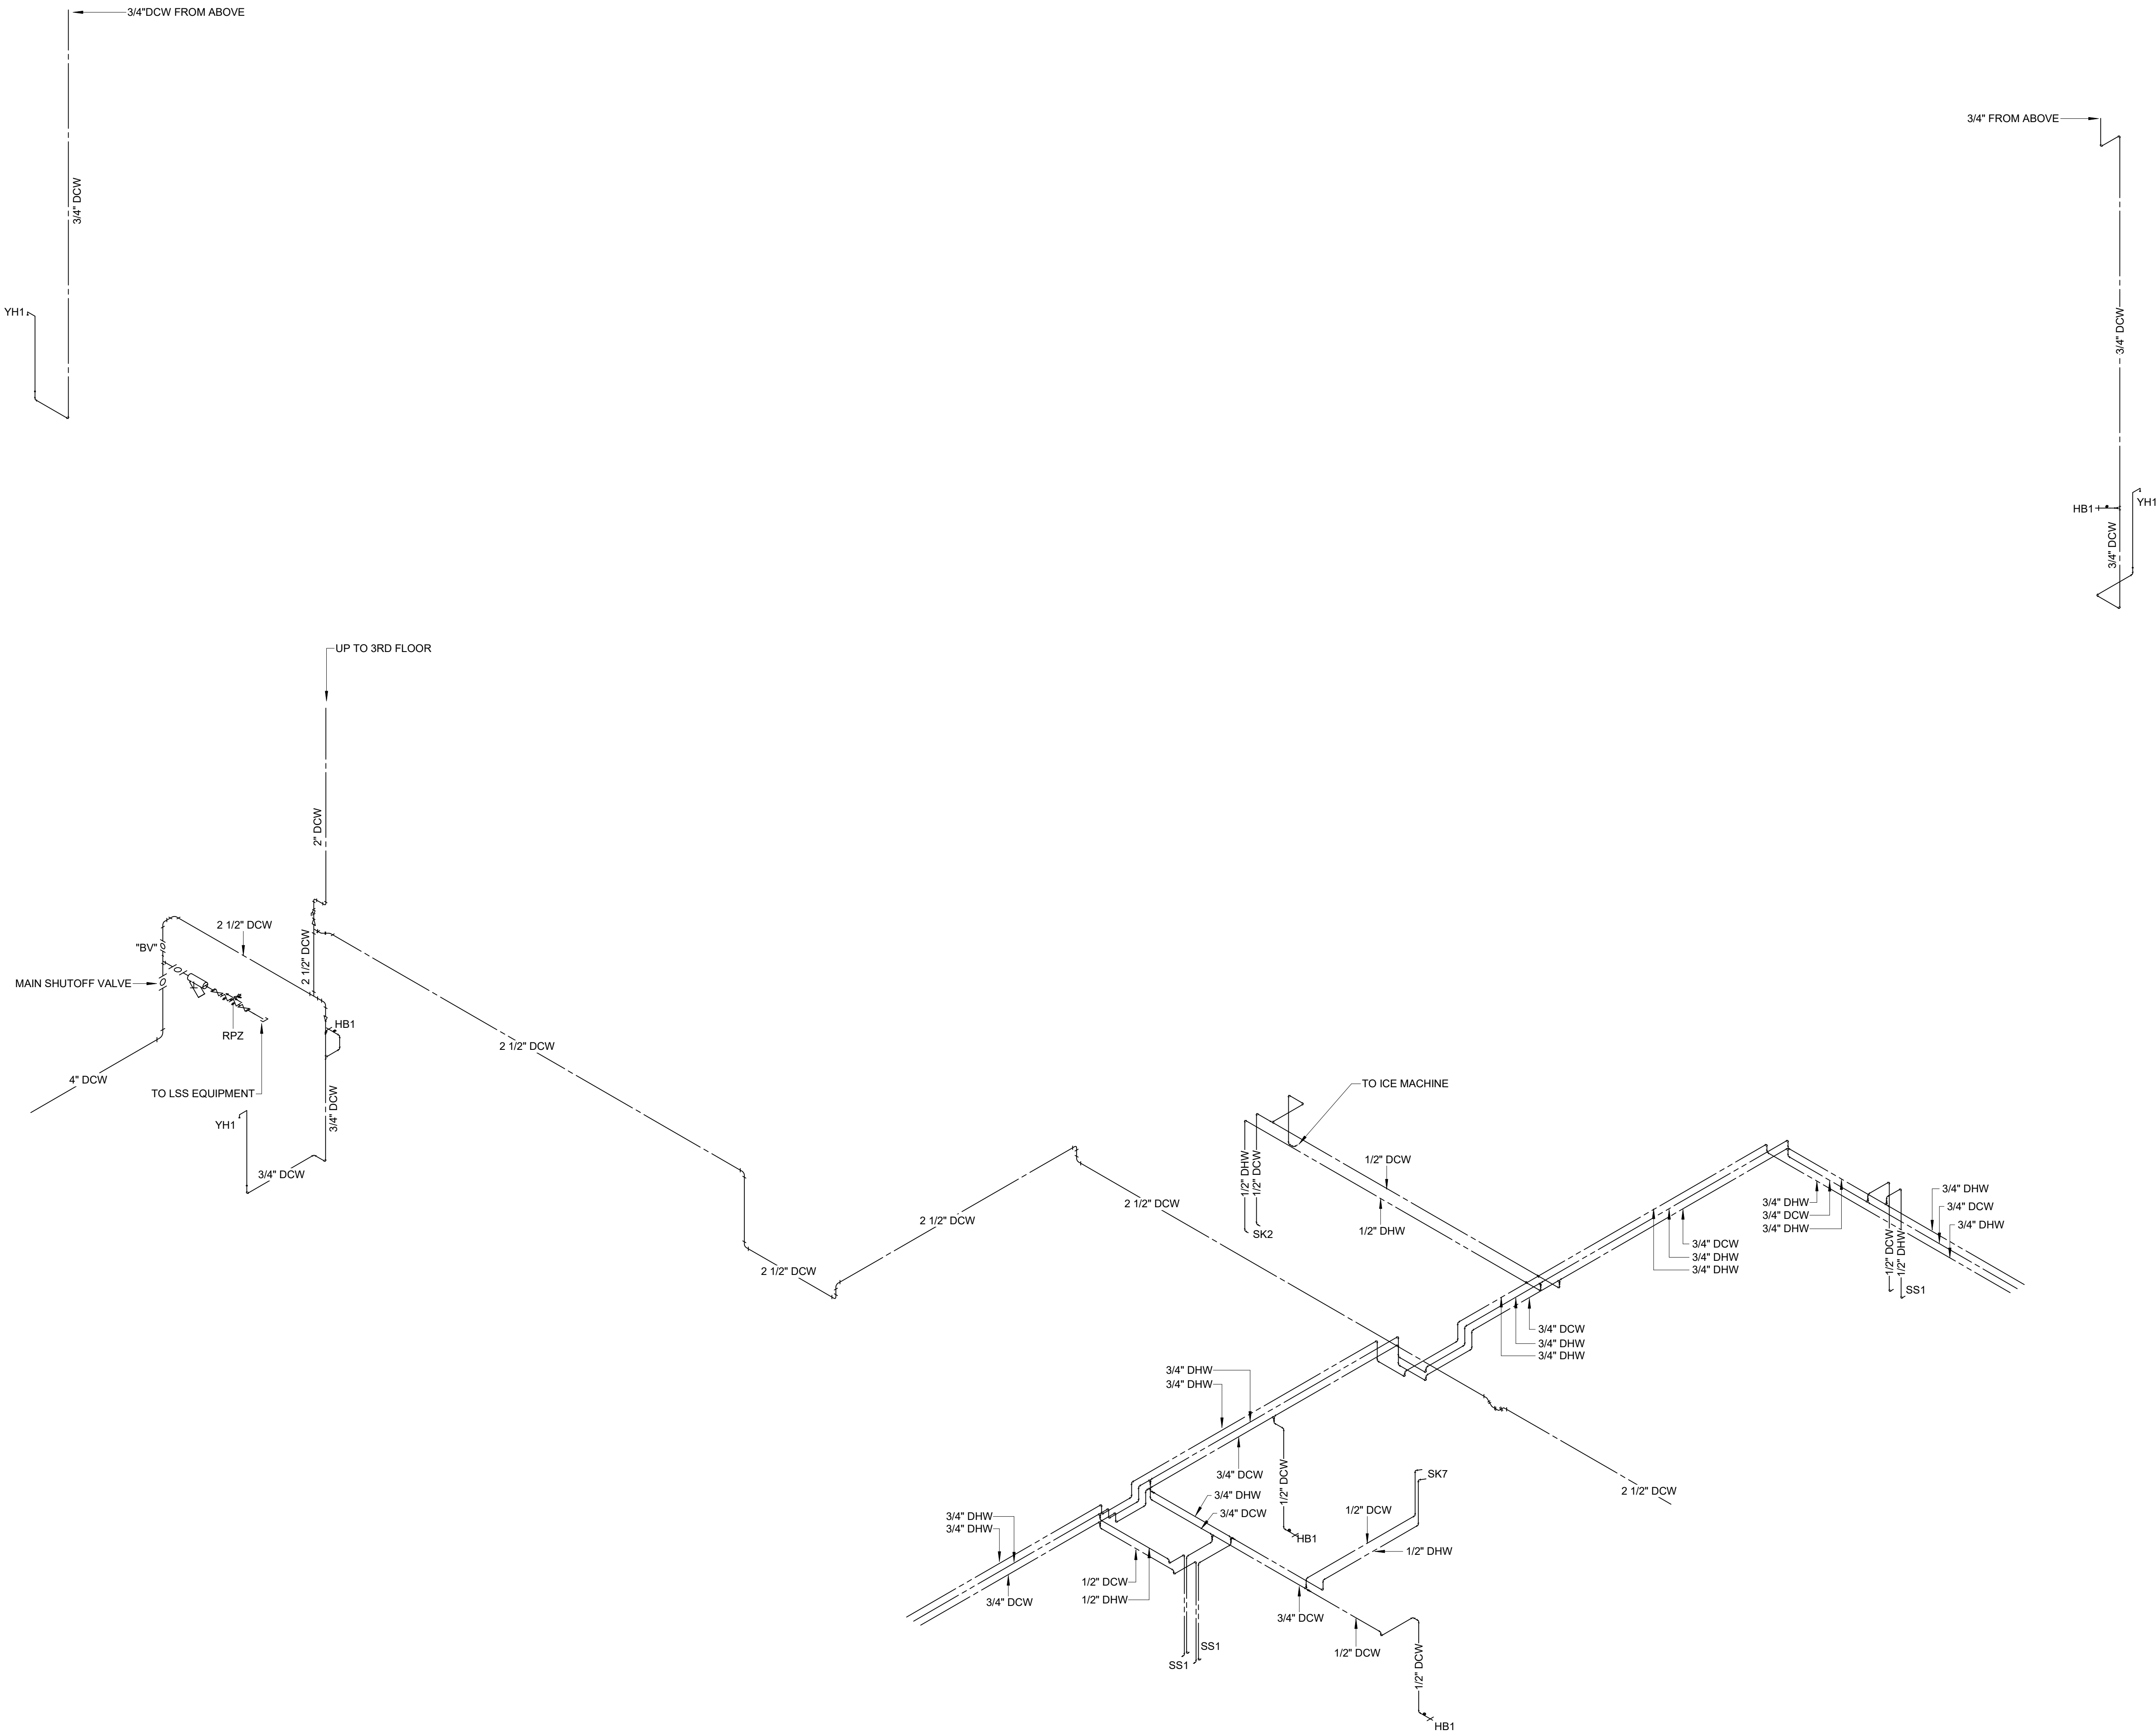

CBHF
Engineers, PLLC

2246 Yaupon Drive
Wilmington, NC 28401
Phone: 910.791.4000
Fax: 910.791.5566
www.cbhfindesign.com
© Copyright 2025 CBHF Engineers, PLLC. NCIR P-0356

FIRST FLOOR SHARK TANK DOMESTIC WATER RISER DIAGRAM - "A"

SCALE:

1

SZOSTAK DESIGN

FORT FISHER
AQUARIUM
RENOVATION
& EXPANSION:
PHASE 1

SCO #17-18042-02A
CODE: 42014-4G02
ITEM: 41414-4Y4A

900 LOGGERHEAD RD,
KURE BEACH, NC 28449

NORTH CAROLINA DEPT. OF
NATURAL & CULTURAL RESOURCES

SZOSTAK DESIGN, INC.

ARCHITECT
310 1/2 WEST FRANKLIN STREET
CHAPEL HILL, NORTH CAROLINA 27514
TEL: 919.929.5244
FAX: 919.960.7967
WWW.SZOSTAKDESIGN.COM
LICENSE # 31079

TJP ENGINEERING, INC.

LIFE SUPPORT SYSTEMS ENGINEER
56880 VENTURE LANE SUITE 205H
BEND, OR 97007
TEL: 503.432.0300
WWW.TJPENGINEERING.COM
LICENSE # C-3505

ROTO GROUP, LLC.

EXHIBIT DESIGNER
7001 DISCOVERY BOULEVARD
DURHAM, NC 27707
TEL: 919.282.5587
WWW.ROTO.COM
WWW.ROTO.COM

BENNETT & PLESS

STRUCTURAL ENGINEER
5430 WADE PARK BOULEVARD SUITE 400
RALEIGH, NC 27607
TEL: 919.832.5587
WWW.BENNETT-PLESS.COM
LICENSE # F-1105

CBHF ENGINEERS, PLLC

MFP ENGINEER
2246 YAUPOIN DRIVE
WILMINGTON, NC 28401
TEL: 910.791.4000
FAX: 910.791.5566
WWW.CBHFENGINEERS.COM
LICENSE # P-0554

LIGHTSWITCH

LIGHTING DESIGNER
10365 INDIANA COURT
RANCHO CUCAMONGA, CA 91730
TEL: 909.360.0900
WWW.LIGHTSWITCH.NET

TUNSTALL CONSULTING ENGINEERS PLLC

CIVIL ENGINEER
2402 IRON GATE DRIVE SUITE 102
WILMINGTON, NC 28412
TEL: 910.343.9423
FAX: 910.343.9404
WWW.TUNSTALLENGINEERS.COM
LICENSE # F-3132

SURFACE 678, PA

LANDSCAPE ARCHITECT
215 AGGERS STREET SUITE 150
DURHAM, NC 27703
TEL: 919.419.1199
FAX: 919.419.1688
WWW.SURFACE678.COM
LICENSE # C-098

CHEATHAM & ASSOCIATES, PA

FIRE PROTECTION ENGINEER
3412 ENTERPRISE DRIVE
WILMINGTON, NC 28405
TEL: 910.452.4510
WWW.CHEATHAMPA.COM
LICENSE # C-1073

PALACIO COLLABORATIVE

COST ESTIMATOR
4815 ENTERPRISE BOULEVARD SUITE 400
DURHAM, NC 27703
TEL: 919.453.8916
WWW.PALACIOCOLLABORATIVE.COM

NOTE: IF THIS DRAWING IS NOT 36" X 42", IT IS A
REDUCED PRINT. REFER TO GRAPHIC SCALE.

NOT FOR
CONSTRUCTION

SEAL
23551
ENGINEER
DAVID M. HARR


NOT FOR
CONSTRUCTION

NO.	DATE	DESCRIPTION
-----	------	-------------

1	9-8-25	BID SET
---	--------	---------

PLUMBING RISER
DIAGRAMS

P-6.15

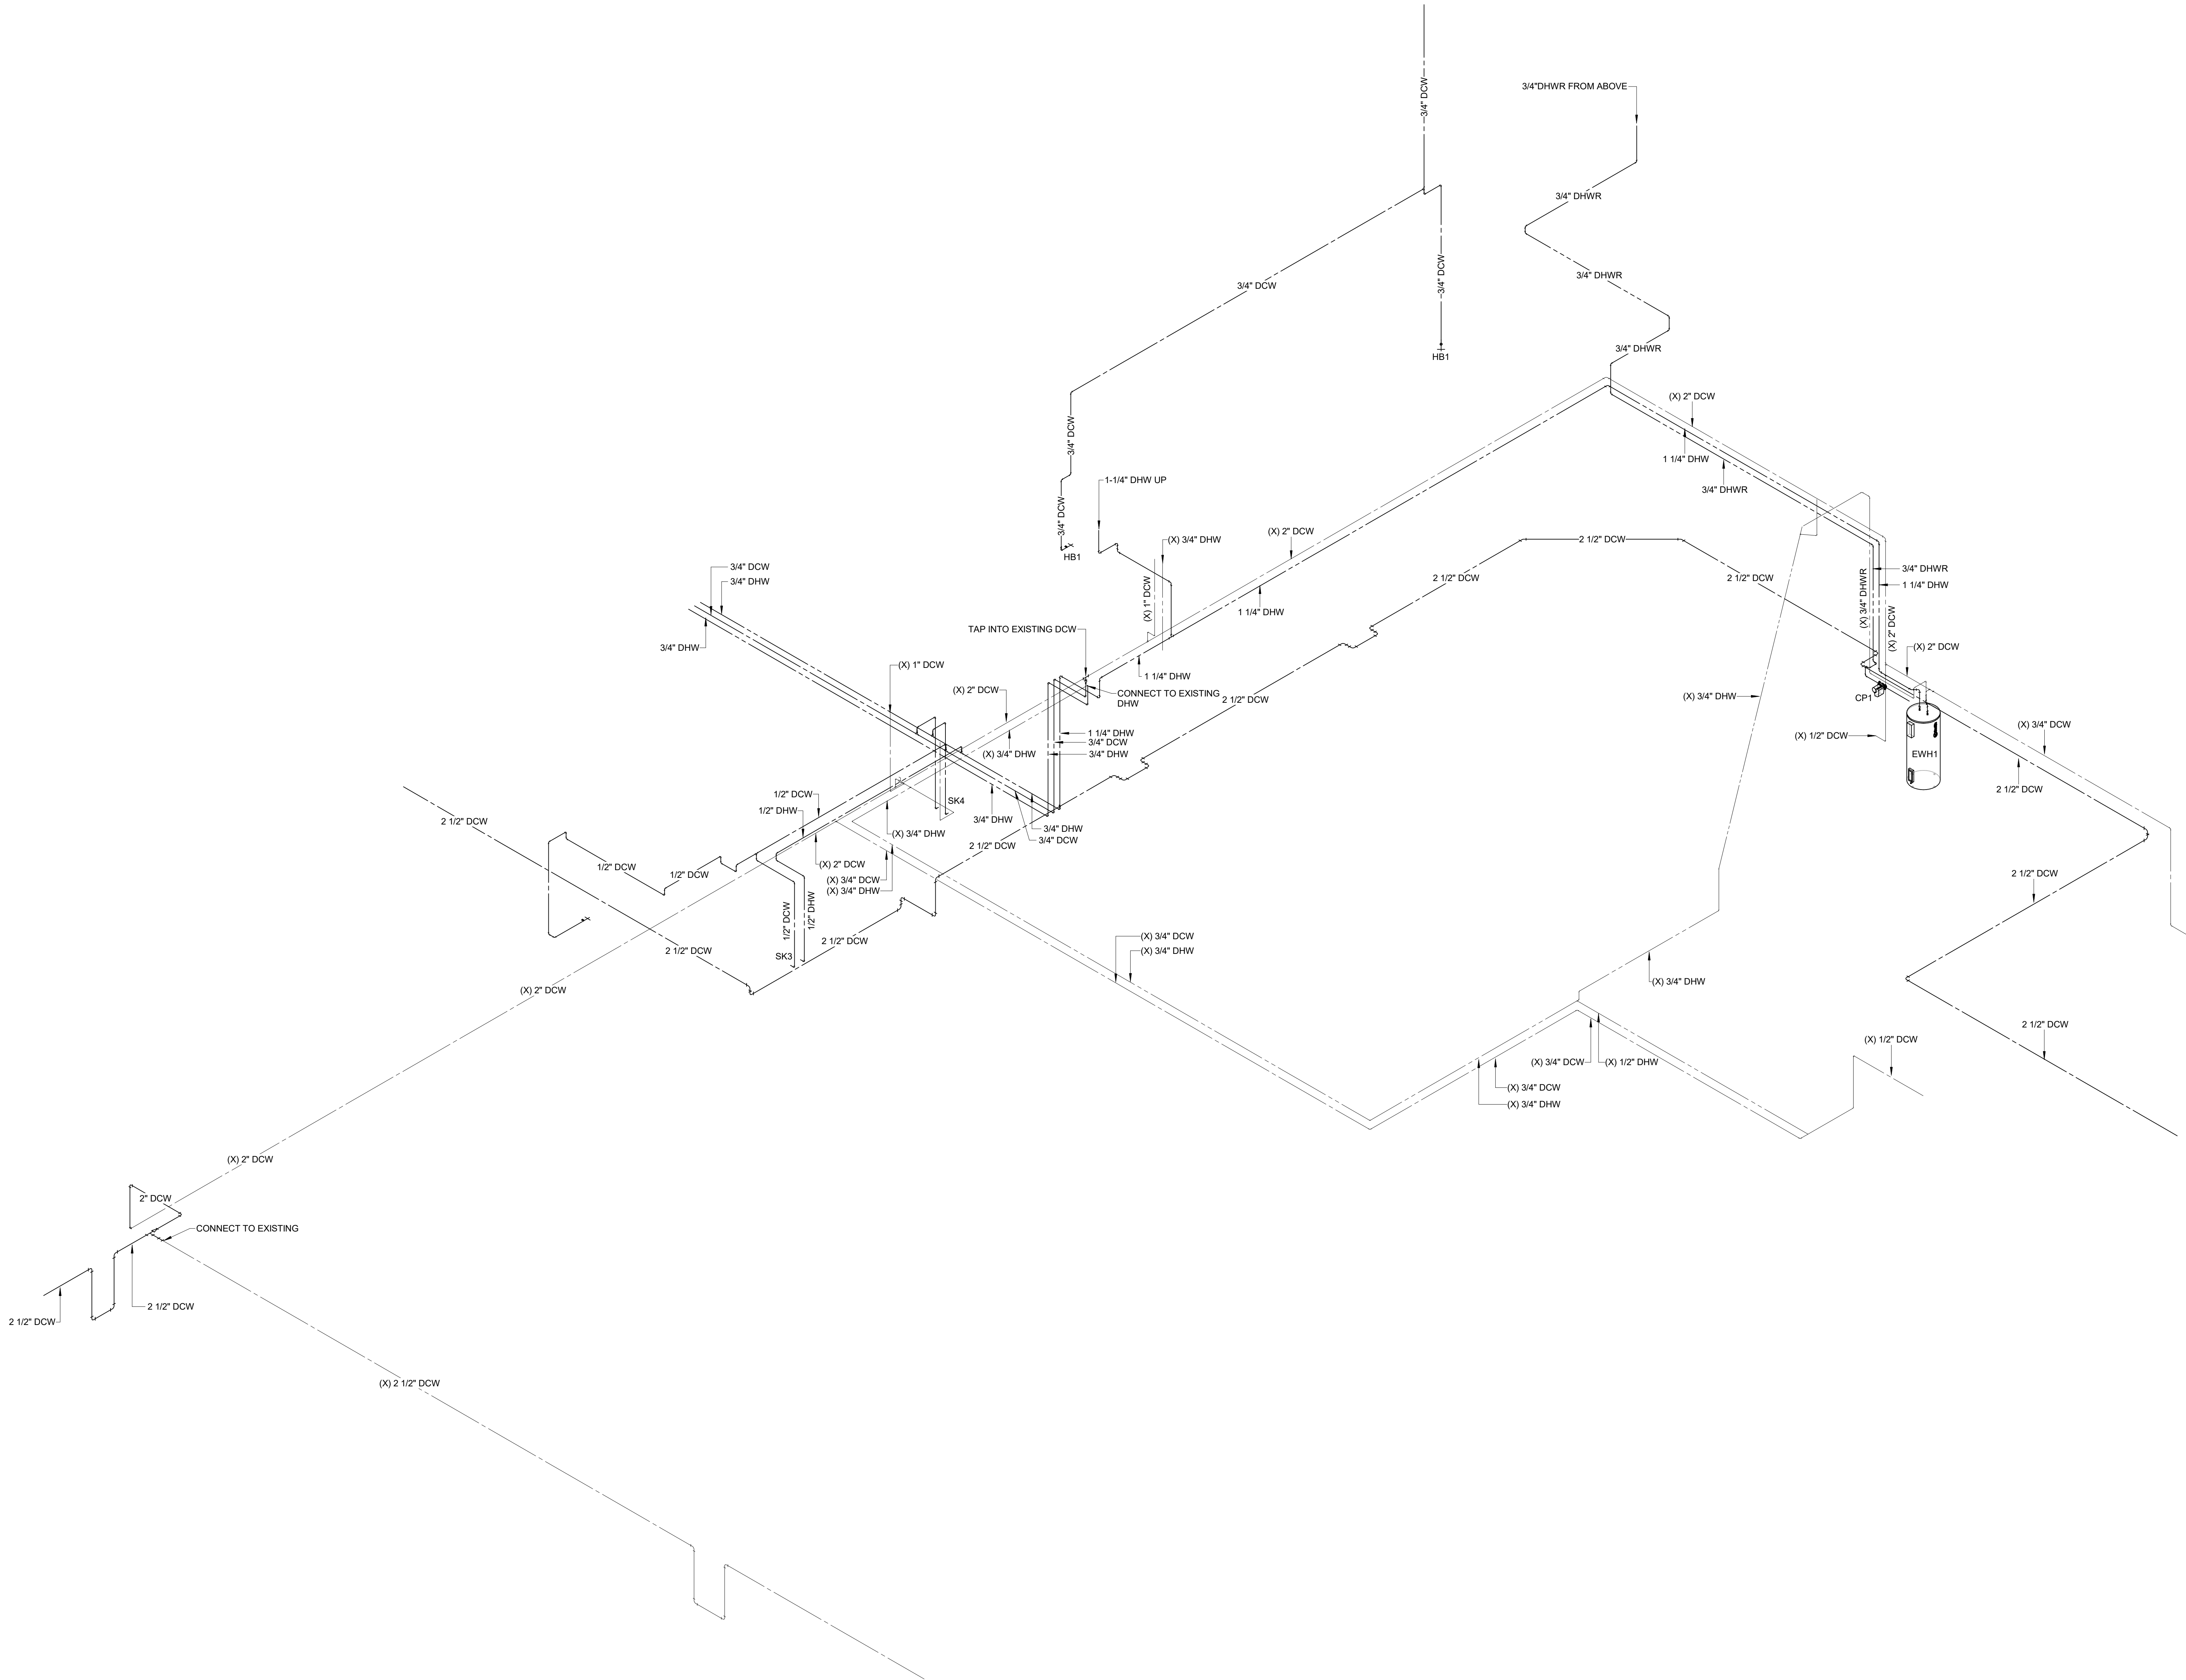

CBHF
Engineers, PLLC

2246 Yaupon Drive
Wilmington, NC 28401
Phone: 910.791.4000
Fax: 910.791.5266
www.cbhfengineers.com

© Copyright 2025 CBHF Engineers, PLLC. NCIA # 0306

FIRST FLOOR SHARK TANK DOMESTIC WATER RISER DIAGRAM

SCALE :

1

SZOSTAK DESIGN

FORT FISHER
AQUARIUM
RENOVATION
& EXPANSION:
PHASE 1

SCO #17-18042-02A
CODE: 42014-4G02
ITEM: 41414-4Y4A

900 LOGGERHEAD RD,
KURE BEACH, NC 28449

NORTH CAROLINA DEPT. OF
NATURAL & CULTURAL RESOURCES

SZOSTAK DESIGN, INC.

ARCHITECT
310 1/2 WEST FRANKLIN STREET
CHAPEL HILL, NORTH CAROLINA 27514
TEL: 919.929.5244
FAX: 919.960.7967
WWW.SZOSTAKDESIGN.COM
LICENSE # 31079

TJP ENGINEERING, INC.

LIFE SUPPORT SYSTEMS ENGINEER
56885 VENTURE LANE SUITE 205H
BEND, OR 97007
TEL: 814.423.0300
WWW.TJPEENGINEERING.COM
LICENSE # C-3505

ROTO GROUP, LLC.

EXHIBIT DESIGNER
7001 DISCOVERY BOULEVARD
DURHAM, NC 27707
TEL: 817.760.6895
WWW.ROTO.COM

BENNETT & PLESS

STRUCTURAL ENGINEER
5430 WADE PARK BOULEVARD SUITE 400
RALEIGH, NC 27607
TEL: 919.832.5587
WWW.BENNETT-PLESS.COM
LICENSE # F-1105

CBHF ENGINEERS, PLLC

MFP ENGINEER
2246 YAUPOH DRIVE
WILMINGTON, NC 28401
TEL: 910.791.4000
FAX: 910.791.5266
WWW.CBHFENGINEERS.COM
LICENSE # F-0554

LIGHTSWITCH

LIGHTING DESIGNER
10365 INDIANA COURT
RANCHO CUCAMONGA, CA 91730
TEL: 909.360.7000
WWW.LIGHTSWITCH.NET

TUNSTALL CONSULTING ENGINEERS PLLC

CIVIL ENGINEER
2402 IRON GATE DRIVE SUITE 102
WILMINGTON, NC 28412
TEL: 910.343.9423
FAX: 910.343.9404
WWW.TUNSTALLENGINEERS.COM
LICENSE # F-3132

SURFACE 678, PA

LANDSCAPE ARCHITECT
215 AGRIS STREET SUITE 150
DURHAM, NC 27703
TEL: 919.419.1199
FAX: 919.419.1688
WWW.SURFACE678.COM
LICENSE # C-096

CHEATHAM & ASSOCIATES, PA


FIRE PROTECTION ENGINEER
3412 ENTERPRISE DRIVE
WILMINGTON, NC 28405
TEL: 910.452.4110
WWW.CHEATHAMPA.COM
LICENSE # C-1073

PALACIO COLLABORATIVE

COST ESTIMATOR
4817 ENTERPRISE BOULEVARD SUITE 400
DURHAM, NC 27703
TEL: 919.453.9100
WWW.PALACIOCOLLABORATIVE.COM

NOTE: IF THIS DRAWING IS NOT 36" X 42", IT IS A
REDUCED PRINT. REFER TO GRAPHIC SCALE.

NOT FOR
CONSTRUCTION

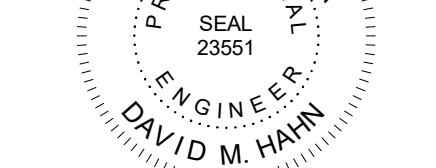

NOT FOR
CONSTRUCTION

NO. DATE DESCRIPTION

1 9-8-25 BID SET

PLUMBING RISER
DIAGRAMS

P-6.16

